



MALCOM RANDALL VETERANS ADMINISTRATION MEDICAL CENTER GAINESVILLE, FLORIDA

SITE

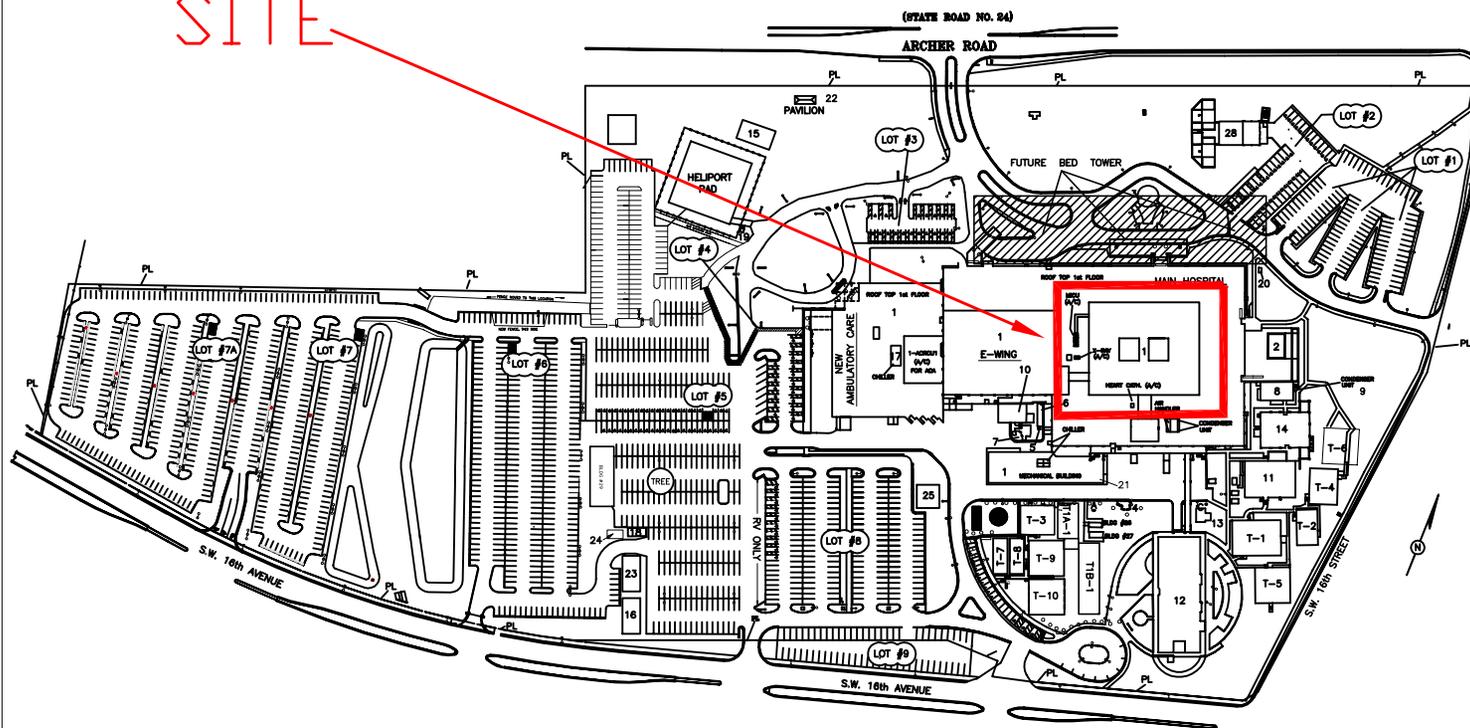

SITE PLAN

Dwg. Title	Project Title			Date
	RENOVATE WARD 3C FOR CARDIOLOGY			MARCH / 2013
Approved - Division Chief	Building No.	Checked	Drawn	DRAWING NO.
	1		MVA	AS 1
Approved - Service Director	Location			Dwg. 1 OF 2
	VA MEDICAL CENTER GAINESVILLE, FL			

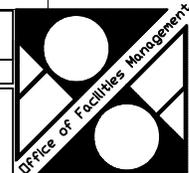

Department of
Veterans Affairs