

GENERAL NOTES

- A. REFER TO DRAWING E001 FOR TYPICAL SYMBOLS AND ABBREVIATIONS USED IN THIS DRAWING.
- B. REFER TO ARCHITECTURAL REFLECTED CEILING PLAN FOR EXACT PLACEMENTS OF LIGHTS.
- C. CONNECT ALL SELF CONTAINED EMERGENCY BATTERY LIGHTS AHEAD OF ANY LOCAL SWITCHING.

DRAWING KEYNOTES


- 1. UP TO FIXTURE, TYPE J01. SEE SHEET EL104, FOR CONTINUATION.
- 2. UP TO FIXTURE TYPE C10. SEE SHEET EL104 FOR CONTINUATION.
- 3. WIRE ALL E01 AND E02 LIGHT FIXTURES AHEAD OF ANY LOCAL SWITCHING IN AREA.
- 4. REFER TO ARCHITECTURAL ELEVATIONS FOR LOCATIONS OF FIXTURE PRIOR TO ROUGH-IN.
- 5. UNLESS NOTED OTHERWISE MOUNT C10 FIXTURES BETWEEN STRUCTURE SO THAT BOTTOM OF LENS IS AT BOTTOM OF STRUCTURE. COORDINATE LOCATIONS OF LIGHTS WITH PIPING, DUCTWORK, ETC. PRIOR TO ROUGH-IN.
- 6. PENDANT MOUNT FIXTURES AT 10' AFF.
- 7. CONDUIT RUNS FOR EXTERIOR LIGHT FIXTURES TO BE CONCEALED.

WALL TYPES LEGEND

- (2) HOUR FIRE BARRIER
- CMU, SEE ARCHITECTURAL PLANS FOR SIZES

COORDINATION DRAWINGS

THE MECHANICAL CONTRACTOR SHALL TAKE THE LEAD IN PREPARATION OF COORDINATION DRAWINGS. SUCH DRAWINGS SHALL BE ARRANGED AND DESIGNED THROUGH AND FROM COORDINATION WITH ALL OTHER MAJOR AND MINOR SUBCONTRACTORS AND THE GENERAL CONTRACTOR. PROVIDE PLAN VIEWS, SECTIONS AND ELEVATIONS AS REQUIRED TO FULLY COORDINATE ALL NEW WORK WITH ITSELF AND EXISTING CONDITIONS. DRAW TO SCALE (AT NOT LESS THAN 3/8" = 1'-0"). DRAWINGS SHALL SHOW, BUT NOT BE LIMITED TO: ALL WALL RATINGS; ALL DUCTWORK; ALL AIR DISTRIBUTION; MECHANICAL EQUIPMENT; MECHANICAL PIPING; FIRE PROTECTION PIPING; ALL PLUMBING PIPING; CABLE TRAYS (WITH ELEVATIONS NOTED); LIGHTING FIXTURES (WHEN CEILING MOUNTED); CEILING GRID AND CEILING HEIGHT; MAJOR BEAMS AND JOISTS (WITH ELEVATIONS MARKED); FIRE ALARM DEVICES AND SPEAKERS (WHERE CEILING MOUNTED); ELECTRICAL CONDUITS LARGER THAN 2-INCH DIAMETER; ELECTRICAL BUSWAY AND REQUIRED CLEARANCES. EQUIPMENT PROVIDED BY OTHERS THAT PROTRUDE INTO CEILING CAVITIES OR IMPIDE THE LOCATION OR ACCESS TO ABOVE CEILING PIPING, DUCTWORK OF OTHER EQUIPMENT. SECTIONS SHALL BE CUT THROUGH AREAS SHOWING MATERIALS AND SYSTEMS OF ALL CONTRACTS. IF THERE ARE ANY OUTSTANDING ISSUES THAT CANNOT BE RESOLVED, CONSULT WITH THE ARCHITECT AND/OR ENGINEER (THROUGH THE VA COTR) FOR GUIDANCE AND MAKE CORRECTIONS IN ACCORDANCE WITH DIRECTIONS GIVEN. IT IS IMPORTANT TO NOTE THAT FABRICATION CANNOT BEGIN UNTIL COORDINATION DRAWINGS HAVE BEEN APPROVED. ANY MATERIAL, EQUIPMENT, SYSTEMS, ETC., PROCUREMENT OR INSTALLATION COMMENCED PRIOR TO APPROVAL IS TAKEN AT THE CONTRACTOR'S OWN RISK AND MAY HAVE TO BE MODIFIED, MOVED AND/OR RECONFIGURED AT THE CONTRACTOR'S COST.

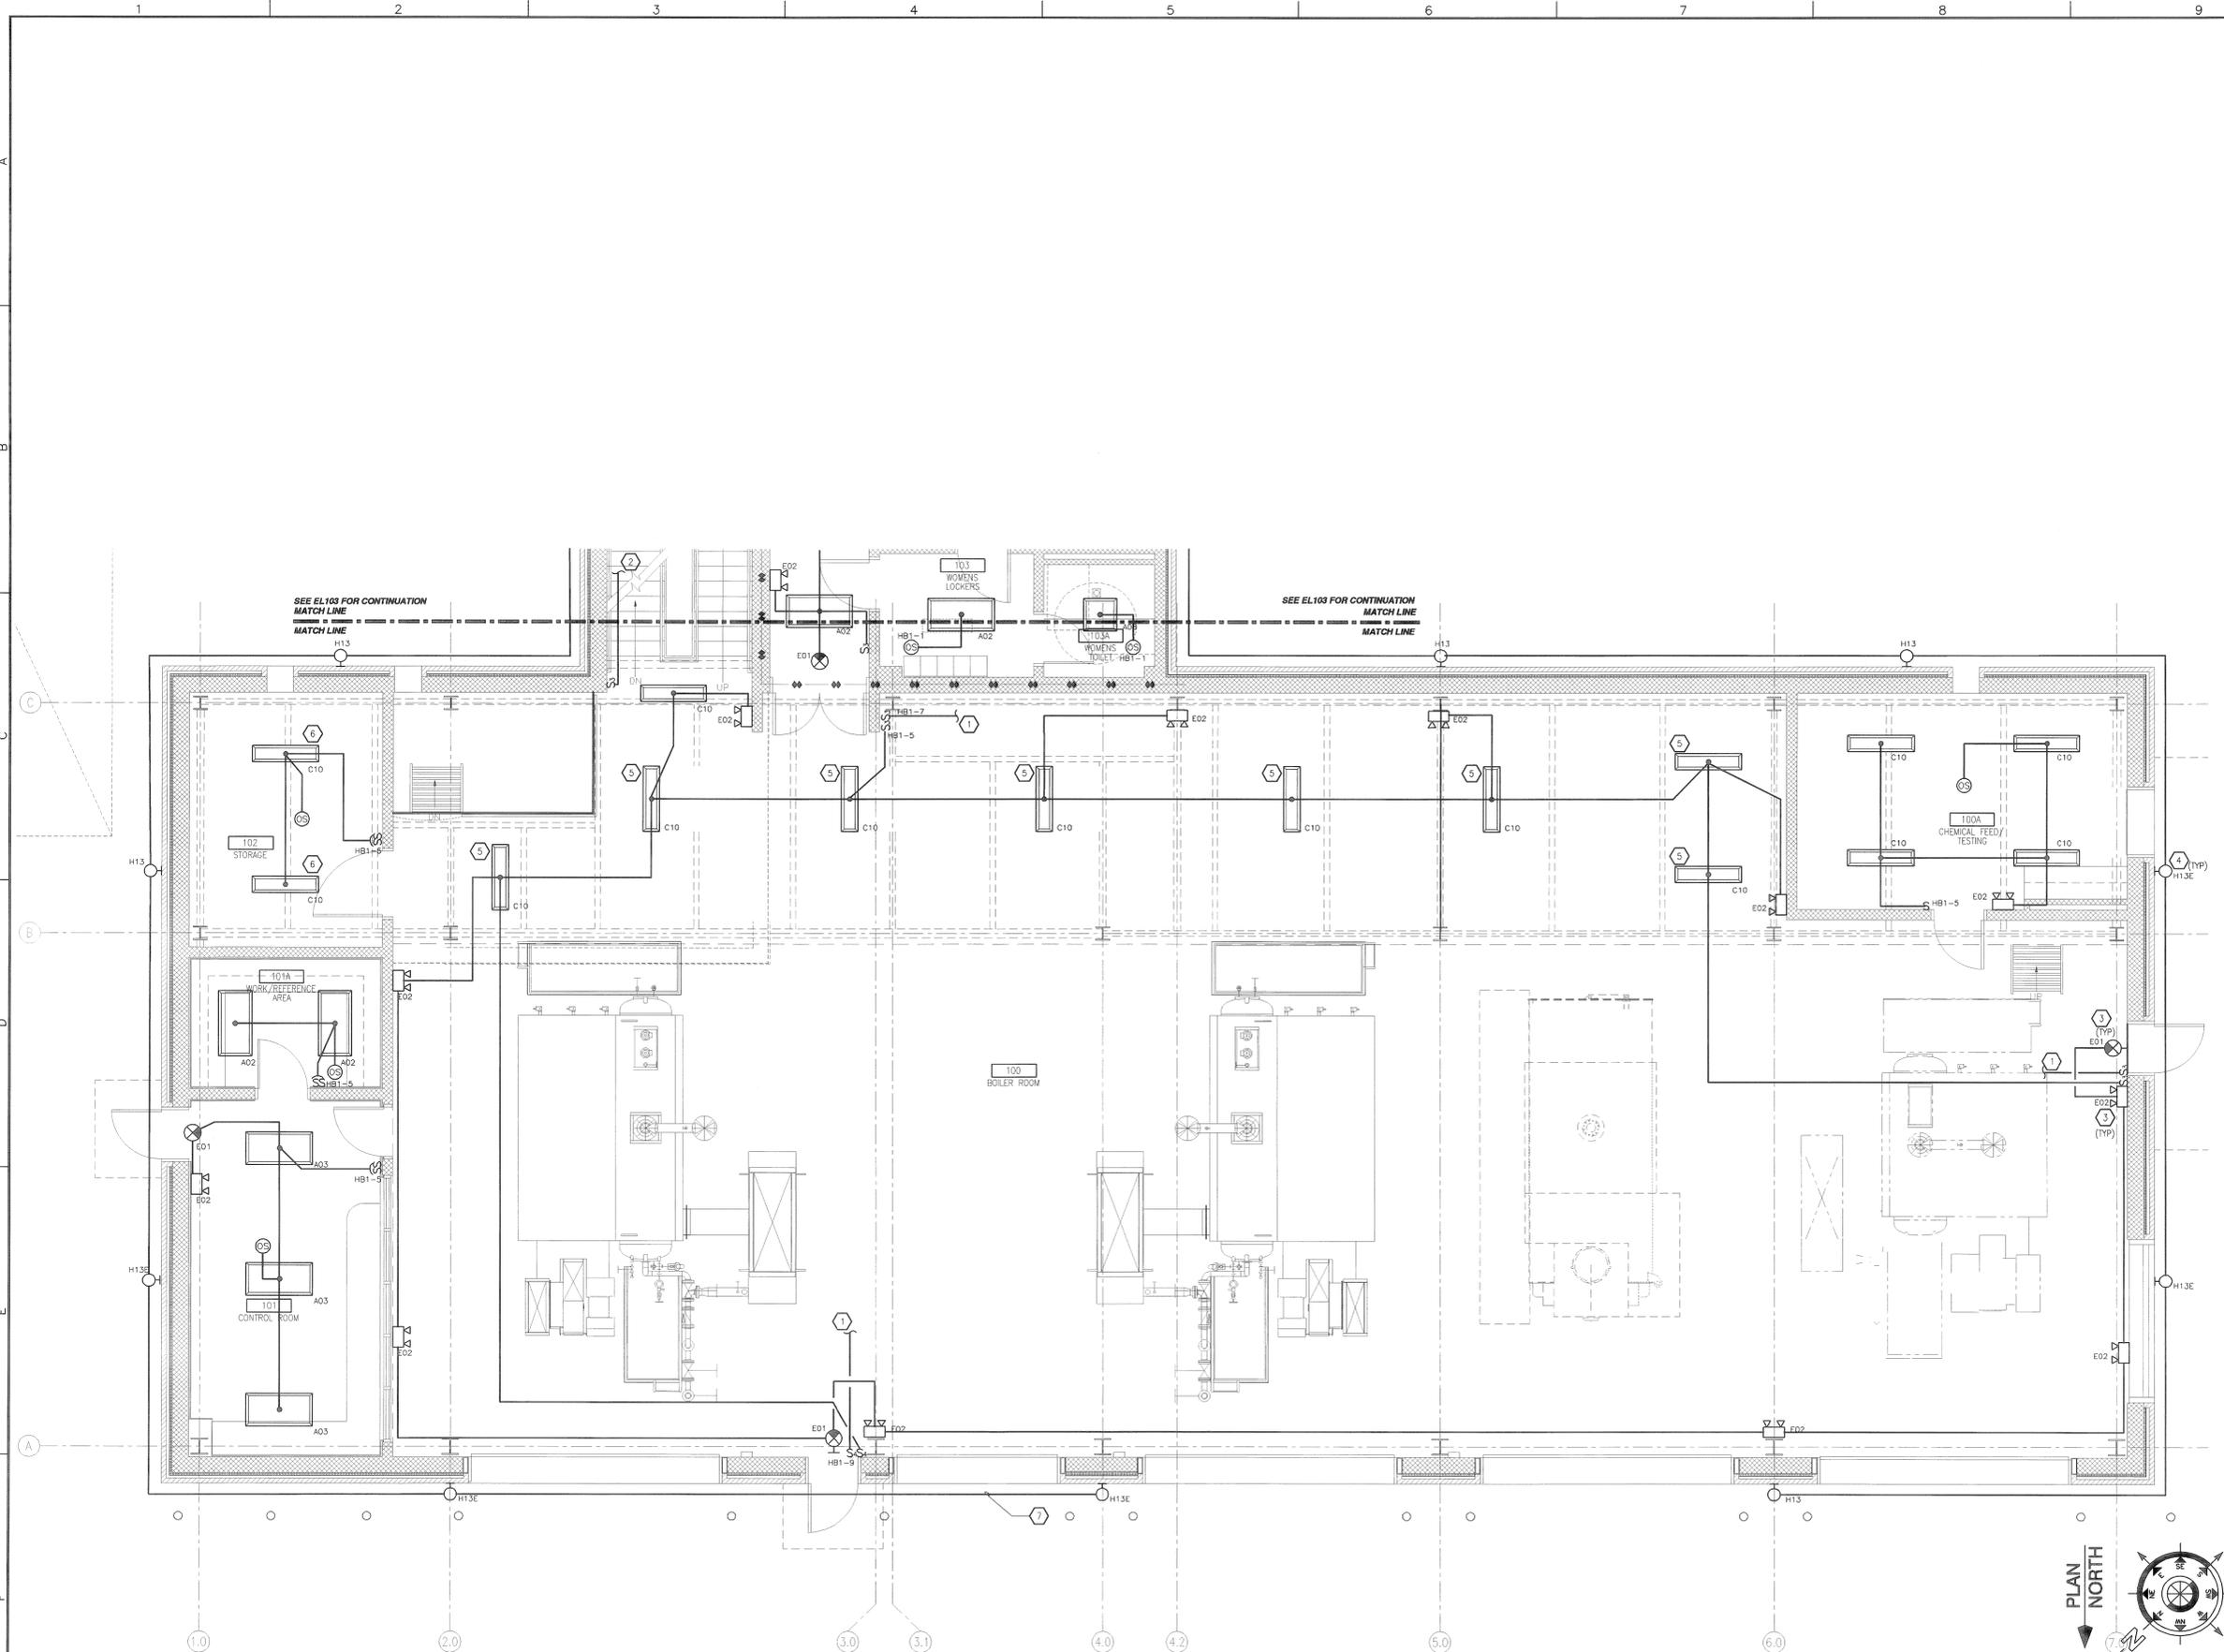

F6 PARTIAL FIRST FLOOR LIGHTING PLAN - NORTH
SCALE: 1/4" = 1'-0"

100% CONSTRUCTION DOCUMENTS

REVISION NO.	REVISION DESCRIPTION	By	Date

Department of Veterans Affairs
William Jennings Bryan Dorn
VA Medical Center
6439 Garners Ferry Road
Columbia, SC 29209

Professional Engineer Seal for John G. Ross, License No. 3820, dated 4-30-12.

Architect/Engineer Address:
Harrell, Saltrick & Hopper
 Design & Management Solutions for the Built Environment
 4016 TORNER POINT DRIVE CHARLOTTE, NC 28227
 P 704.814.1320 F 704.321.0833
 WWW.HSHPC.COM
 COPYRIGHT © 2011 HARRELL, SALTRICK & HOPPER, PC
 HSN PROJECT # 11016

Recommended Approvals:	
1. MEDICAL DIRECTOR	6. OPERATIONS SERVICE LINE MANAGER
2. ASSOCIATE DIRECTOR	7. INFECTION CONTROL MANAGER
3. CHIEF OF STAFF	8. SAFETY MANAGER
4. ASSOC. DIRECTOR	9. GENERAL ENGINEER
5. SERVICE LINE MGRS.	10. COTR

Drawing Title:
PARTIAL FIRST FLOOR LIGHTING PLAN NORTH
 BUILDING IS FULLY SPRINKLERED

Project Title	
REPLACE BOILER PLANT/ COGEN/CHP	
Drawn	Building Number
dc	21
Checked	Reviewed
	Const. Contract No.

Date	
APRIL 30, 2012	
Project Number	
544-11-101	
DRAWING No.	
EL102	

