

REVISION NO.	REVISION DESCRIPTION	BY	DATE

Department of Veterans Affairs
 William Jennings Bryan Dorn
 VA Medical Center
 6439 Garners Ferry Road
 Columbia, SC 29209



Architect/Engineer Address
Hartel, Saltrick & Hopper
 Building & Management Solutions for the Built Environment
 777 N. Main Street
 Suite 1000
 Columbia, SC 29201
 Phone: 803.799.1100
 Fax: 803.799.1101
 Website: www.hsh.com

Recommended Approvals:	
1. MEDICAL DIRECTOR	6. OPERATIONS SERVICE LINE MANAGER
2. ASSOCIATE DIRECTOR	7. INFECTION CONTROL MANAGER
3. CHIEF OF STAFF	8. SAFETY MANAGER
4. ASSOC. DIRECTOR	9. GENERAL ENGINEER
5. SERVICE LINE MGRS.	10. COIR


Drawing Title
REFLECTED CEILING PLAN - PARTIAL FIRST FLOOR - SOUTH
 * BUILDING IS FULLY SPRINKLERED *

Project Title
REPLACE BOILER PLANT/ COGEN/CHP

Drawn	RLS, MJP	Building Number	AutoCAD File Name	Date	APRIL 30 2012
Checked				Project Number	544-11-101
				DRAWING No.	AE108

100% CONSTRUCTION DOCUMENTS

F6 REFLECTED CEILING PLAN - FIRST FLOOR - SOUTH
 SCALE: 1/4" = 1'-0"

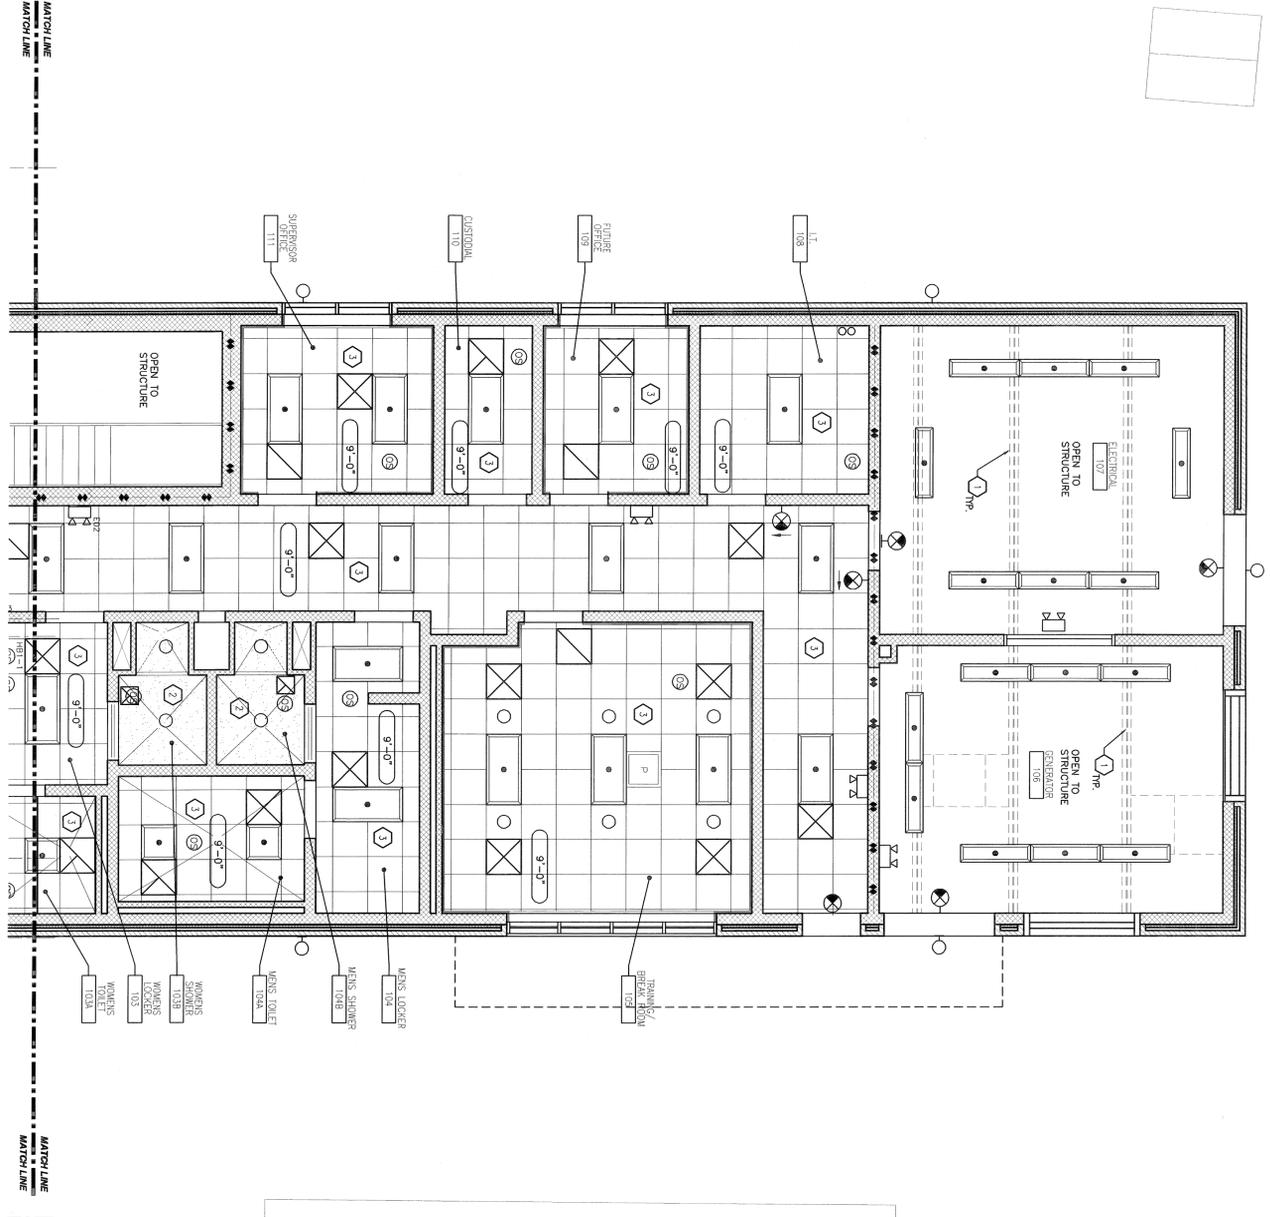

WALL TYPES LEGEND

	(1) 1/2\"/>
	(2) 1\"/>
	(3) 2\"/>

CALL SEE ARCHITECTURAL PLANS FOR SIZES

DRAWING KEYNOTES

- STEEL FRAMING - SEE STRUCTURAL
- SUSPENDED OPSAM BOARD CEILING
- SUSPENDED ACOUSTICAL CEILING TILE

NOTES:

- FOR ARCHITECTURAL SYMBOLS SEE DRAWING A6020
- FOR ELECTRICAL SYMBOLS SEE DRAWING E001

