

REVISION NO.	REVISION DESCRIPTION

Department of Veterans Affairs
 William Jennings Bryan Dorn
 VA Medical Center
 6439 Garners Ferry Road
 Columbia, SC 29209




Architect/Engineer Address
Hartel, Saltlick & Hopper
 Building & Management Solutions for the Built Environment
 1011 North State Street
 Charleston, SC 29403
 Phone: 771.271.0033
 Fax: 771.271.0033
 Website: www.hsh.com
 Copyright © 2011 Hopper & Hopper, PC

Recommended Approvals:	
1. MEDICAL DIRECTOR	6. OPERATIONS SERVICE LINE MANAGER
2. ASSOCIATE DIRECTOR	7. INFECTION CONTROL MANAGER
3. CHIEF OF STAFF	8. SAFETY MANAGER
4. ASSOC. DIRECTOR	9. GENERAL ENGINEER
5. SERVICE LINE MGRS.	10. COTR

Drawing Title		Project Title	
REFLECTED CEILING PLAN - MEZZANINE		REPLACE BOILER PLANT/ COGEN/CHP	
* BUILDING IS FULLY SPRINKLERED *		Drawn	Building Number/ AutoCAD File Name
		R.L.S., M.J.F.	21
		Checked	Reviewed
			Const. Contact No.

Date	Project Number	Drawing No.
APRIL 30 2012	544-1-101	AE109

REFLECTED CEILING PLAN - MEZZANINE
 SCALE: 1/4" = 1'-0"
100% CONSTRUCTION DOCUMENTS

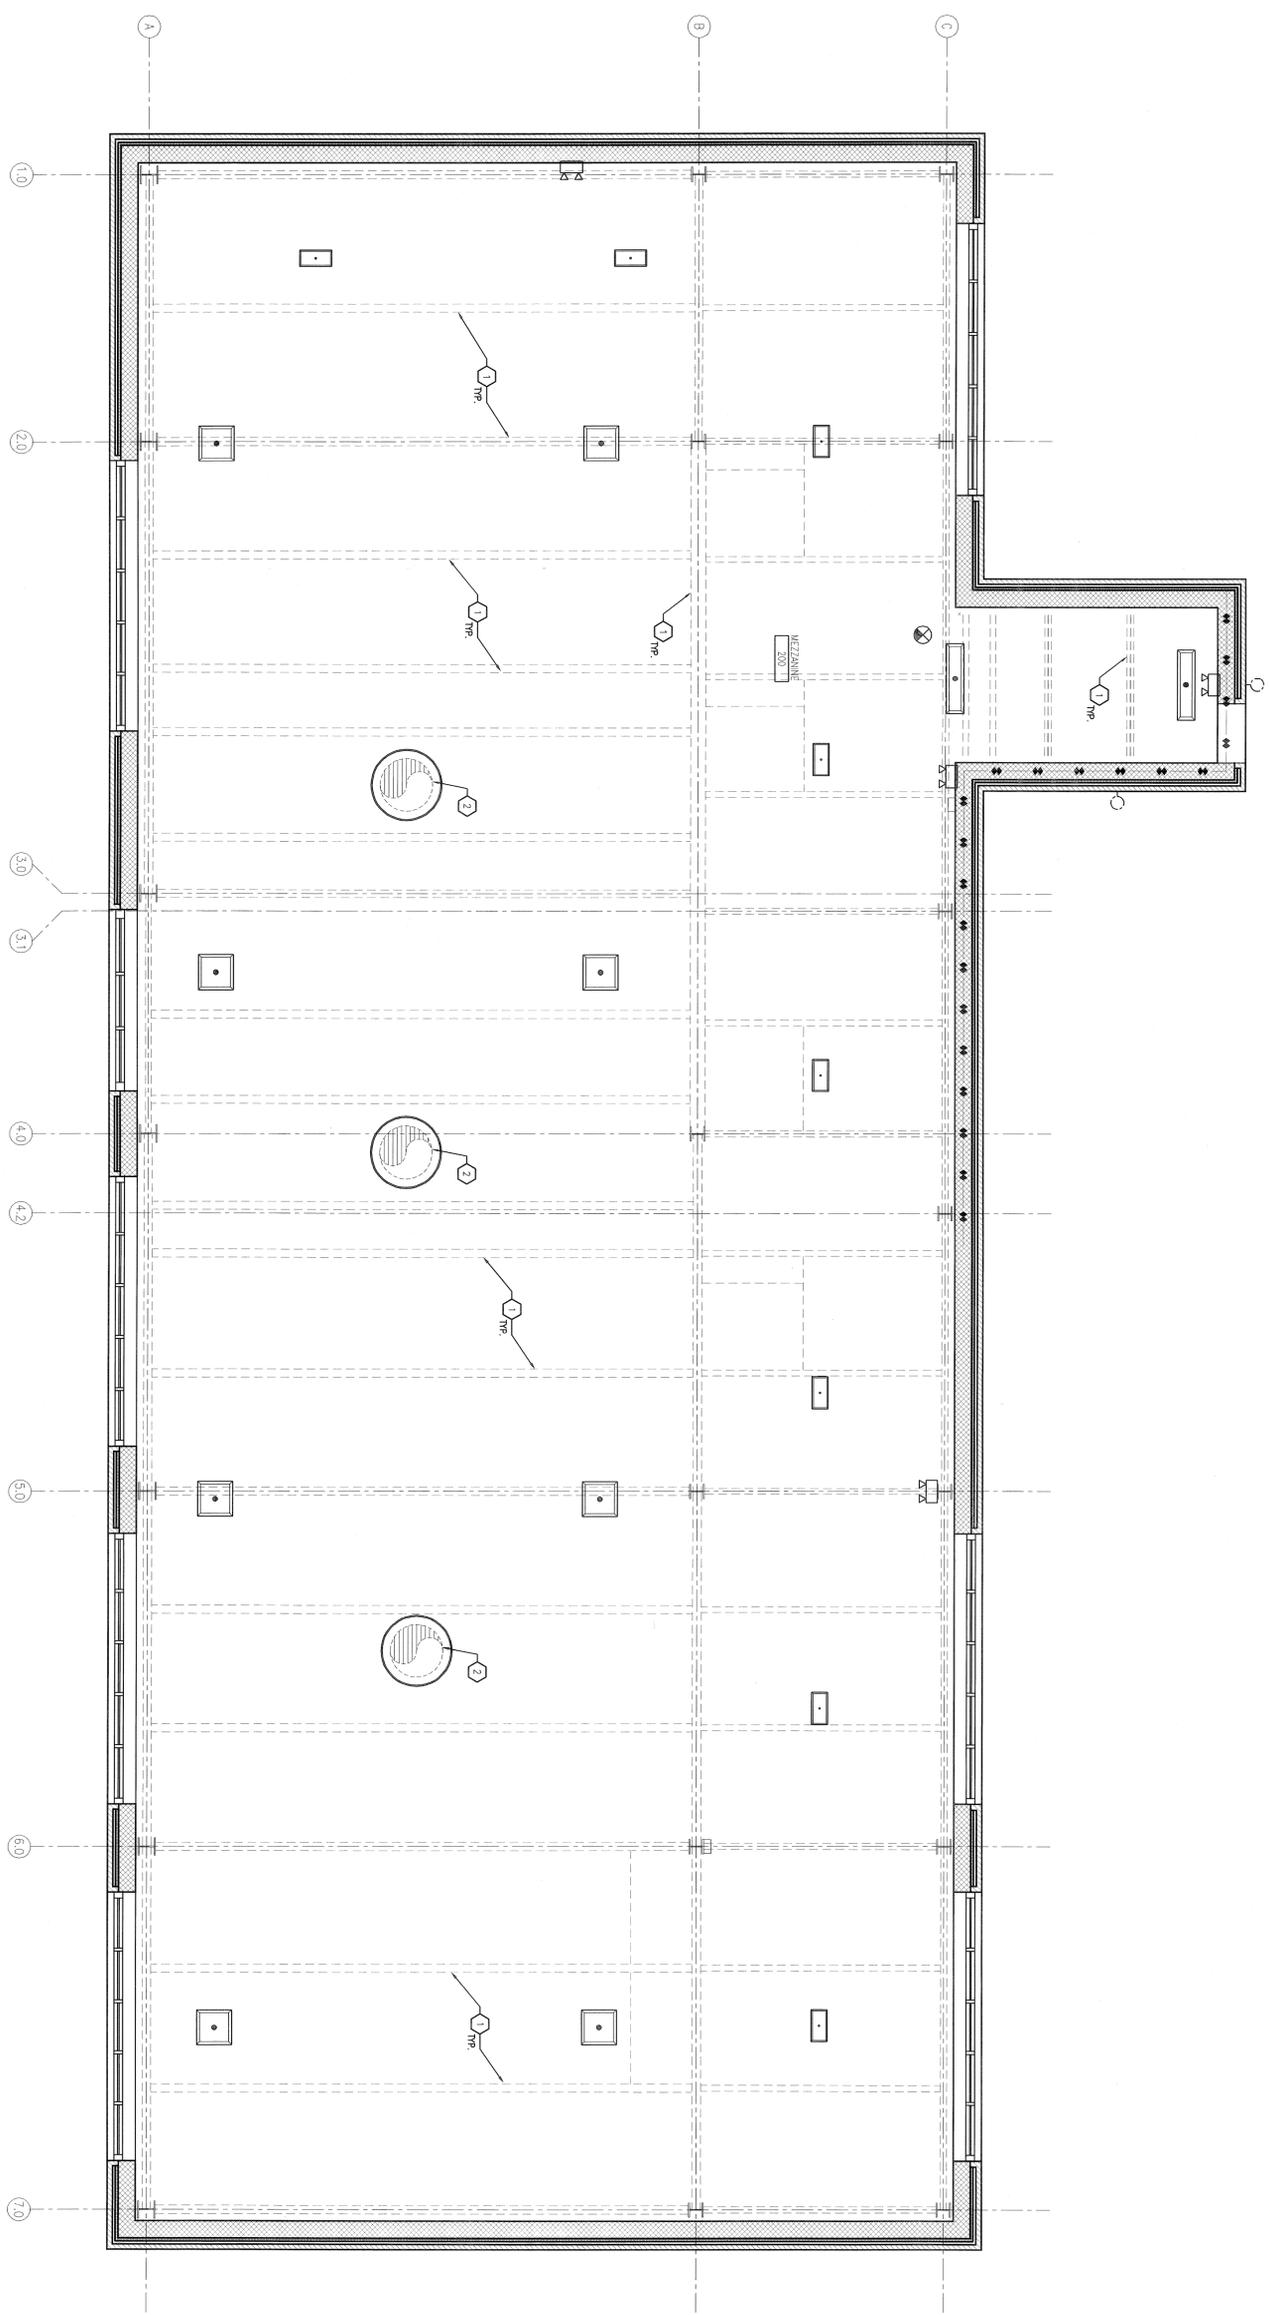

WALL TYPES LEGEND

	(2) HOUR FIRE BARRIER
	CALL SEE ARCHITECTURAL PLANS FOR SIZES

COORDINATION DRAWINGS

THE MECHANICAL CONTRACTOR SHALL TAKE THE LEAD IN PREPARATION OF COORDINATION DRAWINGS. SUCH DRAWINGS SHALL BE ARRANGED AND DESIGNED THROUGH AND FROM THE MECHANICAL CONTRACTOR'S OFFICE. THE ARCHITECT SHALL REVIEW AND APPROVE ALL COORDINATION DRAWINGS. THE MECHANICAL CONTRACTOR SHALL BE RESPONSIBLE FOR THE GENERAL COORDINATION OF ALL MECHANICAL SYSTEMS AND EQUIPMENT. ALL MECHANICAL SYSTEMS SHALL BE COORDINATED WITH ALL OTHER SYSTEMS (ELECTRICAL, PLUMBING, ETC.) AND SHALL BE SHOWN IN THE MECHANICAL CONTRACTOR'S DRAWINGS. ALL MECHANICAL SYSTEMS SHALL BE COORDINATED WITH ALL OTHER SYSTEMS (ELECTRICAL, PLUMBING, ETC.) AND SHALL BE SHOWN IN THE MECHANICAL CONTRACTOR'S DRAWINGS. ALL MECHANICAL SYSTEMS SHALL BE COORDINATED WITH ALL OTHER SYSTEMS (ELECTRICAL, PLUMBING, ETC.) AND SHALL BE SHOWN IN THE MECHANICAL CONTRACTOR'S DRAWINGS.

NOTES:

- FOR ARCHITECTURAL SYMBOLS SEE DRAWING A2002.
- FOR ELECTRICAL SYMBOLS SEE DRAWING E201.

DRAWING KEYNOTES

- STEEL FRAMING - SEE STRUCTURAL
- BOILER STACK - SEE MECHANICAL