


MAP SHOWING WHERE THE 1" PVC LINES WILL RUN

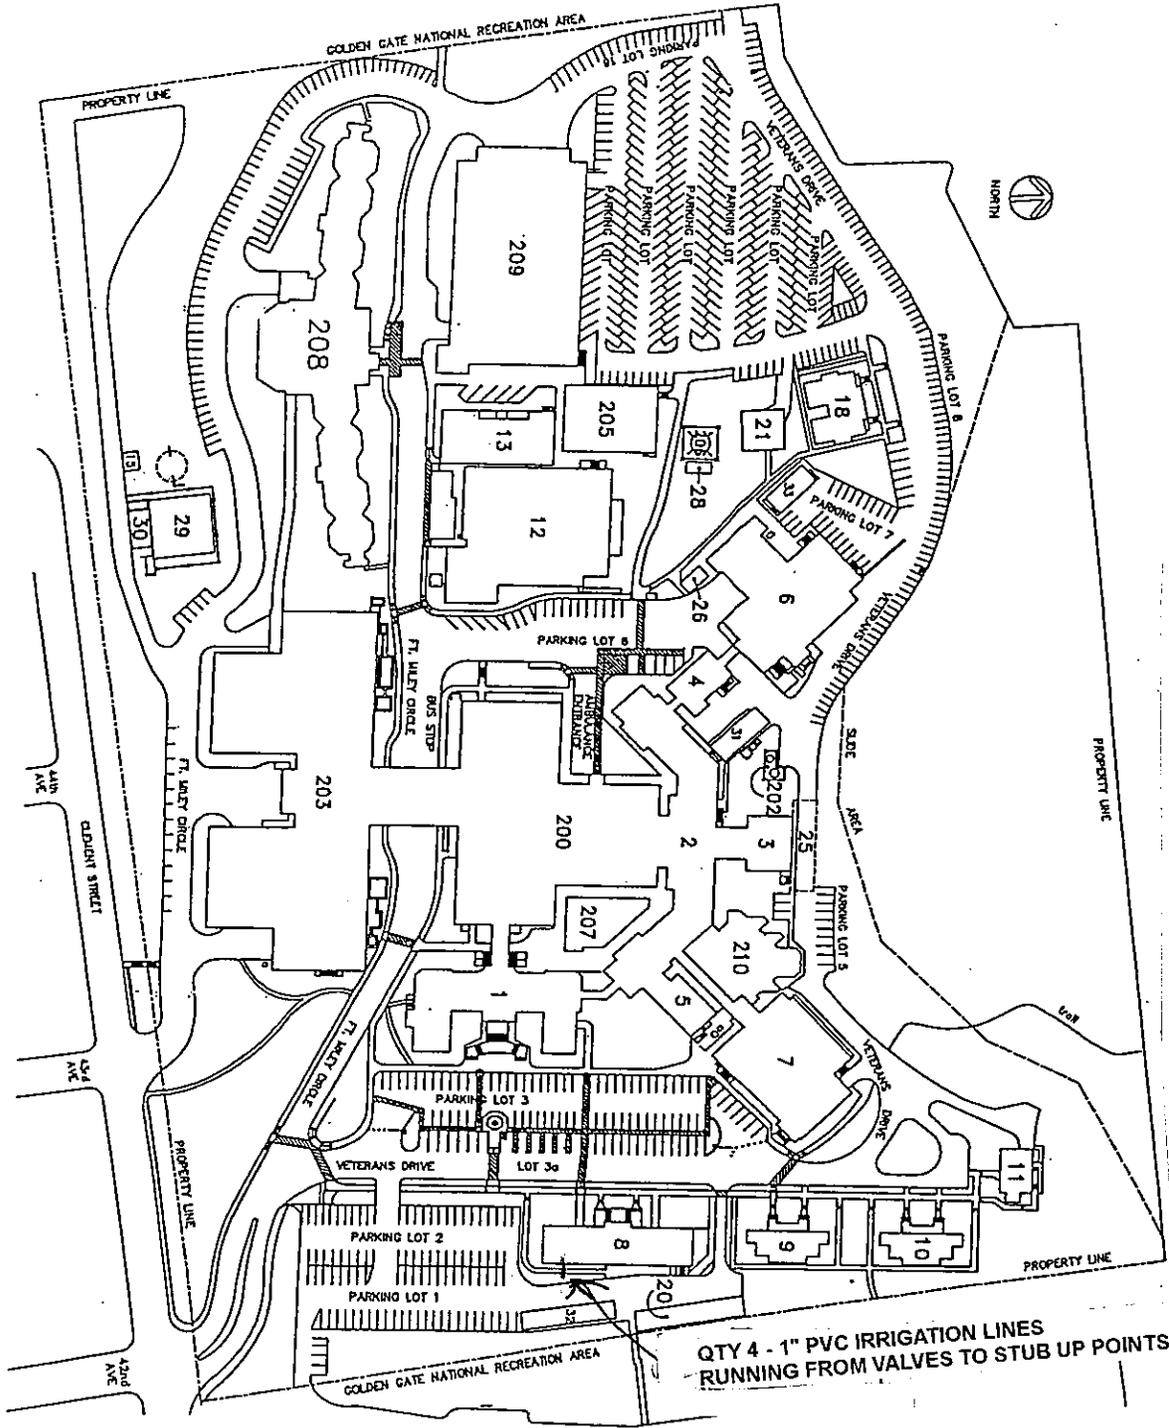

QTY 4 - 1" PVC IRRIGATION LINES  
RUNNING FROM VALVES TO STUB UP POINTS

VAMC  
Veterans Administration  
Medical Center  
4150 Clement Street  
San Francisco, CA 94121  
(415) 221-4810

BUILDG	OCCUPANCY
1	AUDIOLOGY/PERSONNEL/RESEARCH
2	ADMINISTRATION/LABORATORY
3	ENGINEERING
4	RESEARCH ADMINISTRATION
5	PROSTHETIC RESEARCH
6	SUPPLY/ISSUE/RESEARCH
7	CANTINE/CHAPEL/AUDITORIUM
8	MENTAL HEALTH RESEARCH
9	SATELLITE CLINIC
10	QUARTERS
11	RESEARCH
12	RESEARCH SHOPS/RESEARCH
13	STORAGE
15	RESEARCH ADMINISTRATION
18	CARAGE AND STORAGE
20	ANIMAL HOUSE
21	ENGINEERING SHOPS
25	ENGINEERING SHOPS
26	STORAGE
28	GTE
29	RESERVOIR
30	PUMPING STATION
31	SAFETY
32	CHILD CARE CENTER
33	MENTAL HEALTH
200	CLINICS/EMERGENCY/SURGERY
202	OXYGEN STORAGE
203	HOSPITAL
205	POWER PLANT
206	WATER TOWER
207	DHQP COMPUTER FACILITY
208	NHCO
209	PARKING STRUCTURE
210	REGIONAL COUNSEL

DRAWING TITLE	PROJECT TITLE	DATE
SITE PLAN	VAMC BLDGS, PARKINGS AND PEDESTRIANS	8-23-88
		DRAWING NO.
		1