



three inches = one foot
 one and one-half inches = one foot
 one inch = one foot
 three-quarters inch = one foot
 one-half inch = one foot
 three-eighths inch = one foot
 one-quarter inch = one foot
 one-eighth inch = one foot

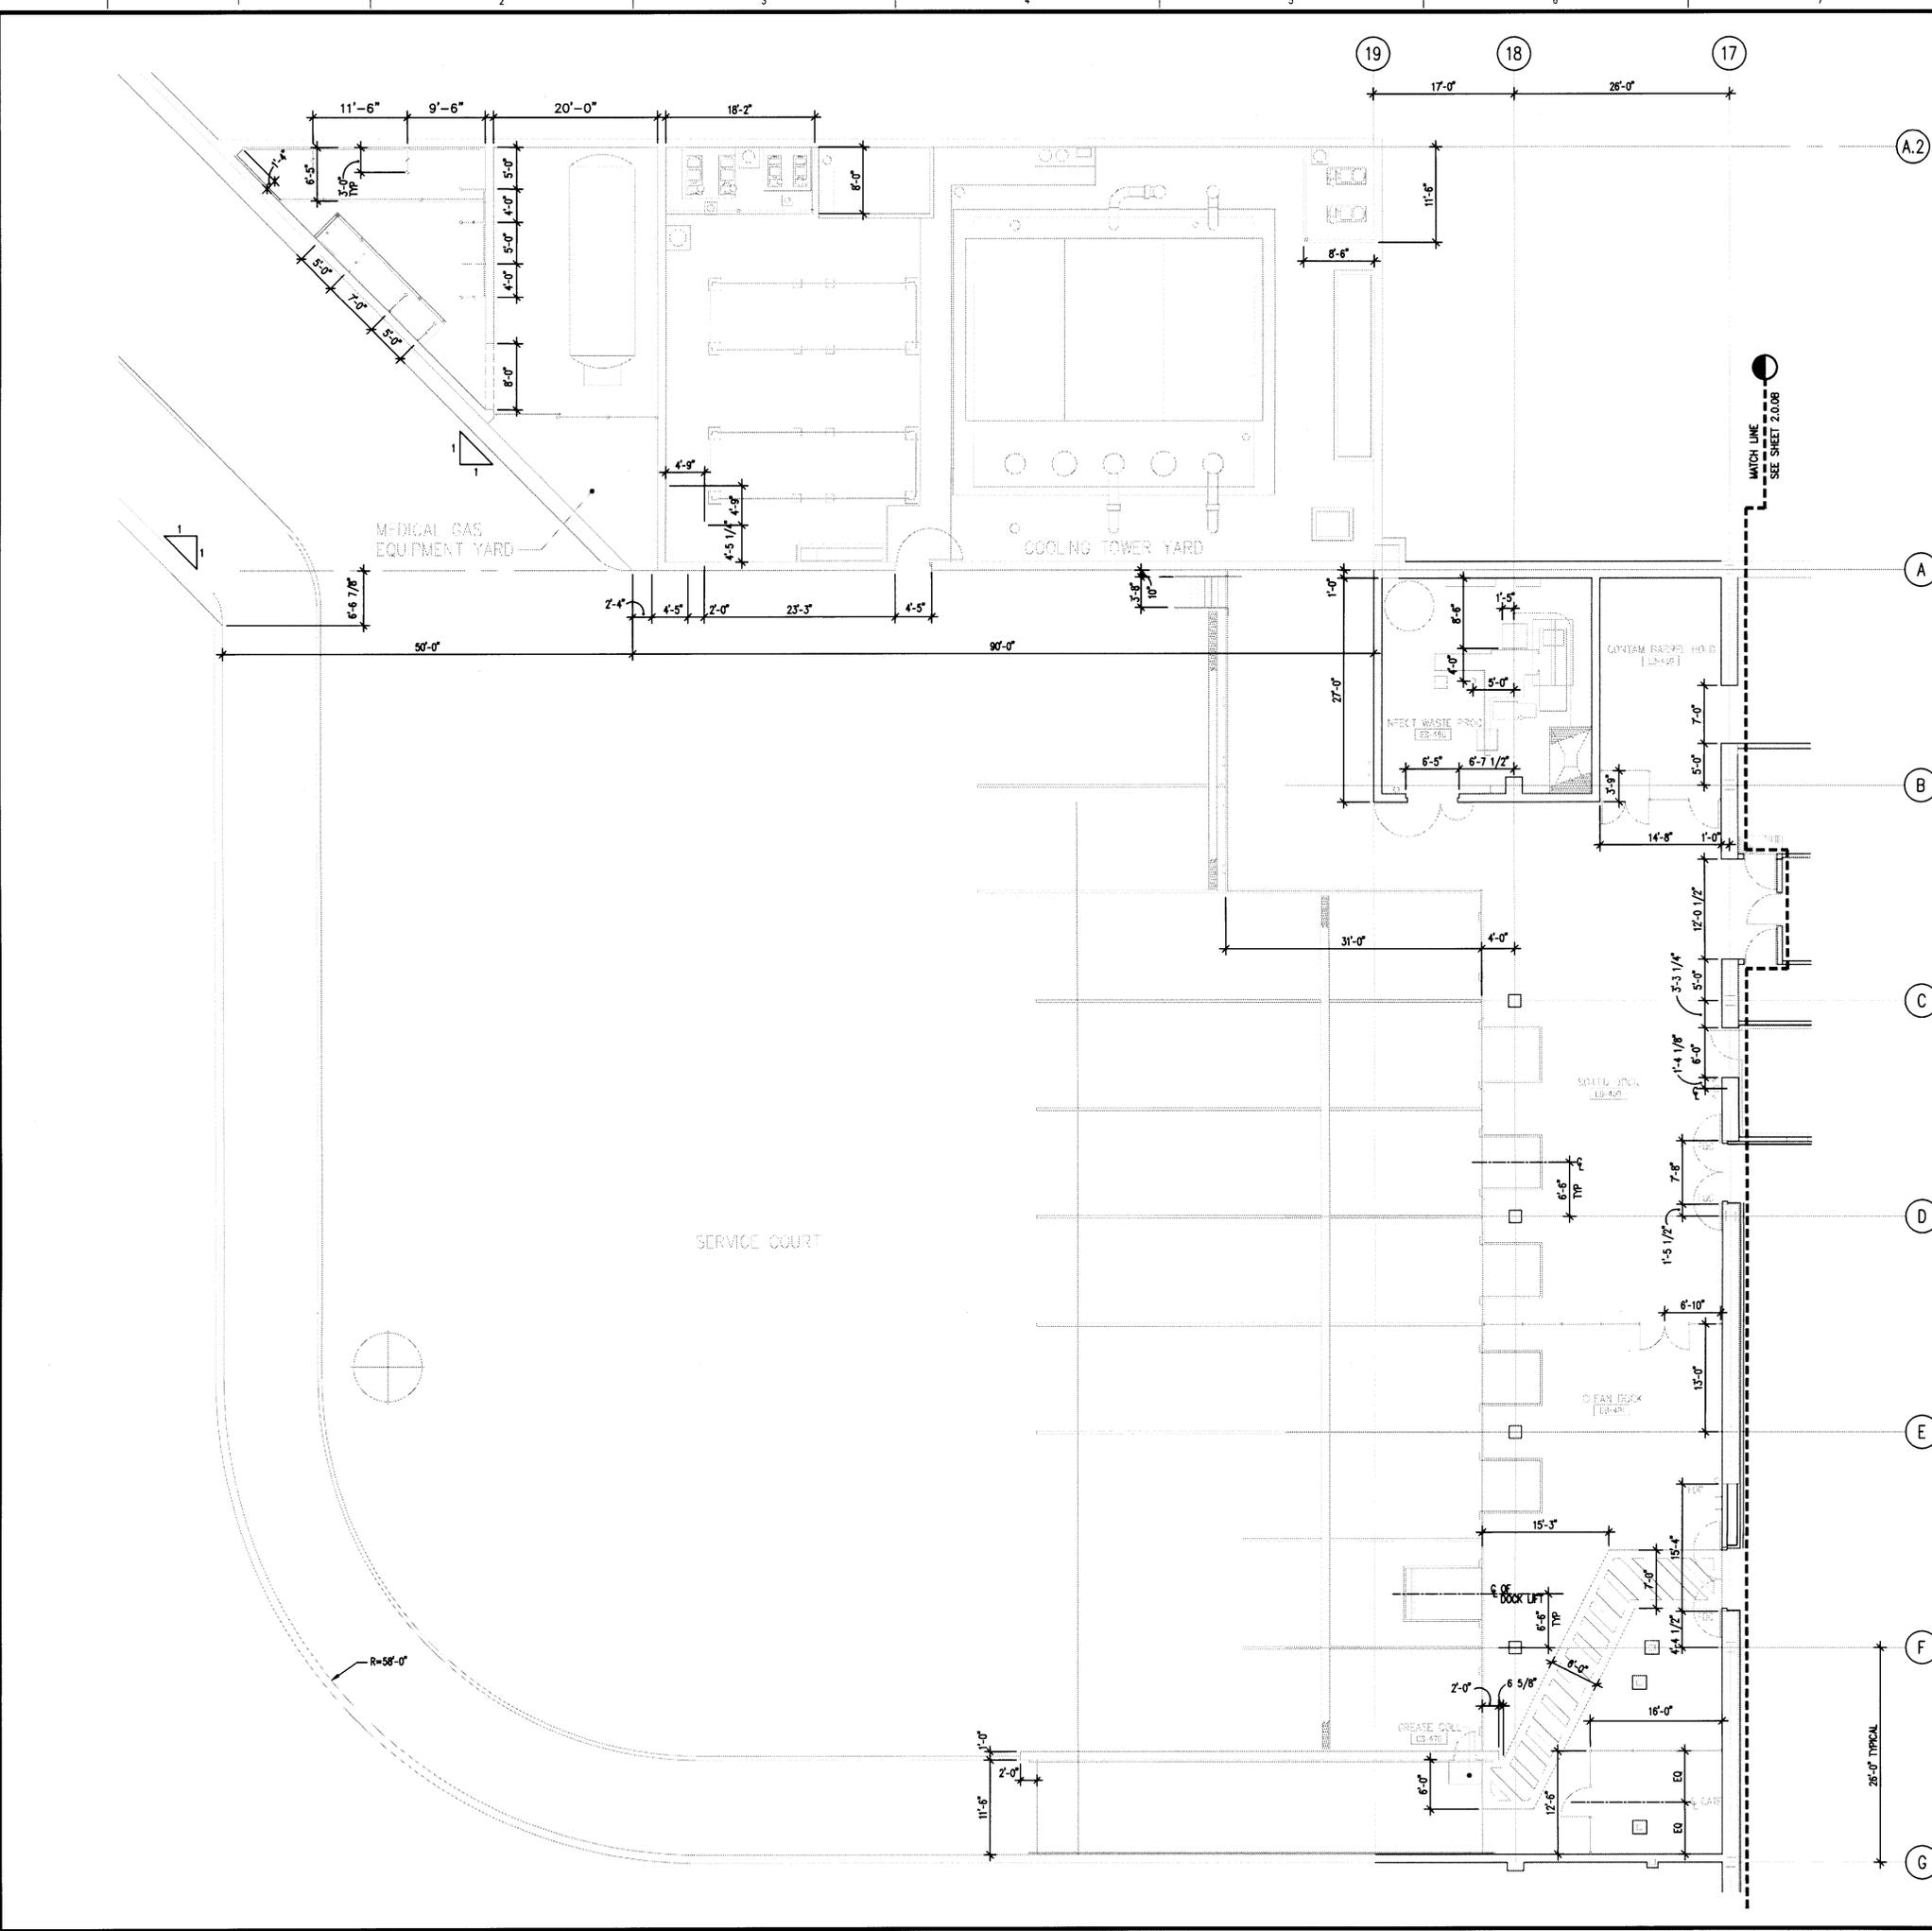

NOTE:
 FOR BASIC FIRE PROTECTION DIAGRAMS,
 SEE FIRE PROTECTION PLANS, FP PREFIX
 DRAWINGS. FOR SPECIFIC PARTITION TYPES
 SEE ARCHITECTURAL DIMENSION PLANS.

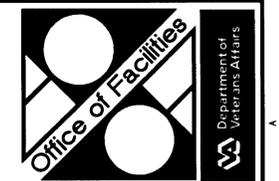

Thomas C. Aglin
 Western Team Director
 Approved Project Director

ARCHITECT
 The Ratcliff Architects
 5856 Doyle Street
 Emeryville, CA 94608
 P.O. Box 1022
 Berkeley, CA 94701
 (510) 662-1972

ASSOCIATE ARCHITECT
 Stone, Marraccini and Patterson
 One Market Plaza
 Spear Street Tower, Suite 400
 San Francisco, CA 94105
 (415) 227-0100

CONSULTANTS
 Structural Engineers
 H.J. Degenkolb Associates
 Mechanical Engineers
 Capital Engineering Consultants, Inc.

Electrical Engineers
 The Engineering Enterprise
 Cost Estimator
 Adamson Associates


Landscape Design/
 Land Planning
 Omi Lang Associates, Inc.

Civil Engineer
 Sandra Humber Jones

Elevator Consultant
 Syska and Hennessy

Fire Protection
 Rolf Jensen and Associates

Food Service Consultant
 Cim-Little International, Inc.

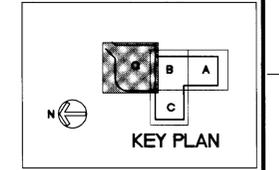

NOTES:
 1. SEE GENERAL ARCHITECTURAL
 NOTES, DWG X0.3.0.

Revisions	Date

Location
 VA Medical Center
 Palo Alto, CA

Project Title
**REPLACE CLINICAL/
 BED TOWER FOR
 SEISMIC CORRECTIONS**

FULLY SPRINKLERED

TRA Project No. 93007	Checked	Drawn
--------------------------	---------	-------

Drawing Title
**LOADING DOCK
 DIMENSION PLAN
 AREA G**

Scale 1/8" = 1'-0"

VA Project No.
 640-042G

Date
 2 MAY 94

Building Number
 100
 DRAWING NO.
2.01G