

A

B

C

D

E

F

A

B

C

D

E

F

GENERAL DEMOLITION NOTES


- 1. MEDICAL GAS, AIR, OXYGEN, AND NATURAL GAS LINES ARE LIVE AND FEED OPERATIONAL AREAS OF THE MEDICAL CENTER. COORDINATE ALL DEMOLITION WORK AND OUTAGES WITH THE RESIDENT ENGINEER.

DEMOLITION KEYED NOTES

- ① REMOVE ALL DENTAL CHAIR PIPING FEEDS BELOW THE FLOOR BACK TO MAIN, FILL FLOORING OPENINGS.
- ② REMOVE EXISTING DENTAL NATURAL GAS, OXYGEN AND COMPRESSED AIR VALVES, FITTINGS, AND ALL RELATED PIPING. CAP PIPING AT MAINS.
- ③ REMOVE MEDICAL AIR VALVE BOX & FEEDS BACK TO MAIN. CONTRACTOR TO TRACE AND LOCATE MEDICAL GAS AND OXYGEN PIPING LOCATIONS (UP TO 50LF) IN EACH DIRECTION BACK TO MAIN SHUTOFF OR DISCONNECT. CAP PIPING AT MAINS.
- ④ REMOVE MEDICAL AIR OUTLETS & FEEDS BACK TO MAIN. CONTRACTOR TO TRACE AND LOCATE MEDICAL GAS AND OXYGEN PIPING LOCATIONS (UP TO 50LF) BACK TO MAIN SHUTOFF OR DISCONNECT. CAP PIPING AT MAINS.


LEGEND

- MEDG+ MEDICAL GAS
- NGAS+ NATURAL GAS
- VAC. + MEDICAL VACUUM
- OXY. + MEDICAL OXYGEN
- |— MEDICAL AIR BALL VALVE
- DM WTR+ DOMESTIC COLD WATER LINE

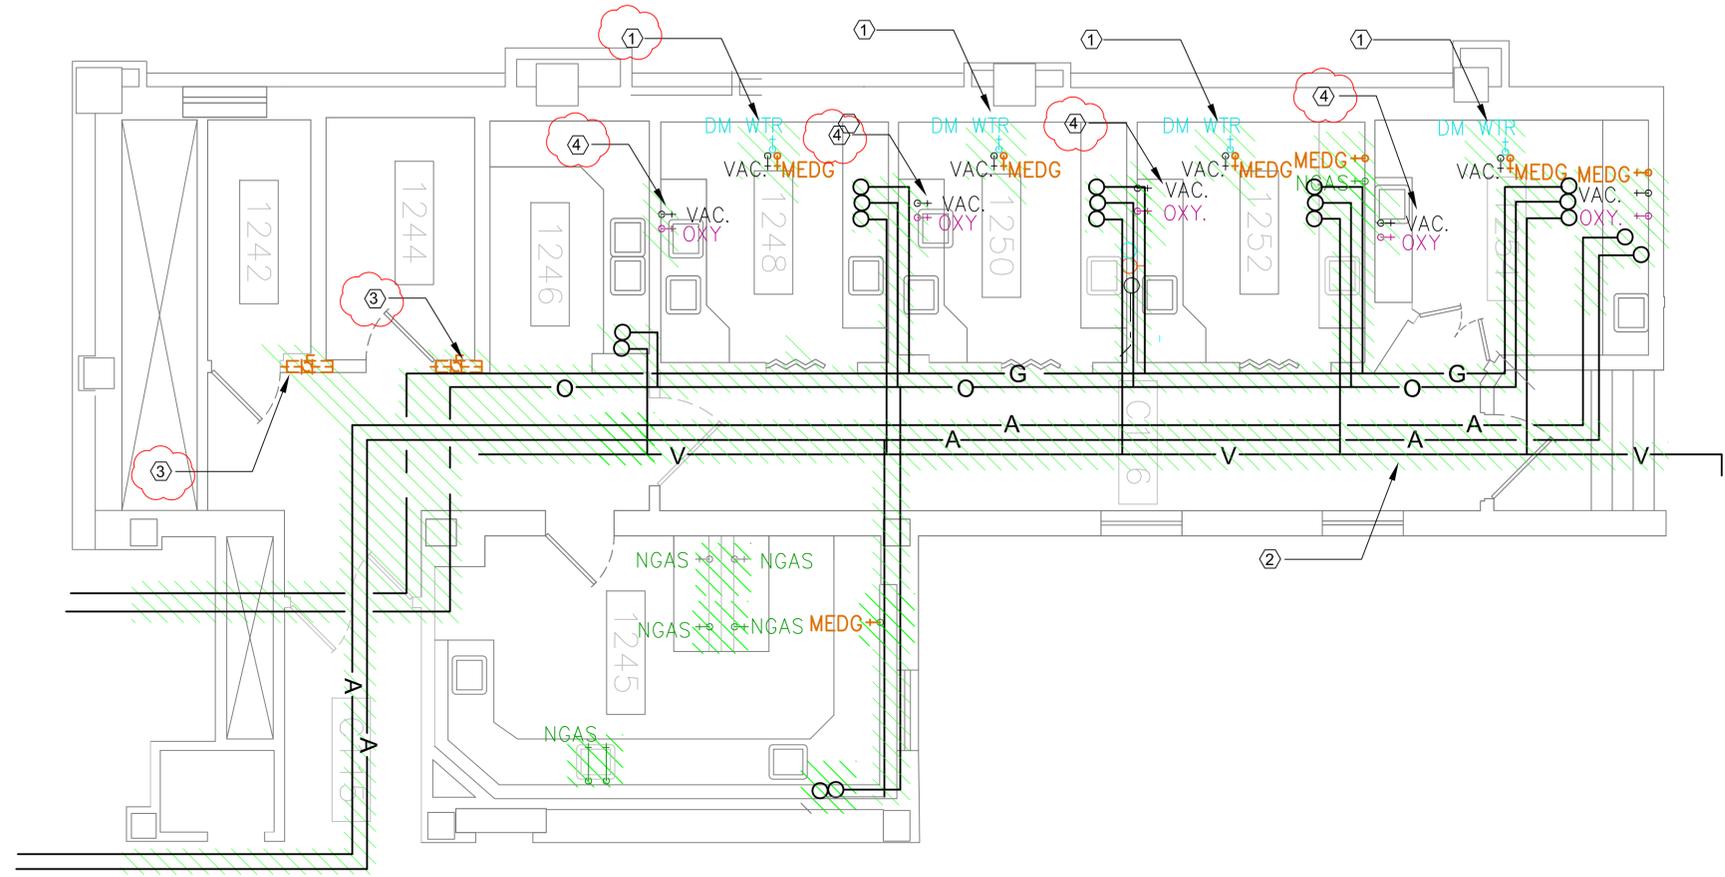

1 PLUMBING PLAN - FIRST FLOOR (NEW LOCATION)

 SCALE 1/4" = 1'-0"



BID SET

Revisions: Date	Ammendment #003 17 Mar 2014	CONSULTANTS:	ARCHITECT/ENGINEERS: VA Central Iowa HCS Office of Engineering and Facility Management Engineer: Troy Martinson, PE Designer: Jeff McDonald	Drawing Title: MEDICAL GAS DEMOLITION PLAN		Project Title: Relocate Histology Lab		Project Number: 636A6-14-101SL		Engineering Office VA Des Moines CIHCS	
	Approved (Project Director): Roger Fry			Location: VA Central Iowa HCS, Des Moines, IA		Building Number: 1		Drawing Number: PD-102			
	Date: 3-17-2013			Checked: RF		Drawn: TJM		Dwg. 34 of 48			
	VA FORM 08-6231							Department of Veterans Affairs			

S:\DC\Engineering\Construction Projects\2014 Project\Files\NRM\636A6-14-101SL Relocate Histology Lab\01-Design\01-Drawings\PD-102 Plumbing Demolition Plan.dwg 3-11-14 07:10:42 PM VJACHMartini