



TOPOGRAPHIC SURVEY

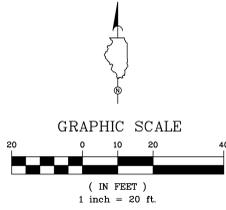

- LEGEND AND ABBREVIATIONS:**
- BUILDING
 - CONCRETE
 - ASPHALT
 - DEPRESSED CURB
 - CHAIN LINK FENCE
 - IRON FENCE
 - WOOD FENCE
 - GUARDRAIL
 - FOUND PK NAIL
 - FOUND REBAR
 - SET MAG NAIL
 - SET/FOUND CUT CROSS
 - COMBINATION SEWER
 - SANITARY SEWER
 - STORM SEWER
 - WATER LINE
 - GAS LINE
 - COMMUNICATION LINE
 - SBC COMMUNICATION LINE
 - TELEPHONE LINE
 - OVERHEAD WIRE LINE
 - UNDERGROUND ELECTRIC LINE
 - BACK OF CURB ELEVATION
 - FLOW LINE ELEVATION
 - EDGE OF PAVEMENT ELEVATION
 - FINISH FLOOR ELEVATION
 - MANHOLE
 - WATER MANHOLE
 - ELECTRIC MANHOLE
 - TELEPHONE MANHOLE
 - CURB INLET
 - CATCH BASIN
 - AREA DRAIN
 - POWER POLE W/GUY WIRE
 - UTILITY POLE
 - LIGHT POLE
 - FIRE HYDRANT
 - GAS VALVE
 - GAS METER
 - ELECTRIC METER
 - BUFFALO BOX
 - WATER VALVE
 - TREE-DECIDUOUS
 - TREE-EVERGREEN
 - BUSH
 - POST
 - SIGN
 - BOLLARD
 - SPRINKLER
 - CLEANOUT

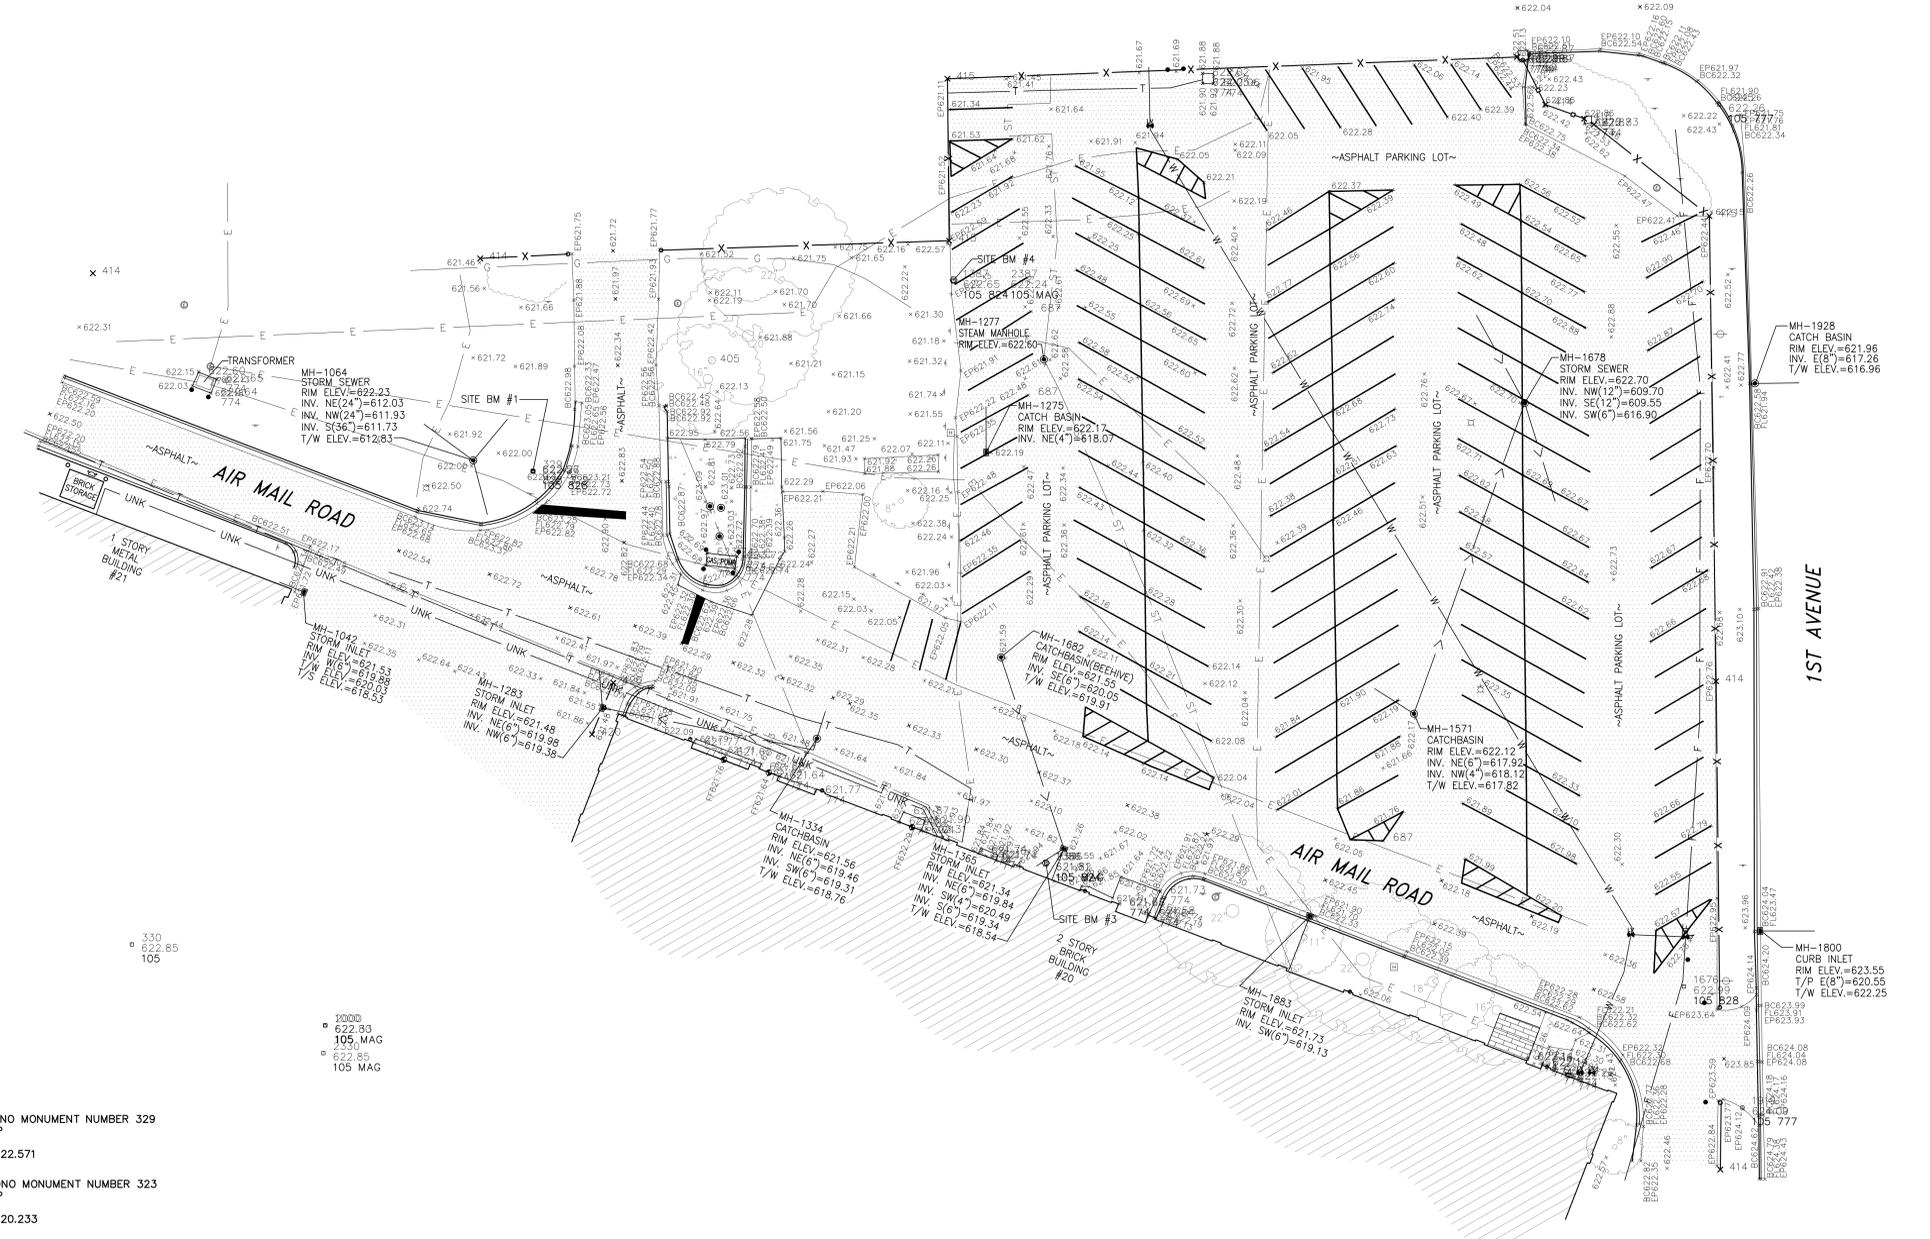

three inches = one foot
 one and one-half inches = one foot
 one inch = one foot
 three-quarters inch = one foot
 one-half inch = one foot
 three-eighths inch = one foot
 one-quarter inch = one foot
 one-eighth inch = one foot

BM # 1 CARDNO MONUMENT NUMBER 329
 REBAR & CAP
 Elevation = 622.571

BM # 2 CARDNO MONUMENT NUMBER 323
 REBAR & CAP
 Elevation = 620.233

SITE BM # 3 MAG NAIL (NOTED ON PLAT)
 Elevation = 621.32

SITE BM # 4 MAG NAIL (NOTED ON PLAT)
 Elevation = 622.24

STATE OF ILLINOIS
 COUNTY OF COOK

 This is to certify that I, an Illinois Professional Land Surveyor, have surveyed the property described in the caption above, and that this Professional service conforms to the current Illinois Minimum Standards for a topographic survey.
 Given under my hand and seal in Chicago, Illinois, this 23rd day of September, 2013.

THOMAS E. BAUMGARTNER, ILLINOIS LAND SURVEYOR NO. 3142
 LICENSE EXPIRATION 11-30-2014
 Field work completed September 18, 2013.



NOTE: TERRA ENGINEERING does not guarantee the accuracy of this survey unless it contains an original seal and signature.

TERRA ENGINEERING LTD.
 225 W. Ohio Street
 4th Floor
 Chicago, IL 60654
 TEL: (312) 467-0123
 FAX: (312) 467-0220
 www.terraengineering.com


Project Information
 PROJECT #: 13-217
 DRAWN BY: BM/KR
 DESIGN BY: TB
 CHECKED BY: TB

 I FURTHER STATE that the accompanying plat is a scaled representation of the physical situation which I found in the field and shows the location of visible evidence of utilities which I found at the time of my survey of these premises, and underground based on supplied plans. No attempt has been made as part of this survey to excavate, uncover or expose those facilities to field check the existence, size, depth, condition, capacity or exact location of those facilities. For more information concerning those utilities, please contact the appropriate public agencies or utility company.

CANNONDESIGN

225 North Michigan Avenue, Suite 1100, Chicago, Illinois 60601 312.332.9600
 Baltimore Boston Buffalo Chicago Jacksonville Los Angeles New York
 St. Louis Vancouver Washington DC

Approved: _____
 Chief, FMS: _____
 Chief of Projects: _____
 Chief of Safety: _____
 Chief of Staff: _____
 ED Director: _____
 Infection Control: _____

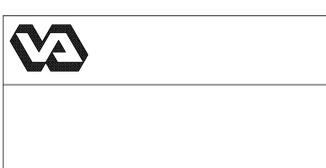

Drawing Title
VA HINES FUELING STATION

 Approved: Chief of Engineering _____ Date _____
 Approved: Director _____ Date _____

Project Title
**E-85 FUEL STATION BUILDING 20
 EDWARD HINES, JR.
 VA HOSPITAL**

 Building Number & Floor
BUILDING 20 - SITE PLAN
 Checked _____ Drawn _____
 Location **2100 S 5th Ave #111L
 Hines, IL 60141**

Date **01/31/14**
 Project No. **VA 701-123-R-0103**
 DRAWING NO. **C0.2**

DEPARTMENT OF VETERANS AFFAIRS

| | |
|-----------|------------------------|
| 9 | |
| 8 | |
| 7 | |
| 6 | |
| 5 | |
| 4 | |
| 3 | |
| 2 | |
| 1 | ISSUED FOR BID 1.31.14 |
| Revisions | Date |