


SHEET NOTES

1.

SHEET KEYNOTES


1. PROVIDE EMPTY 1" C FROM J-BOX ABOVE CEILING TO SIGNAL CLOSET 2C207 FOR CONNECTION TO DATA DEVICES IN CEILING MOUNTED UTILITY BOOM.
2. PROVIDE EMPTY 1" C FROM J-BOX ABOVE CEILING STUBBED OUT IN CORRIDOR FOR CONNECTION TO DATA DEVICES IN CEILING MOUNTED UTILITY BOOM.

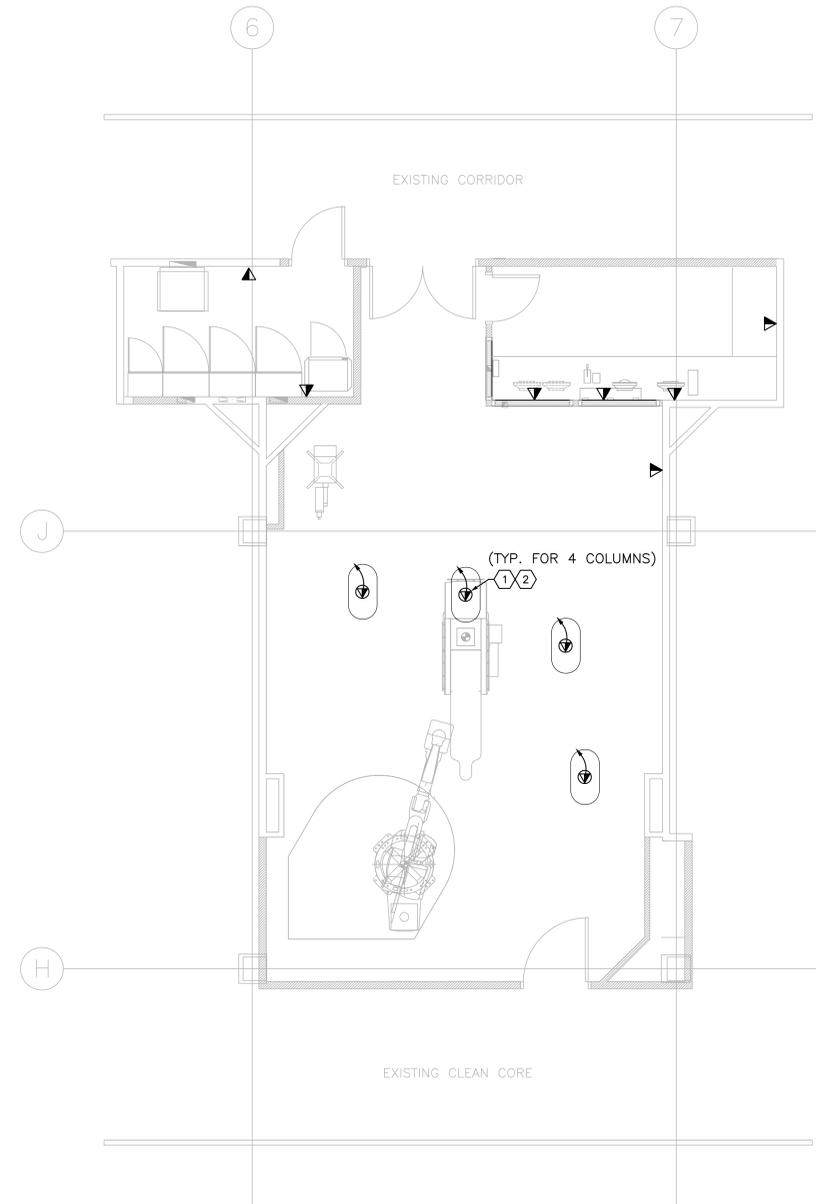

1 ELECTRICAL SYSTEMS PLAN
SCALE: 1/4" = 1' - 0"




BUILDING C - 2ND FLOOR
KEY PLAN

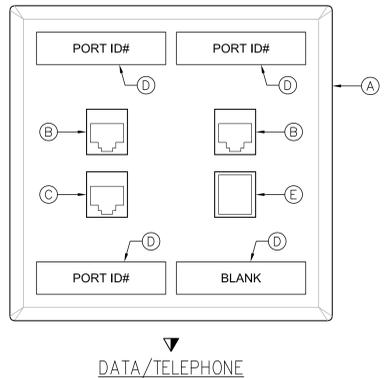

- OUTLET KEY NOTES:
- (A) COMMUNICATIONS FACEPLATE, SEE SPECIFICATIONS.
 - (B) "DATA" SNAP-IN COUPLER WITH 8-PIN MODULAR JACK ASSEMBLY, COLOR PER VA. PROVIDE TWO PER EACH DATA OR DATA/PHONE OUTLET. REFER TO SPEC'S FOR WIRING/TERMINATION REQUIREMENTS.
 - (C) "VOICE" SNAP-IN COUPLER WITH 8-PIN MODULAR JACK ASSEMBLY, COLOR PER VA. PROVIDE ONE PER EACH PHONE OR DATA/PHONE OUTLET. REFER TO SPEC'S FOR WIRING/TERMINATION REQUIREMENTS.
 - (D) COMMUNICATIONS OUTLET IDENTIFIER (COORD. WITH VA FOR EXACT NOMENCLATURE) ON LASER PRINTED INSERT UNDER FACTORY PLASTIC COVER.
 - (E) COLORED BLANK TAB OR JACK. COORDINATE COLOR WITH VA BEFORE PURCHASING.

2 TYPICAL WALL MTD. TELECOM OUTLET DETAIL
SCALE: NONE

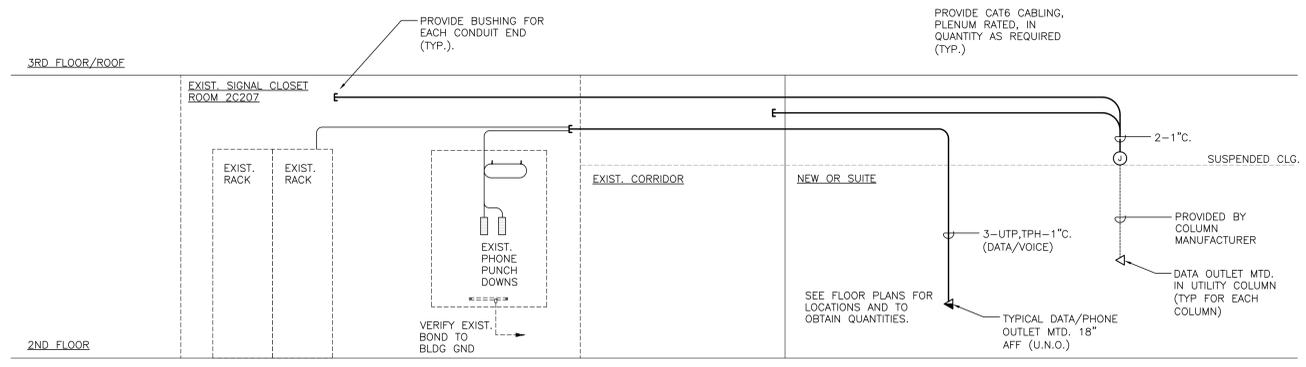

3 TELECOM RISER DIAGRAM
SCALE: NONE

FINAL SUBMITTAL
APPROVED FOR CONSTRUCTION

CONSULTANTS: Revisions: _____ Date _____	ENGINEER-OF-RECORD RANDALL A. HENSLEY GA. P.E. NO. 18607	ARCHITECT/ENGINEERS: AKEA INC. 3603 NW 98th Street, Suite B Gainesville, FL 32606 Phone: (352) 474-6124 Fax: (352) 474-6324 COA: FL #26693 AKEA Project No. 072-14	Drawing Title ELECTRICAL SYSTEMS PLAN	Project Title NEW SURGICAL 9TH OR SUITE	Project Number 508-14-105	Office of Construction and Facilities Management Department of Veterans Affairs	
			Approved: Project Director	Location Atlanta, Georgia	Building Number		Drawing Number E204

three inches = one foot
 one and one half inches = one foot
 one inch = one foot
 three quarters inch = one foot
 one half inch = one foot
 three eighths inch = one foot
 one quarter inch = one foot
 one eighth inch = one foot