


three inches = one foot
 one and one half inches = one foot
 one inch = one foot
 three quarters inch = one foot
 one half inch = one foot
 three eighths inch = one foot
 one eighth inch = one foot
 one quarter inch = one foot
 one eighth inch = one foot
 one eighth inch = one foot

- KEY**
- 1 EXISTING PANEL 69H SHALL BE RELOCATED TO MECHANICAL AREA 1-606. SEE 1/E-102 FOR NEW LOCATION.
 - 2 EXISTING KILNS TO BE RELOCATED. RECONNECT AS SHOWN ON E-102.
 - 3 EXISTING PANEL 69F TO REMAIN. SEE NOTES E-102.
 - 4 ELECTRICAL WIREMOLD OR WIRE TROUGH TO BE DEMOLISHED.
 - 5 AUTOMATIC DOOR OPENER TO BE DEMOLISHED.
 - 6 EXISTING EQUIPMENT IN ROOM TO REMAIN.
 - 7 PANIC ALARM TO DEMOLISHED AND TURNED OVER TO THE OWNER.
 - 8 ADA AUTOMATIC DOOR HARDWARE TO BE DEMOLISHED.
 - 9 DEMOLISH EXISTING SECURITY CAMERA. TO BE RELOCATED.
 - 10 DEMOLISH EXISTING AIR COMPRESSOR ELECTRICAL CONNECTION AT EXISTING LOADING DOCK.
- NOTE**

- 1ST FLOOR ELECTRICAL DEMOLITION PLAN NOTES:**
1. DEMOLISH ALL ELECTRICAL CONDUCTORS AND CONDUIT BACK TO PANELBOARD FOR ALL DEVICES. MARK EXISTING UNUSED OVERCURRENT PROTECTION DEVICES AS "SPARE". REVISE PANEL SCHEDULES TO REFLECT NEW WIRING.
 2. CONTRACTOR SHALL REUSE EXISTING FIRE ALARM DEVICES IF NOT DAMAGED DURING DEMOLITION.
 3. CONTRACTOR SHALL NOT LEAVE ANY UNUSED ELECTRICAL DEVICES ABANDONED IN PLACE. ALL ELECTRICAL DEVICES MUST BE REMOVED.
 4. EXISTING EQUIPMENT, SUCH AS LIGHTING FIXTURES, WIRING DEVICES, CONDUITS, ETC., TO BE REMOVED COMPLETELY. CUT/CAP CONDUITS AT THE AREA OF WORK PERIMETER AND REMOVE CONDUIT WITHIN THE WORK AREA. DISCONNECT WIRING AT THE OVERCURRENT PROTECTIVE DEVICE AND REMOVE WIRING COMPLETELY FROM THE ABANDONED CONDUITS.
 5. REMOVE ALL ACCESSIBLE ABANDONED WIRING OF ALL TYPES, OR CAP AND LABEL IN JUNCTION BOX FOR RE-USE, IN COMPLIANCE WITH THE NATIONAL ELECTRIC CODE.
 6. MAINTAIN AND RESTORE ANY EXISTING SYSTEMS THAT WILL REMAIN IN USE DURING DEMOLITION OR CONSTRUCTION. IF INTERRUPTED, ALL CONDUITS AND CONDUCTORS PASSING THROUGH RENOVATED AREAS AND SERVICING UNDISTURBED AREAS.
 7. CONTRACTOR IS RESPONSIBLE FOR ALL DEMOLITION. DEVICES SHOWN ARE NOT ALL INCLUSIVE. CONTRACTOR SHALL VERIFY IN FIELD EXTENT OF ALL DEMOLITION.

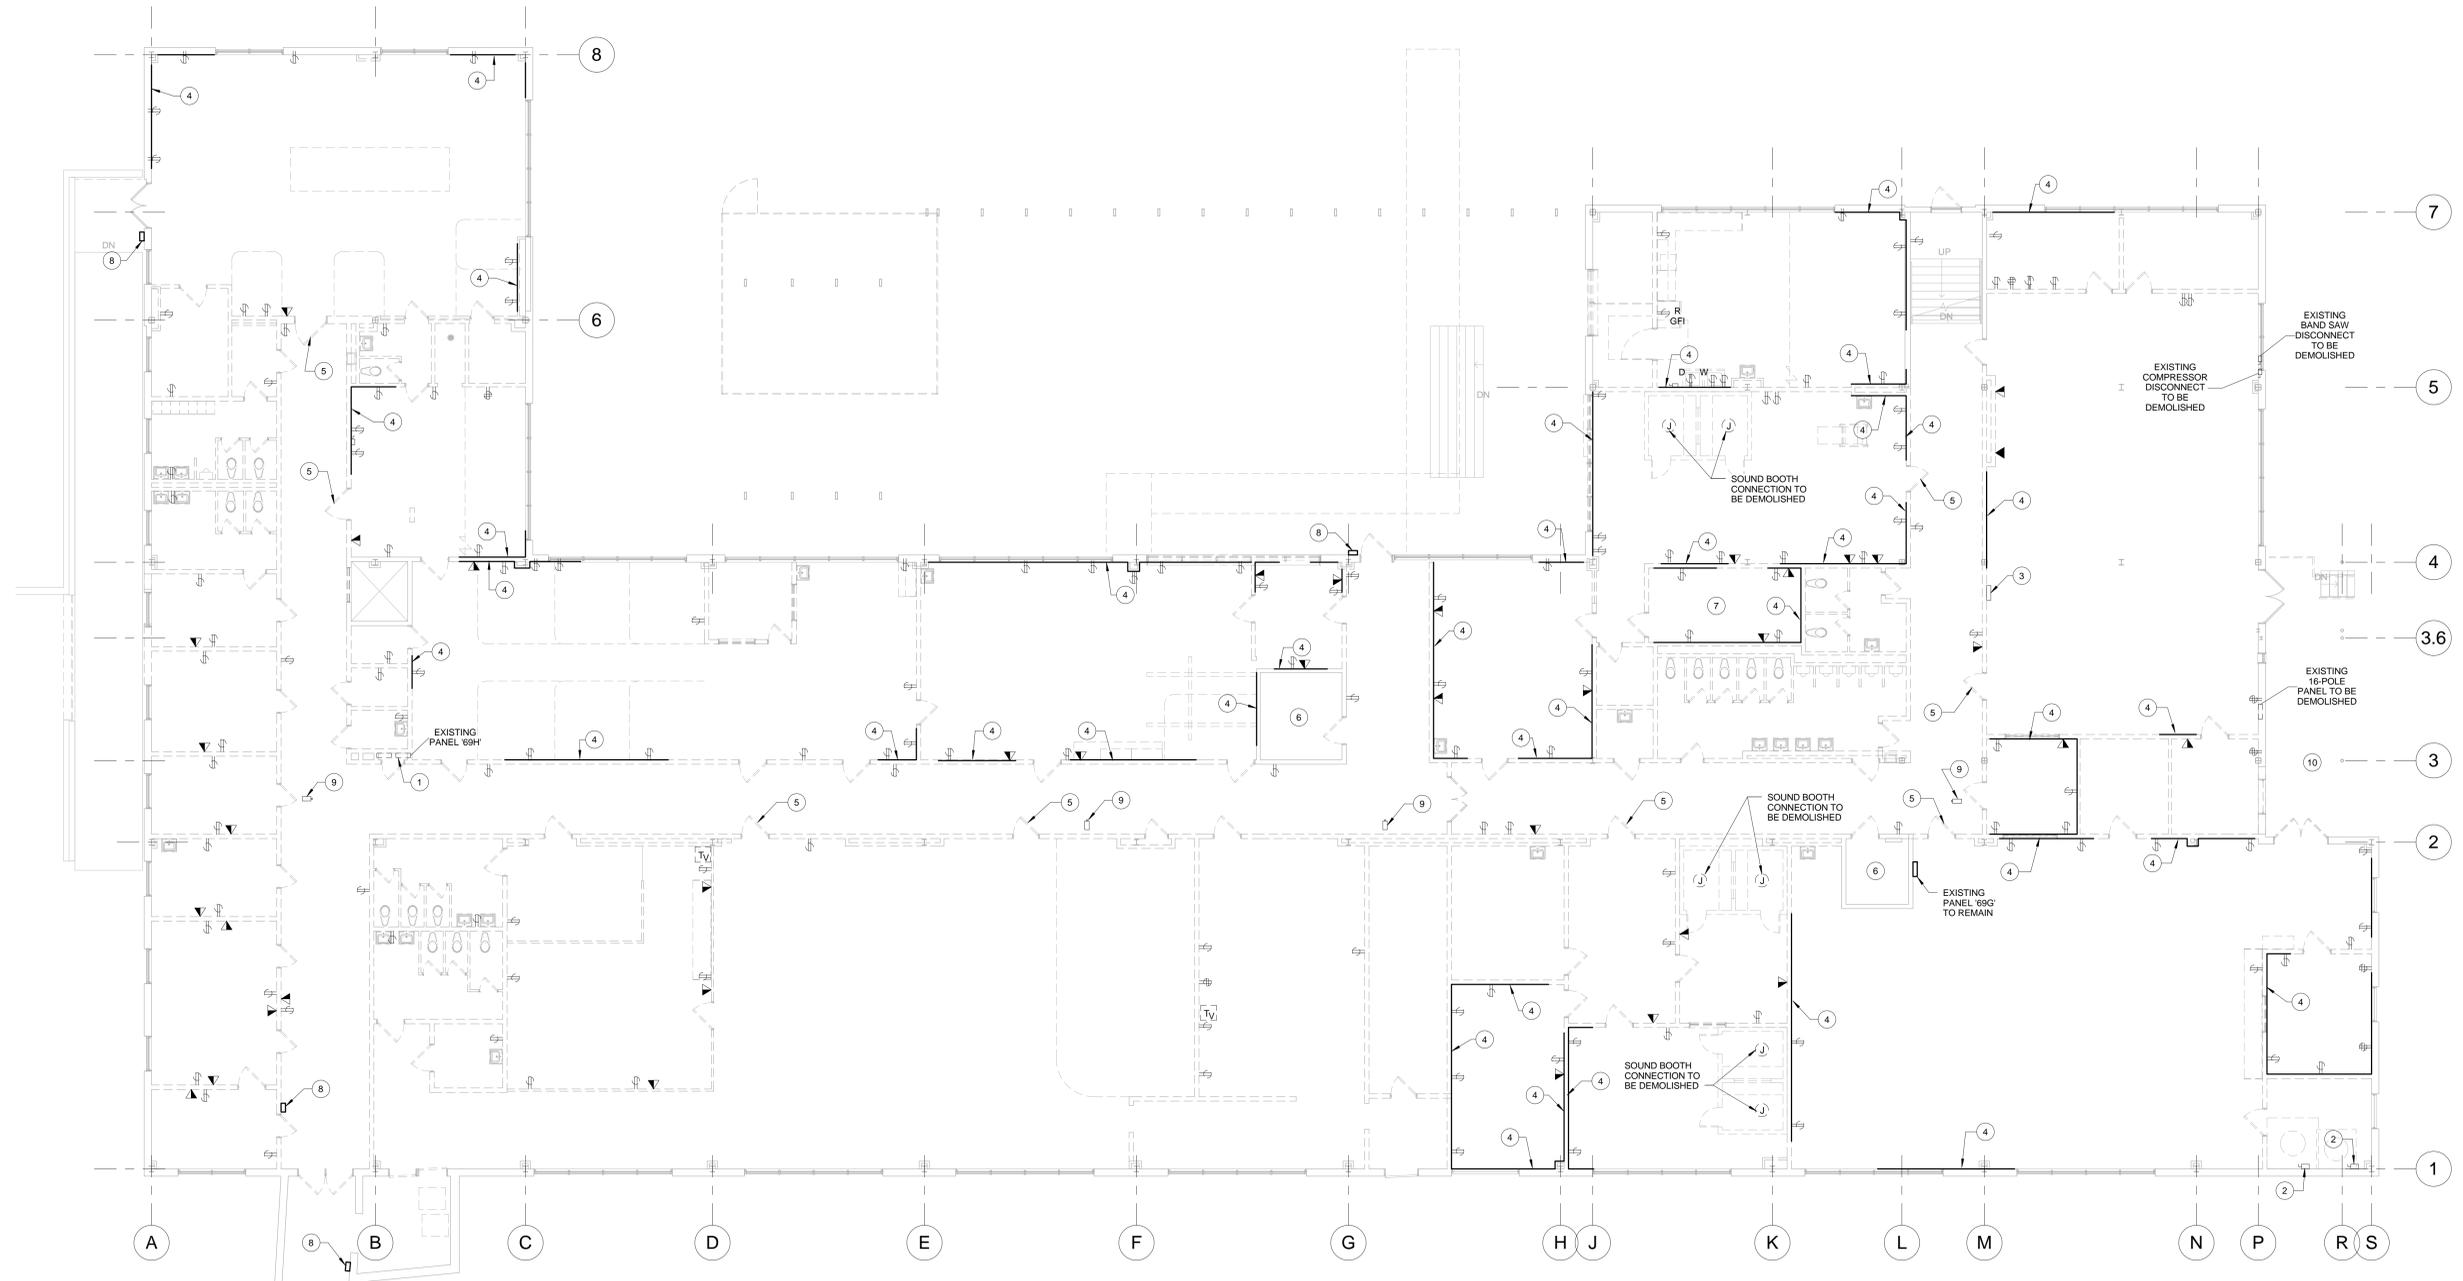

1 1ST FLOOR ELECTRICAL DEMOLITION PLAN
 1/8" = 1'-0"

FULLY SPRINKLERED
 ISSUED FOR BID

CONSULTANTS: Project Manager: BRAY MOONEY CONSULTING 410 E. 21 STREET, CHESTER, PA, 19013 Tel: (610) 872-3716		Architect: ARRAY HEALTHCARE FACILITIES SOLUTIONS 2530 RENAISSANCE BLVD., SUITE 110, KING OF PRUSSIA, PA, 19406 Tel: (610) 270-0599		Structural Engineer: WZG, STRUCTURAL CONSULTING ENGINEERS 180 W. RIDGE PIKE, LIMERICK, PA, 19468 Tel: (214) 329-9559		MEP/FP Engineer: APOGEE CONSULTING GROUP 7330 CHAPEL HILL ROAD, SUITE 202, RALEIGH, NC, 27606 Tel: (919) 859-7420		Civil Engineer: GUIDON DESIGN 2453 N DELAWARE STREET, INDIANAPOLIS, IN 46205 Tel: (317) 800-6386		Fire Protection Consultant: HARRINGTON GROUP 7508 E. INDEPENDENCE BLVD., SUITE 116, CHARLOTTE, NC, 28277 Tel: (704) 531-9777		Cost Estimator: BRAY MOONEY CONSULTING 410 E. 21 STREET, CHESTER, PA, 19013 Tel: (610) 872-3716		Aquatic Consultant: ATLANTIC AQUATIC ENGINEERING 1823 DEEP RUN ROAD, PIPERSVILLE, PA, 18947 Tel: (215) 766-0409		PROJECT MANAGER: Project Number: 3627 Scale: 1/8" = 1'-0" Bray Mooney Consulting		Drawing Title: 1ST FLOOR ELECTRICAL DEMOLITION PLAN Approved: Project Director		Project Title: RENOVATE BUILDING 69 Location: 1400 Black Horse Hill, Coatesville, PA Date: 1/22/2014 Checked: CGS/WCM Drawn: KLC		VA Project Number: 542-CSI-203 Building Number: 69 Drawing Number: ED101 Dwg. 70 of 86		Office of Facilities Management Department of Veterans Affairs	
--	--	---	--	---	--	--	--	---	--	---	--	--	--	--	--	---	--	--	--	--	--	--	--	---	--