
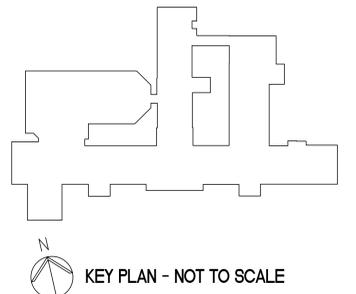


three inches = one foot
 one and one half inches = one foot
 one inch = one foot
 three quarters inch = one foot
 one half inch = one foot
 three eighths inch = one foot
 one quarter inch = one foot
 one eighth inch = one foot

NOTES
 1. REFER TO SPECIFICATION SECTION 010000 FOR REQUIREMENTS REGARDING PRE-CONSTRUCTION INVESTIGATION PRIOR TO COMMENCEMENT OF WORK.

KEYED NOTES
 ① CORRECT GYPSUM BOARD WALL DEFICIENCIES TO ACHIEVE A SMOKE BARRIER RATING OF THE EXISTING WALL IN ROOM 2EAA TO MEET NFPA101-18.3.6.2.3 "TO FORM A BARRIER TO LIMIT THE TRANSFER OF SMOKE." IN ADDITION, CORRECT AND FIRESTOP ALL PENETRATIONS TO MEET THESE CODE REQUIREMENTS. THE VA ARCHITECTURAL DESIGN MANUAL SECTION 4.24.5 ALLOWS "FOR SMOKE BARRIERS, EXTEND ONE LAYER OF GYPSUM BOARD FROM FLOOR TO UNDERSIDE OF STRUCTURE ABOVE ON PARTITIONS, AND FIRESTOP JUNCTURE OF GYPSUM BOARD AND ADJOINING MATERIAL TO PREVENT THE PASSAGE OF SMOKE." REFER TO PHOTO C1/1.AE601.
 ② CORRECT GYPSUM BOARD WALL DEFICIENCIES TO ACHIEVE A SMOKE BARRIER RATING OF THE EXISTING WALL IN ROOM 2B05 TO MEET NFPA101-18.3.6.2.3 "TO FORM A BARRIER TO LIMIT THE TRANSFER OF SMOKE." IN ADDITION, CORRECT AND FIRESTOP ALL PENETRATIONS TO MEET THESE CODE REQUIREMENTS. THE VA ARCHITECTURAL DESIGN MANUAL SECTION 4.24.5 ALLOWS "FOR SMOKE BARRIERS, EXTEND ONE LAYER OF GYPSUM BOARD FROM FLOOR TO UNDERSIDE OF STRUCTURE ABOVE ON PARTITIONS, AND FIRESTOP JUNCTURE OF GYPSUM BOARD AND ADJOINING MATERIAL TO PREVENT THE PASSAGE OF SMOKE." REFER TO PHOTO C4/1.AE601.

LEGEND
 AREA APPLIED TO THIS PORTION OF PROJECT

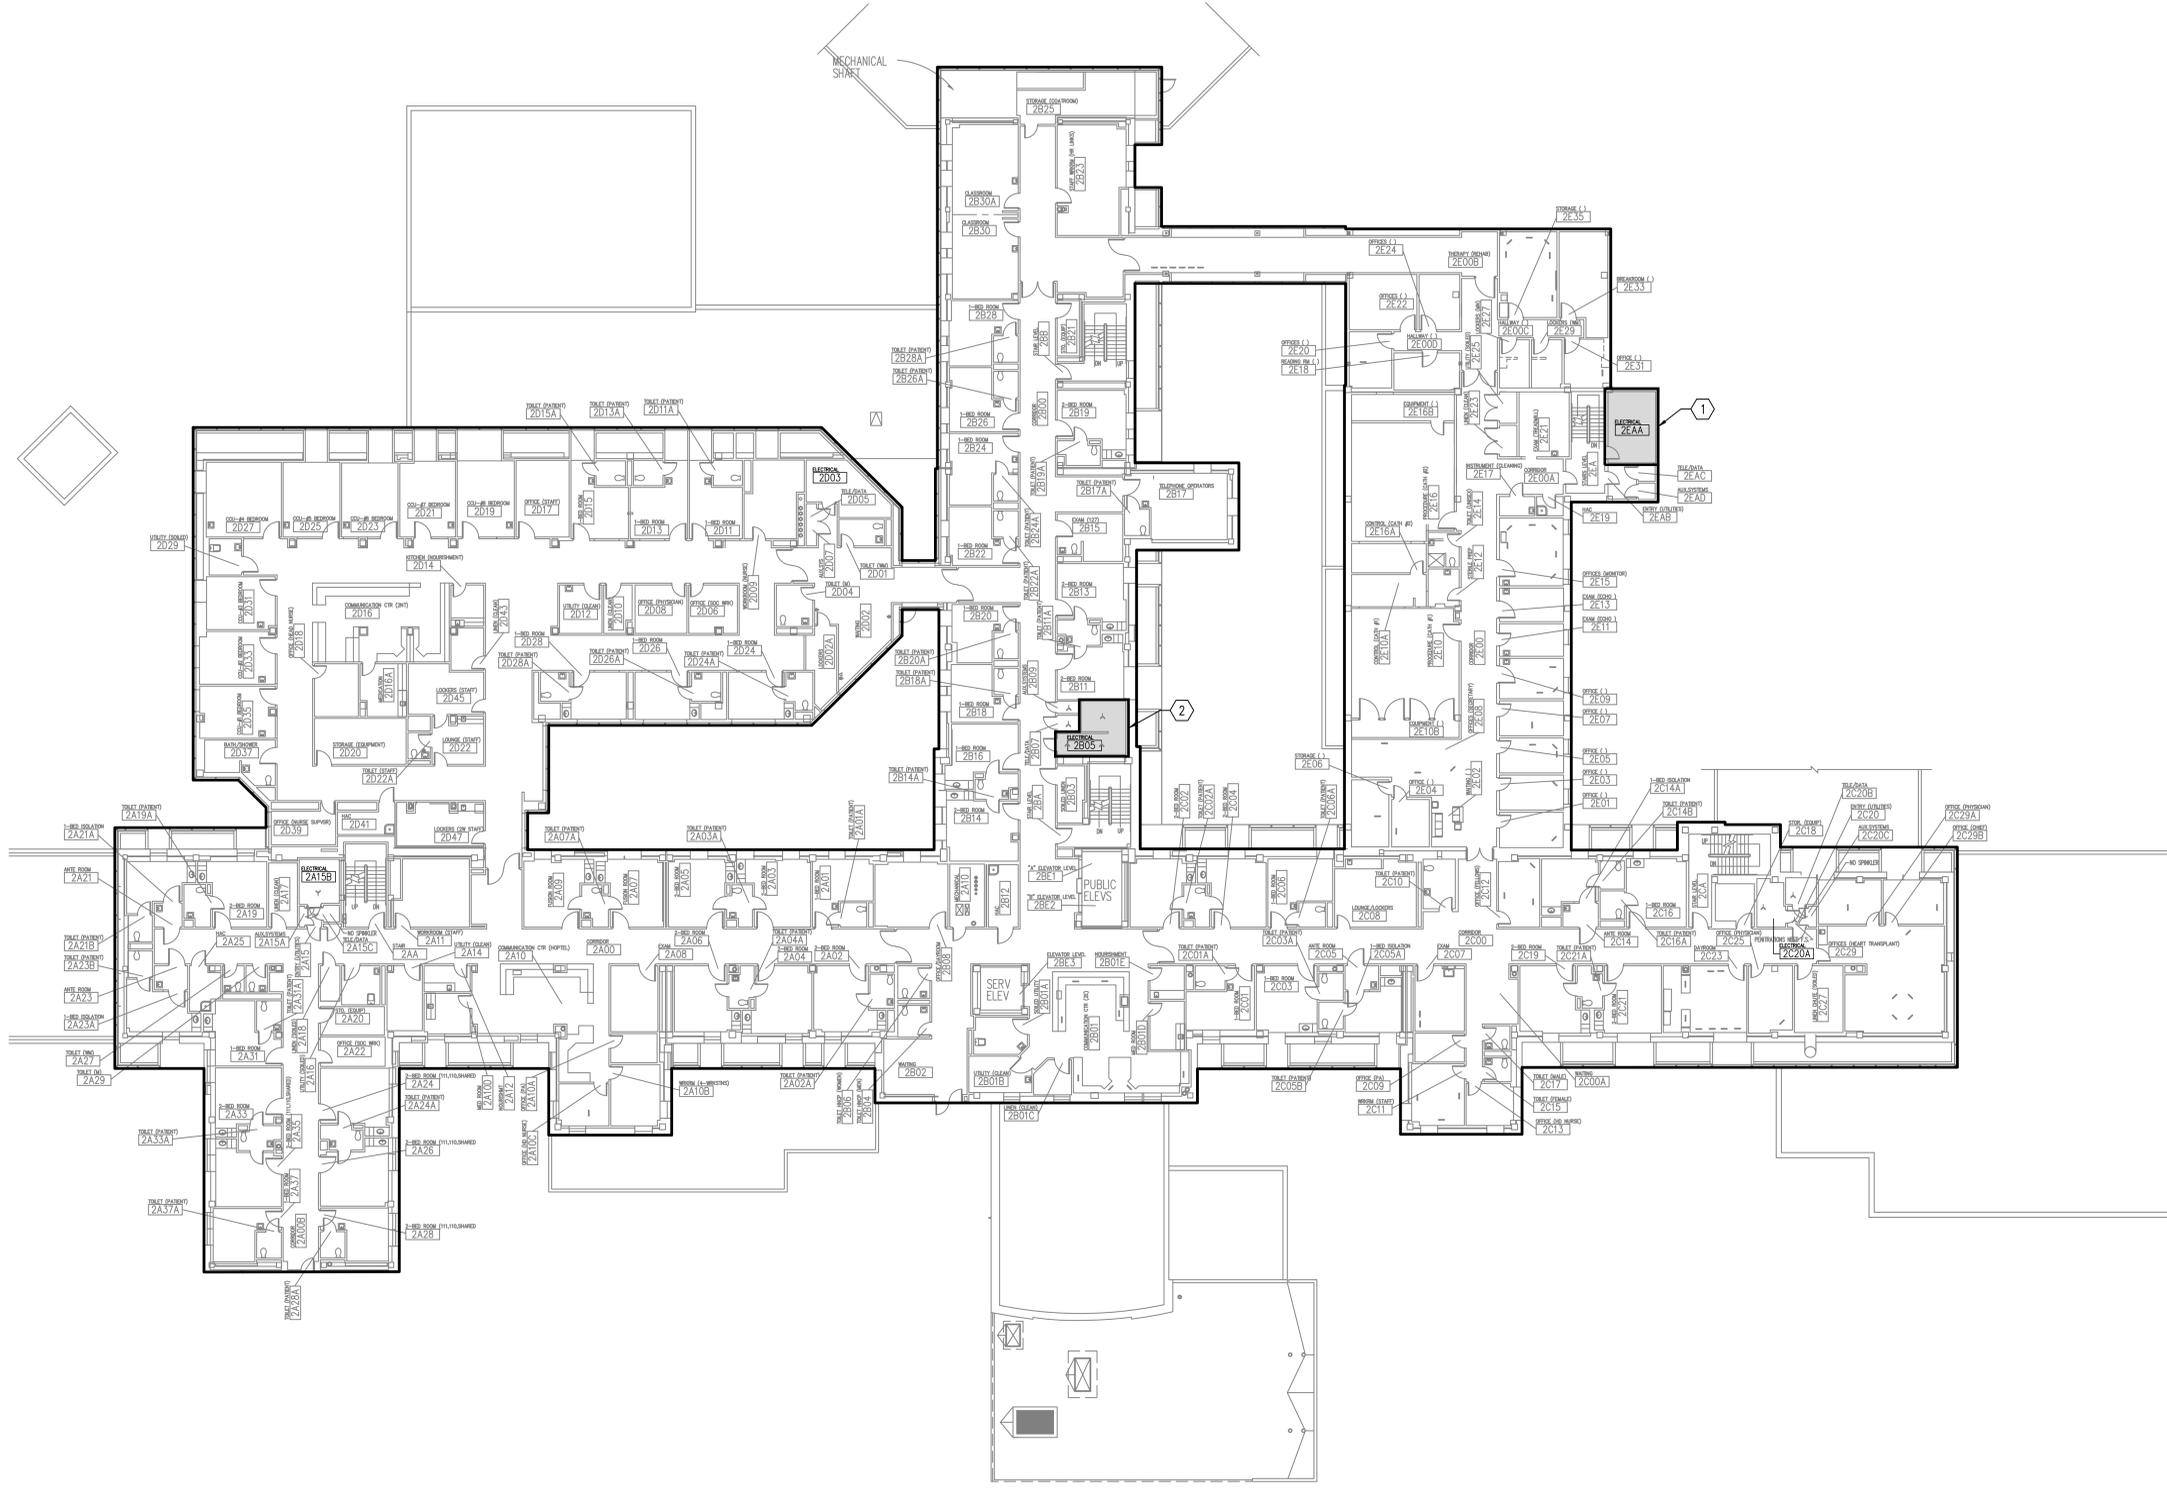

F1 FLOOR PLAN
 1/16" = 1'-0"

FULLY SPRINKLERED
 BID DOCUMENTS
 FOR CONSTRUCTION

AMENDMENT #3 5/20/14 AMENDMENT #1 5/01/14 Revisions Date		ARCHITECT/ENGINEERS:  PARADIGM ENGINEERS AND CONSTRUCTORS 200 Envoy Circle #201, Louisville KY 40299 - PH: 502.339.8511 - www.paradigmusa.com		Drawing Title: FIRE BARRIER PLAN - SECOND FLOOR BUILDING 1		Project Title: FIRE SAFETY UPGRADES		Project Number: 660-14-104 Building Number: 1 Drawing Number: 1.AE102		Office of Construction and Facilities Management  Department of Veterans Affairs	
Approved Project Director		Location: GEORGE E WAHLEN VAMC 500 FOOTBALL DR. SALT LAKE CITY, UT		Date: 12-19-2013		Checked: KLP		Drawn: JDM		VA FORM 08-6231	