


three inches = one foot
 one and one half inches = one foot
 one inch = one foot
 three quarters inch = one foot
 one half inch = one foot
 three eighths inch = one foot
 one quarter inch = one foot
 one eighth inch = one foot


RCP LEGEND

- AIR SUPPLY DIFFUSER
- LINEAR SUPPLY DIFFUSER
- AIR RETURN DIFFUSER
- EXHAUST DIFFUSER
- RECESSED LIGHT FIXTURE
- RECESSED CAN LIGHT FIXTURE
- RECESSED CAN WALL WASHER LIGHT FIXTURE
- WALL MOUNTED STRIP LIGHT FIXTURE
- SUSPENDED LINEAR LIGHT FIXTURE
- CEILING ACCESS PANEL
- CEILING MOUNTED FIRE ALARM SPEAKER
- CEILING MOUNTED SMOKE DETECTOR
- EXIT SIGN - FILLED QUADRANT INDICATES LIT FACE
- CEILING MOUNTED NURSE CALL INDICATOR
- PATIENT LIFT MOTOR AND TRACK
- CEILING PATTERN ORIGIN
- ACT CEILING
- ACT CEILING PATTERN BREAK
- CEILING EXPANSION JOINT
- SUSPENDED GWB

ALL CEILING MOUNTED AND SUSPENDED EQUIPMENT TO BE SEISMICALLY RESTRAINED.

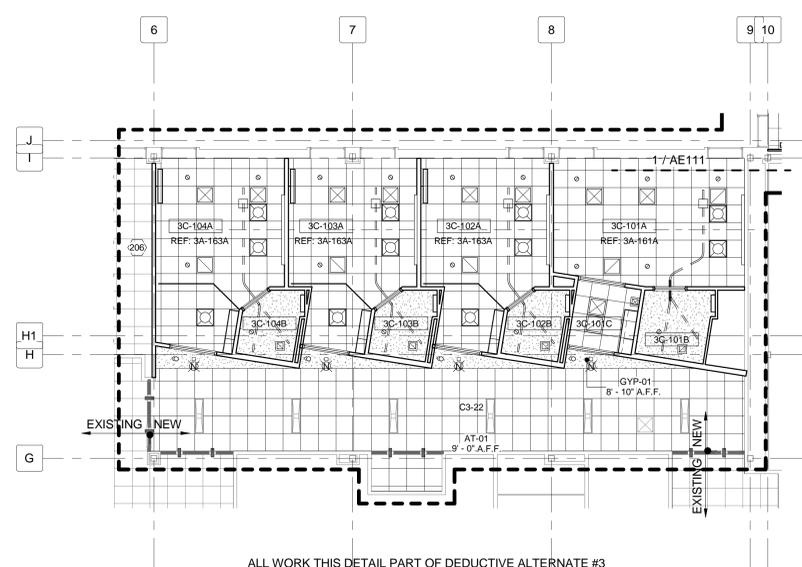

2 LEVEL 3 REFLECTED CEILING PLAN - EAST
 1/8" = 1'-0"

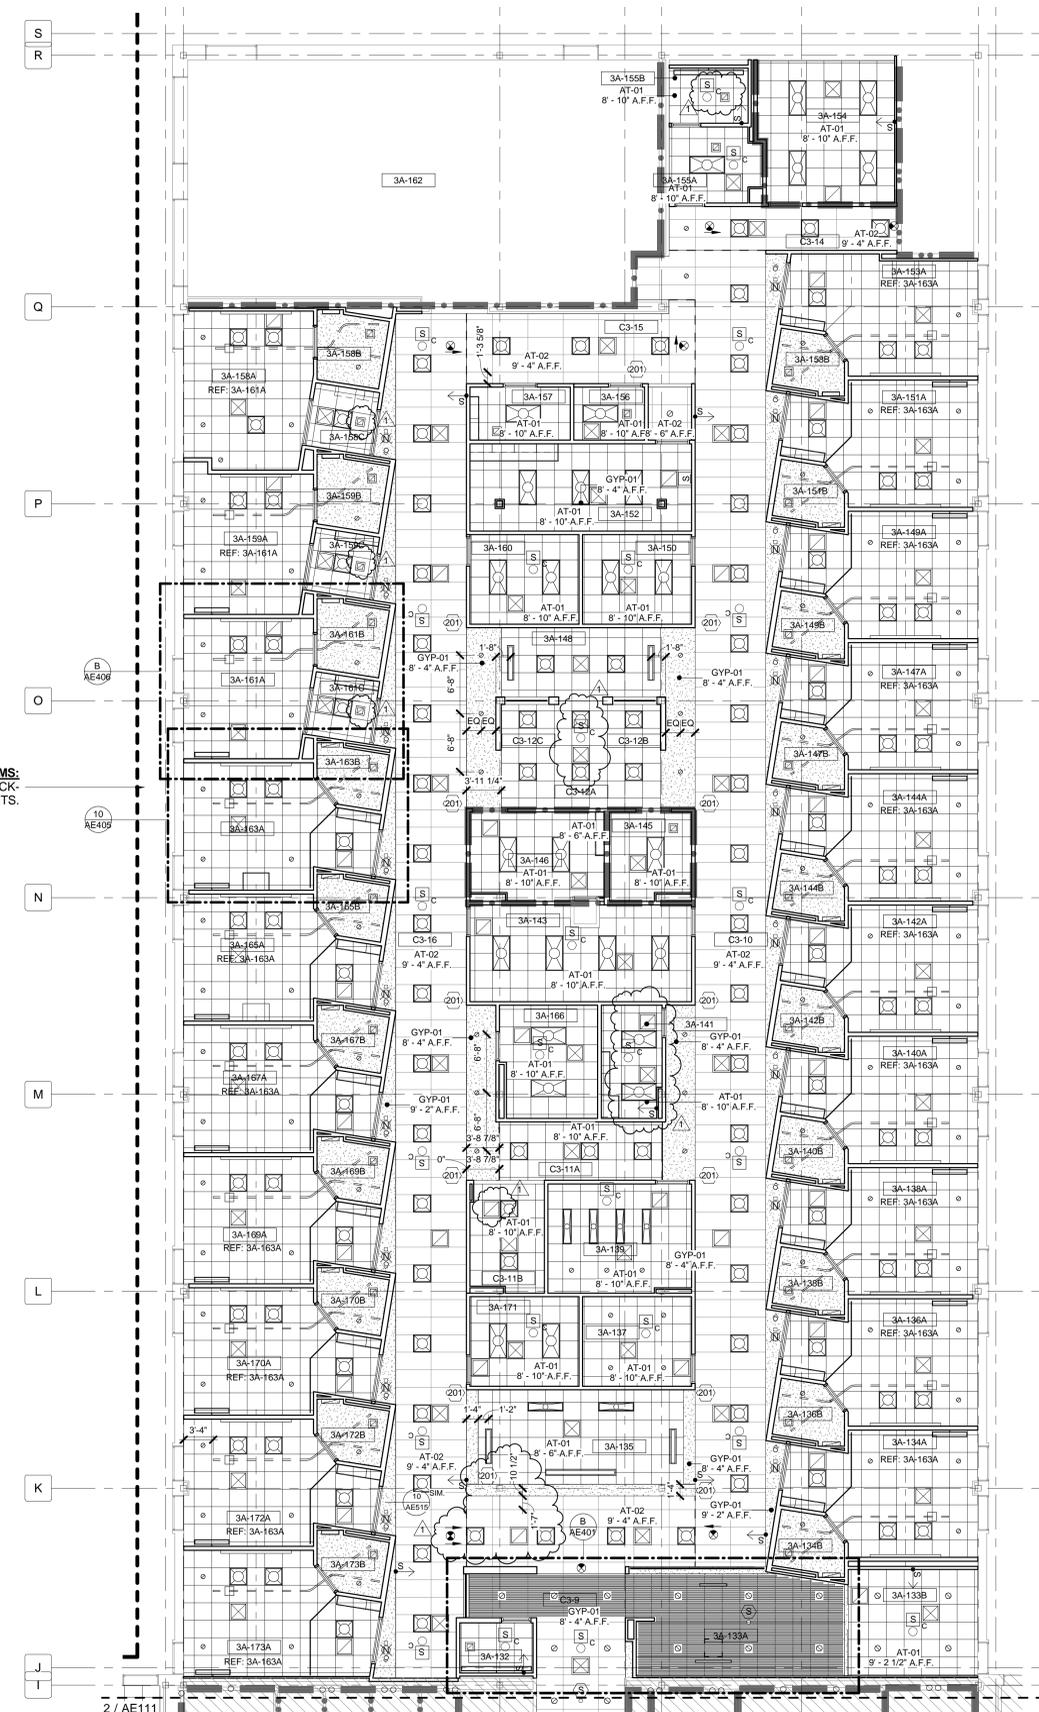

1 LEVEL 3 REFLECTED CEILING PLAN - SOUTH
 1/8" = 1'-0"

MOCK-UP ROOMS:
 REFER TO SHEET AE102 FOR MOCK-UP REQUIREMENTS.

GENERAL RCP NOTES

- 1 RATED WALLS: ARE INDICATED IN PLAN AND RCP WITH GRAPHIC DENOTING HOURLY RATING AND/OR RESISTANT TO PASSAGE OF SMOKE. REFER TO PARTITION TAGS ON FLOOR PLANS AND PARTITION SCHEDULE SHEET G1003 FOR MORE INFORMATION.
- 2 DIMENSIONS ARE TO FINISH FACE OF WALL OR SOFFIT UNO
- 3 GYPSUM BOARD BULKHEADS TO BE SINGLE STUD THICKNESS WITH BOTTOM FINISHED SURFACE 2 INCHES BELOW LOWEST ADJACENT FINISHED CEILING UNO.
- 4 GYPSUM BOARD SOFFITS: GWB AFF NOTED ON RCP.
- 5 WHEN FLOOR HEIGHT VARIES IN A ROOM THE CEILING HEIGHT SHOWN IS HEIGHT ABOVE FLOOR ENTRY.
- 6 11 70 00 PATIENT LIFT CONFIGURATION AND SUPPORTS SHOWN DIAGRAMMATICALLY FROM ONE VENDOR AS BASIS OF DESIGN. CONTRACTOR TO PROVIDE VENDOR-GENERATED LAYOUTS FOR APPROVAL BY VA PRIOR TO FABRICATION. PROVIDE NEW SUPPORTS FROM BUILDING STRUCTURE. DIFFERENT VENDORS HAVE DIFFERENT REQUIREMENTS FOR SPACING OF THEIR SUPPORTS. THEREFORE CONTRACTOR TO PERFORM FINAL COORDINATION OF ABOVE CLG SUPPORTS W/ SELECTED VENDOR'S SHOP DRAWINGS & OTHER ABOVE CLG TRADES.
- 7 ACOUSTIC TILE CEILINGS TO BE CENTERED IN BOTH DIRECTIONS IN ROOM TYP. UNO OR DIMENSIONED OTHERWISE IF DIMENSION IS PROVIDED IN ONE DIRECTION ONLY. ASSUME GRID IS CENTERED IN THE OTHER DIRECTION.
- 8 CUT TILES SHALL BE NO SMALLER THAN 4 INCHES IN ANY DIRECTION UNO. CLG FINISHES / MATERIALS NOTED ON TYPICAL FINISH SCHEDULE.
- 9 INSTALL PLASTIC LAMINATE (PLAM) CLOSURE PANELS OVER ALL CASEWORK - RE: SHEET AE512.
- 10 CENTER LIGHT FIXTURE AND OTHER CEILING DEVICES WITHIN ACOUSTIC TILE UNO. IF ONLY DIMENSIONED IN ONE DIRECTION, ASSUME DEVICE IS CENTERED IN THE OTHER DIRECTION.
- 11 DIMENSIONS TO CENTERLINE OF LIGHT MOUNTED ELEMENT UNO.
- 12 EXIT SIGNAGE/LIGHTING SHOWN ON ELECTRICAL LIGHTING DRAWINGS - REFER TO EL100 SERIES DRAWINGS.
- 13 ORGANIZE SPRINKLER HEADS, SMOKE DETECTORS, NURSE CALL DEVICES, AND OTHER MISC ELECTRICAL DEVICES IN CENTER OF TILE OF SUSPENDED CLGS & ALIGN MULTIPLE DEVICES DOWN CORRIDORS AND THROUGHOUT LARGE ROOMS. COORD W/ OTHER TRADE'S DEVICES.
- 14 CEILING HT. TO BE 8'-10" UNO.

RCP SHEET NOTES

- 201 GWB CONTROL JOINT
- 202 SPLIT TRACK AT PATIENT LIFT RAIL
- 203 GAP WOOD GRILLE FOR CEILING MOUNTED AIR, ELECTRICAL AND FIRE PROTECTION DEVICES
- 204 PATIENT LIFT TRACK - RE: 13/A515
- 205 PLAM SOFFIT
- 206 CUT AND ADJUST EXISTING GRID IN REMAINING SPACE TO MEET NEW PARTITION
- 207 SHOWER CURTAIN TRACK RE: 3/AE515 SIM.

PARTITION / BARRIER LEGEND

- EXISTING PARTITION TO REMAIN
- EXISTING ELEMENT TO BE DEMOLISHED
- NEW UNRATED PARTITION
- NEW / EXISTING 1 HOUR BARRIER
- NEW / EXISTING 1 HOUR SMOKE BARRIER
- NEW / EXISTING 2 HOUR BARRIER
- NEW / EXISTING 2 HOUR SMOKE BARRIER
- NEW 1 HOUR CONSTRUCTION BARRIER - USE BARRIER TYPE B14.

KEY PLAN

SCALE: 1/8" = 1'-0"

LEVEL 3 FFE: 46.0'

CONSTRUCTION DOCUMENTS SUBMISSION FULLY SPRINKLERED

CONSULTANTS:

1 CEILING EQUIPMENT COORDINATION 06/04/2014

Revisions: _____ Date _____



ARCHITECT/ENGINEERS:

BES DESIGN/BUILD

BES DESIGN/BUILD, LLC
 766 Middle St. Fairhope, AL 36532
 Phone: 251.990.5778
 Fax: 251.990.3716

Drawing Title
LEVEL 3 REFLECTED CEILING PLANS

Approved: Project Director

Project Title
RENOVATE MEDICAL SURGICAL UNIT

Project Number
544-13-102

Building Number
100

Location
W.J. BRYAN DORN VAMC; COLUMBIA, SC

Date
05/16/2014

Drawn
BUSH

Checked
CHAMBERS

Drawing Number
AE111

Dwg. 10 of 78

