

three inches = one foot  
 one and one half inches = one foot  
 one inch = one foot  
 one quarter inch = one foot  
 three eighth inch = one foot  
 one half inch = one foot  
 one eighth inch = one foot  
 one quarter inch = one foot  
 one eighth inch = one foot

**GENERAL NOTES**


- CHILLER ROOM DEMO PLAN:**
- COORDINATE WITH SEATTLE VA FACILITIES TO DEMO OR RELOCATE EQUIPMENT, CHAIN LINK FENCE, STOCKING ITEMS IN INCINERATOR ROOM TO THE NEW LOCATION.
  - COORDINATE WITH VA DESIGN TEAM FOR FINAL RESTING LOCATION OF THE EXISTING ITEMS TO BE RELOCATED TO MINIMIZE IMPACT ON SERVICES.

**PHASING PLAN**

- TIE-IN NEW CHILLER AND CHILLER PIPING DURING HEATING (WINTER) SEASON.

**KEY NOTES**

CONSTRUCTION DOCUMENT 2  
 FULLY SPRINKLERED

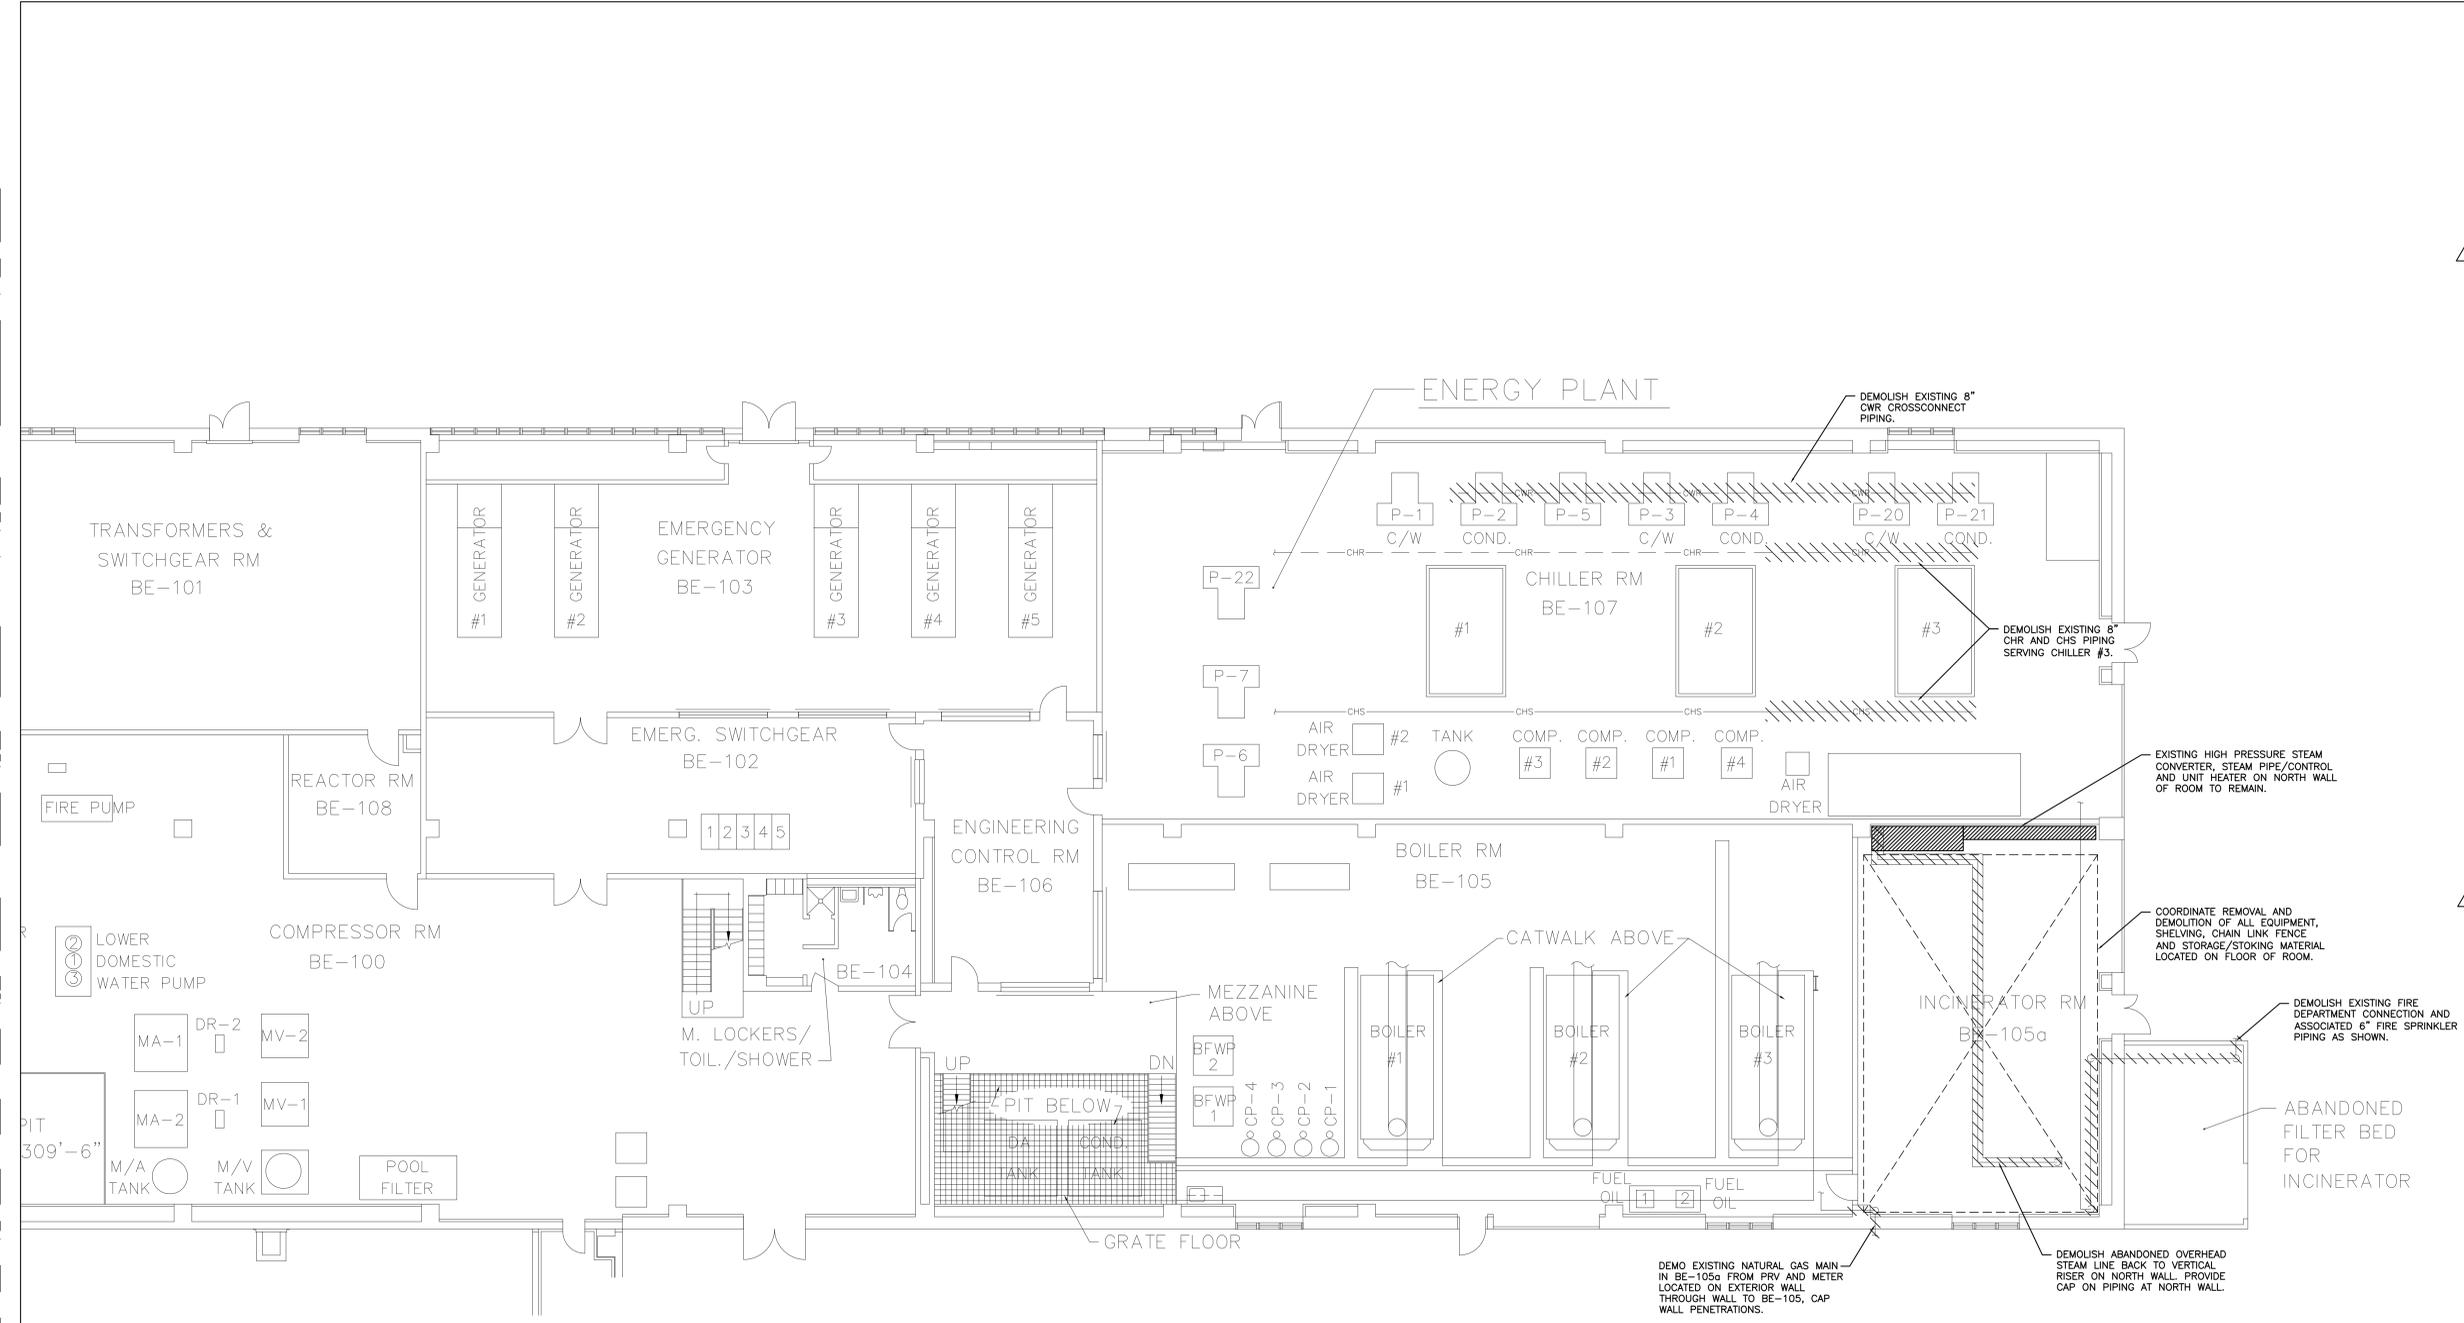


**BASEMENT – ENERGY PLANT  
 BUILDING 100 – D&T BUILDING  
 SCALE: NONE**

AMENDMENT A0004	07.14.2014
BID DOCUMENTS	05.30.2014
CONSTRUCTION DOCUMENT CD2	06.05.2013
Revisions:	Date

**CONSULTANTS:**

Stantec Consulting  
 100 California Street, Suite 1000  
 San Francisco, CA 94111  
 T: 415.882.9500  
 F: 415.882.9523

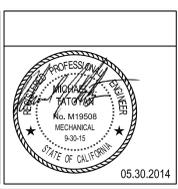

**ARCHITECT**

**STANTEC | THE DESIGN PARTNERSHIP**

Drawing Title	MH&R - CENTRAL PLANT MECHANICAL DEMOLITION & PHASING PLAN GROUND FLOOR
Drawing Scale	1/8" = 1'-0"
Approved:	Project Director

Project Title	MH&R - 101 Mental Health Services VAPSHCS Seattle Division - Phase 2 MENTAL HEALTH AND RESEARCH BUILDING
Location	1600 South Columbian Way, Seattle, WA 98105
Date	JUNE 05, 2013
Checked	RD
Drawn	HB/NN
Project Number	VAF 663-405B
Building Number	B100 Central Utility Plant
Drawing Number	MD402 Volume 2b

**Office of  
 Construction  
 and Facilities  
 Management**

**Department of  
 Veterans Affairs**