




KEY NOTES	
1	SLOPE SANITARY SEWER PIPING 1/4" PER FOOT IN DIRECTION INDICATED. (TYPICAL).
2	SANITARY SEWER DROP TO FIRST FLOOR. SEE PP310 FOR CONTINUATION.
3	SANITARY SEWER DROP TO FIRST FLOOR. SEE PP210 FOR CONTINUATION.
4	WATER SUPPLY RISER FROM FIRST FLOOR ATTIC. SEE PP310 FOR CONTINUATION.
5	WATER SUPPLY RISER FROM FIRST FLOOR ATTIC. SEE PP210 FOR CONTINUATION.
6	3/4" HUR RISER FROM FIRST FLOOR ATTIC. SEE PP310 FOR CONTINUATION.
7	WATER SUPPLY RISER UP FROM FIRST FLOOR ATTIC AND UP THROUGH ROOF. SEE PP310 AND PP230 FOR CONTINUATION.
8	VENT UP FROM FIRST FLOOR ATTIC AND UP THROUGH ROOF. SEE PP310 AND PP230 FOR CONTINUATION.
9	VENT UP THROUGH ROOF. SEE PP230 FOR CONTINUATION.
10	GAS-FIRED INSTANTANEOUS WATER HEATER MOUNTED ON WALL WITH CONCENTRIC DIRECT VENTING THROUGH ROOF.
11	1-HOUR FIRE RATED WALL. SEE ARCHITECTURAL DRAWINGS.
12	ACOUSTICAL SOUND WALL. SEE ARCHITECTURAL DRAWINGS.
13	FOR EXTENT OF ALTERNATE DEDUCTIVE SEE ARCHITECTURAL DRAWINGS.

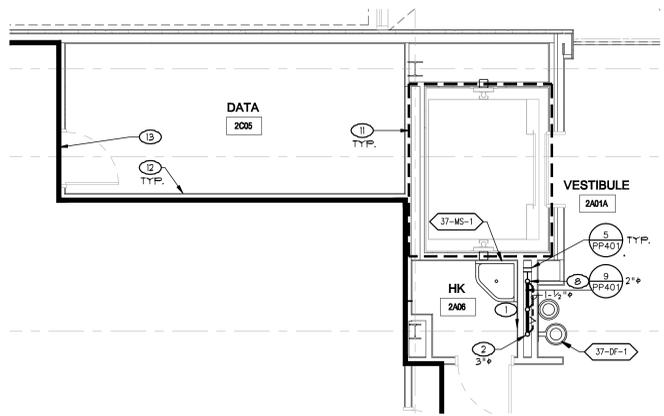


1 SEWER AND VENT FOR SECOND FLOOR PARTIAL PLUMBING PLAN
SCALE: 1/8" = 1'-0"

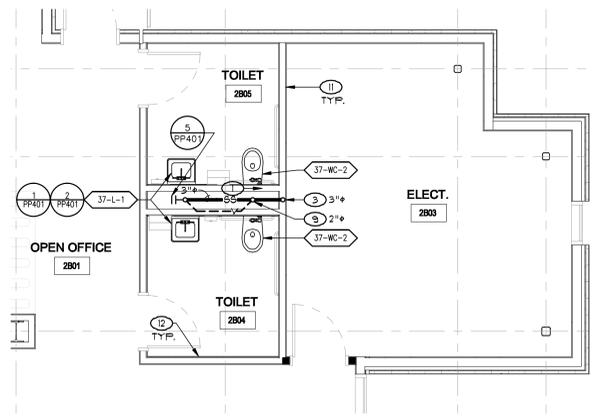

2 SEWER AND VENT FOR SECOND FLOOR PARTIAL PLUMBING PLAN
SCALE: 1/8" = 1'-0"

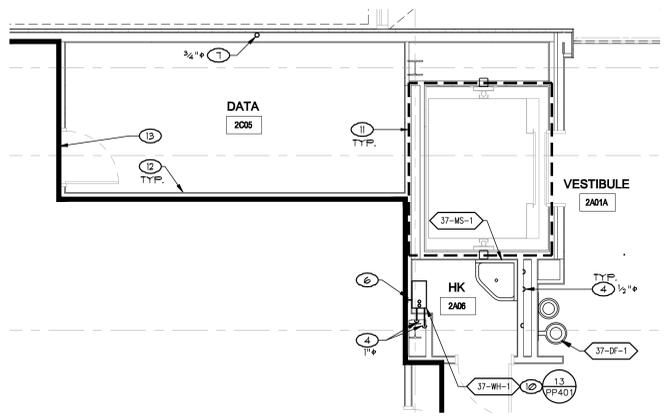

3 HOT AND COLD WATER FOR SECOND FLOOR PARTIAL PLUMBING PLAN
SCALE: 1/8" = 1'-0"

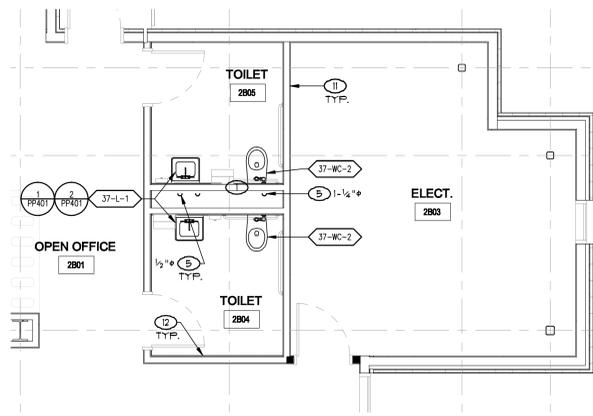

4 HOT AND COLD WATER FOR SECOND FLOOR PARTIAL PLUMBING PLAN
SCALE: 1/8" = 1'-0"

CONSULTANTS:



LP LP Consulting Engineers, Inc.
885 W. Ashlan Ave, Suite 101 Clovis, CA 93612
p 559-348-2130 - f 559-348-2151
www.lpengineers.com
Job #: 11-1888.1

ARCHITECT/ENGINEERS:

HMC Architects
1827 E. Fir Avenue / Studio 103 / Fresno, CA 93720
T 559 322 2444 / www.hmcarchitects.com
HMC PROJECT #1983002-000

Drawing Title
SECOND FLOOR PARTIAL PLUMBING PLANS (DEDUCTIVE ALTERNATE #19)

Approved: Project Director

Project Title
Mental Health Psychosocial Rehab Recovery and Health Care for Homeless Veteran Center

Location
2615 E. CLINTON AVE, FRESNO, CA 93703

Date
8/ 11/ 2014

Checked
PD, GL

Drawn
DN

Project Number
570-217
Building Number
37

Drawing Number
PP321
Dwg. of

Office of Construction and Facilities Management

