


KEY NOTES	
①	SUPPLY FROM FIRST FLOOR FIRE SPRINKLER RISER
②	TOTALPAC 2 DUAL INTERLOCK PREACTION SYSTEM
③	DUAL INTERLOCK PREACTION SYSTEM, SUPPLY FROM FIRST FLOOR
④	88J AND 1" PLUGGED OUTLETS FOR FUTURE

GENERAL NOTES	
1.	ITEMS SHOWN ON THIS PLAN DESCRIBE GENERAL LAYOUT REQUIREMENTS, AND ARE NOT INTENDED TO SHOW A COMPLETE LAYOUT OF REQUIRED FIRE PROTECTION SYSTEM PIPING AND COMPONENTS. REFER TO ARCHITECTURAL, MECHANICAL AND PLUMBING SHEETS, FIRE PROTECTION SPECIFICATIONS, AS WELL AS OTHER PORTIONS OF THE CONTRACT DOCUMENTS FOR ADDITIONAL COORDINATION REQUIREMENTS.
2.	THE LAYOUT REQUIREMENTS DESCRIBED IN THESE PLANS SHALL BE ADHERED TO AS CLOSELY AS POSSIBLE BUT SHALL NOT SUPERSEDE CODE CONSTRAINTS AND/OR REQUIREMENTS OF AUTHORITIES HAVING JURISDICTION (A.H.J.'S). WHERE CODE OR A.H.J. REQUIREMENTS SUPERSEDE ITEMS SHOWN ON THIS PLAN, CONTRACTOR SHALL INCLUDE ALL ASSOCIATED PROVISIONS IN THE BID, AND SHALL MAKE THEM AT NO ADDITIONAL COST TO OWNER. PROPOSED DEVIATIONS FROM THIS PLAN SHALL BE SUBJECT TO ENGINEER OF RECORD REVIEW AND APPROVAL PRIOR TO IMPLEMENTATION.
3.	ALL AREAS OF THE BUILDING NOT COVERED BY NOTES HEREIN SHALL BE FULLY SPRINKLERED IN ACCORDANCE WITH SPECIFICATIONS, NFPA 13, 2010 ED., CITY OF FRESNO FIRE DEPARTMENT REQUIREMENTS, DEPARTMENT OF VETERANS AFFAIRS FIRE PROTECTION DESIGN STANDARDS AND CODE REQUIREMENTS.
4.	WHERE PLAN INDICATES EXPOSED FIRE SPRINKLER PIPING DIRECTION OF LAYOUT, ASSOCIATED CONNECTED FIRE SPRINKLER PIPING RUNNING IN PERPENDICULAR DIRECTIONS SHALL BE INSTALLED ONLY IN CONCEALED LOCATIONS UNLESS INDICATED OTHERWISE.
5.	INSTALLING CONTRACTOR TO FIELD VERIFY ALL EXISTING CONDITIONS AND IS RESPONSIBLE FOR PREPARING A DESIGN TO ACCOMMODATE ALL EXISTING CONDITIONS.
6.	EXPOSED FIRE SPRINKLER SYSTEM PIPING SHALL BE RUN STRAIGHT AND TIGHT TO UNDERSIDE OF STRUCTURAL MEMBERS.

SYMBOLS AND DESCRIPTIONS									
SYM	TYPE	FINISH	TEMP	K FACTOR	THRD	SIN *	FRG	MODEL	ESCUICHEON
○	88J	BRASS	200°	5.6	1/2"	VK300	VIKING	MICROFAST	N/A
●	INST 88P	CHROME	165°	5.6	1/2"	VK410	VIKING	MICROFAST	FLUSH

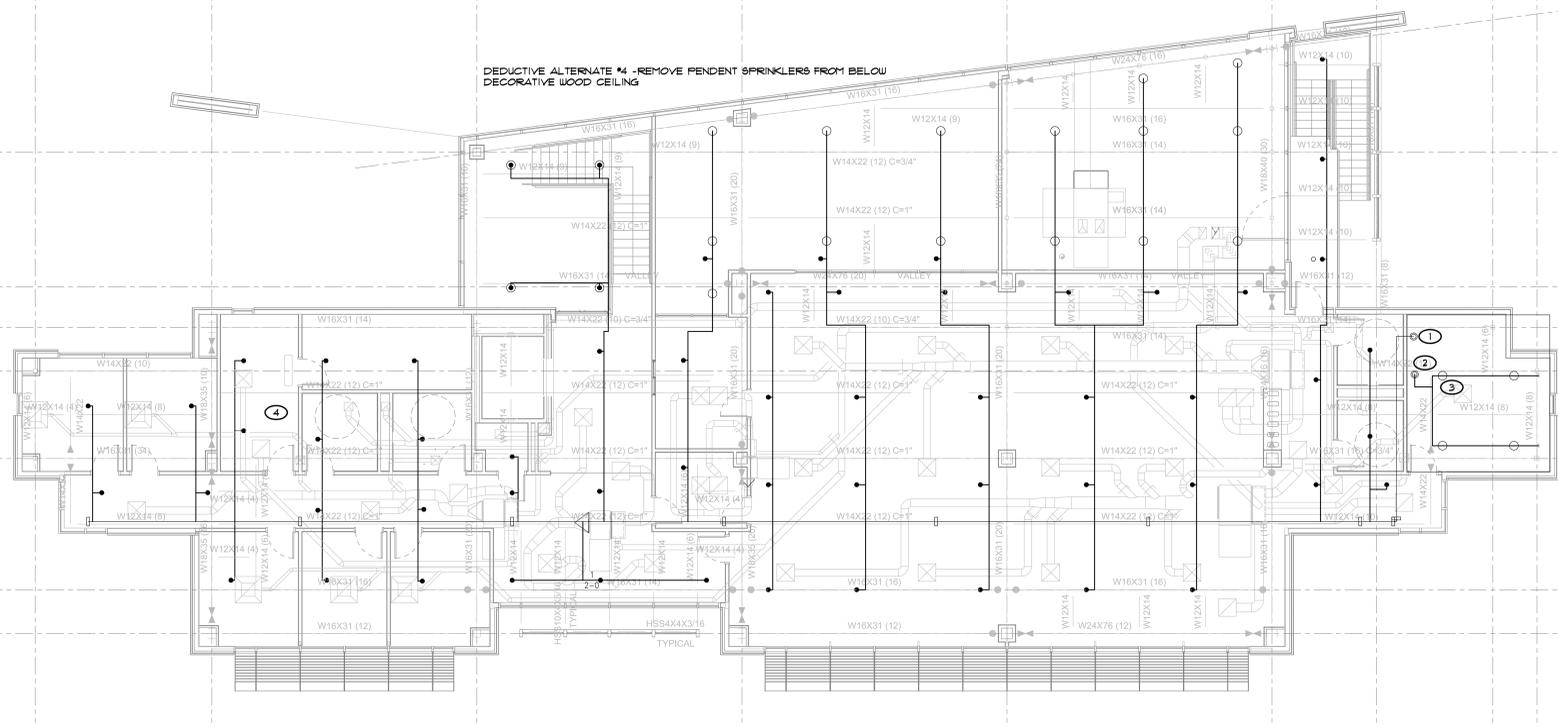

① SECOND FLOOR FIRE SPRINKLER PIPING PLAN
SCALE: 1/8" = 1'-0"



CONSULTANTS:



LP Consulting Engineers, Inc.
895 W. Ashlan Ave, Suite 101 Clovis, CA 93612
p. 559-348-2130 • f. 559-348-2131
www.lpengines.com
Job #: 11-1008

ARCHITECT/ENGINEERS:

HMC Architects

1827 E. Fir Avenue / Studio 103 / Fresno, CA 93720
T 559 322 2444 / www.hmcarchitects.com
HMC PROJECT #1393002-000

Drawing Title
SECOND FLOOR FIRE SPRINKLER PIPING PLAN

Approved: Project Director

Project Title
Mental Health Psychosocial Rehab Recovery and Health Care for Homeless Veteran Center

Location
2615 E. CLINTON AVE, FRESNO, CA 93703

Date: 08/11/2014
Checked: SA
Drawn: AB

Project Number
570-217

Building Number
37

Drawing Number
FP220

Office of Construction and Facilities Management:

