



GENERAL NOTES
 1. CABLES TO DEVICES ON THIS SHEET SHALL BE ROUTED TO (HC-9). REFER TO 3/22 TY101 FOR CLOSET LAYOUT.


three inches = one foot
 one and one half inches = one foot
 one inch = one foot
 three quarters inch = one foot
 one half inch = one foot
 three eighths inch = one foot
 one eighth inch = one foot
 one quarter inch = one foot
 one eighth inch = one foot

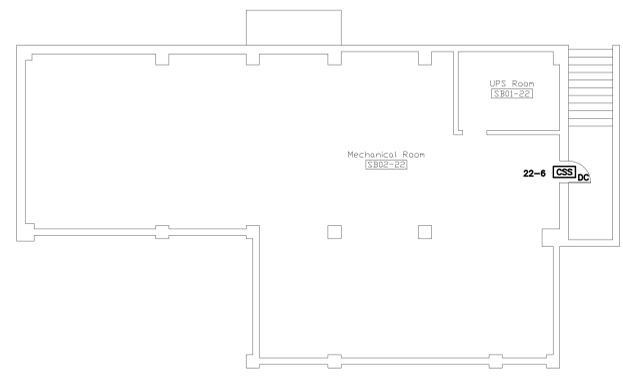


BUILDING 22 SUB-BASEMENT - SECURITY
 SCALE: 1/8"=1'-0"

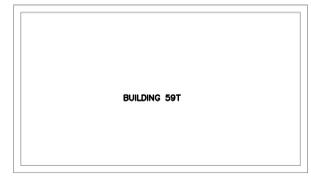

BUILDING 59T

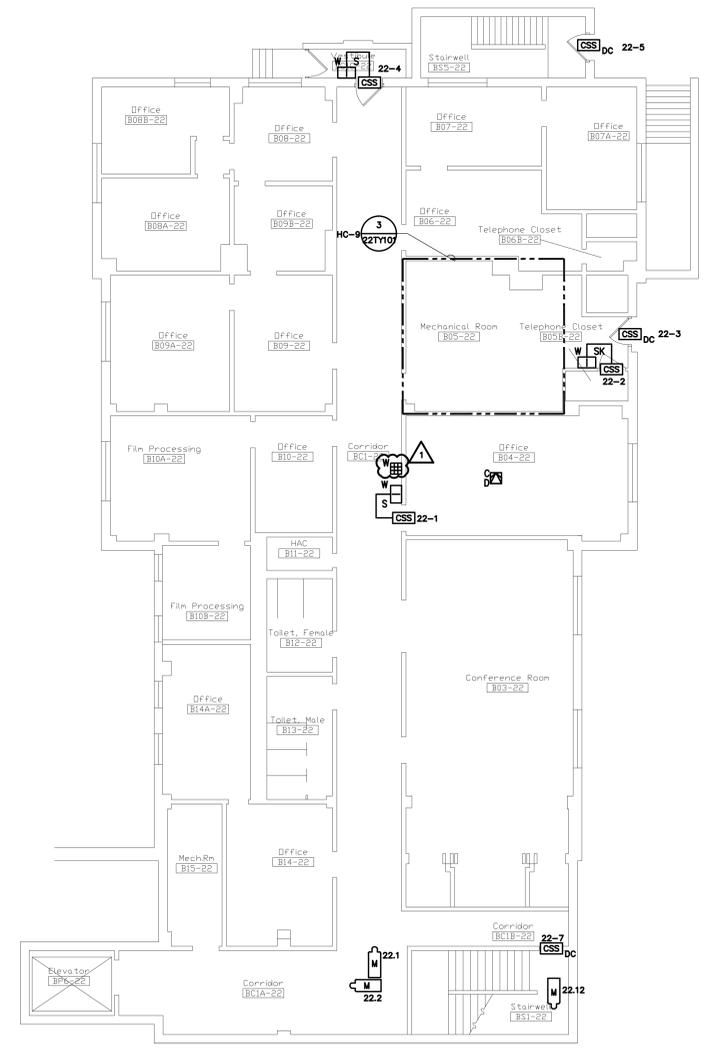


BUILDING 22 BASEMENT - SECURITY
 SCALE: 1/8"=1'-0"

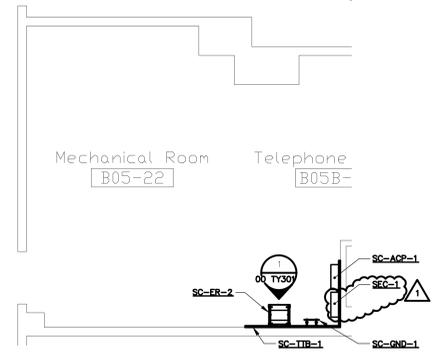

TECHNOLOGY ROOM LAYOUT HC-9
 SCALE: 1/4"=1'-0"

- NOTES:**
1. REFER TO ELECTRICAL DRAWINGS FOR GROUNDING RISER DIAGRAM.
 2. REFER TO 2/00 TY401 FOR CONNECTIVITY RISER DIAGRAM.
 3. REFER TO 00 TY600 FOR TECHNOLOGY GENERAL EQUIPMENT SCHEDULE.

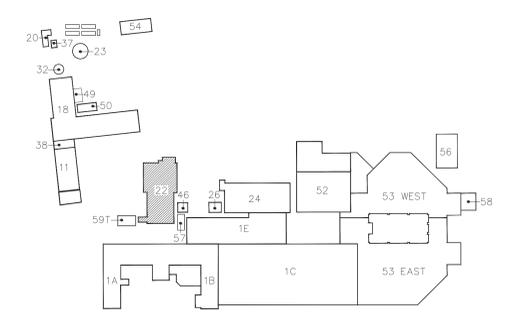

KEY PLAN
 NO SCALE

No.	Description	Date
1	ADDENDUM #4	12/05/14
Revisions		

CONSULTANTS:

KJ ENGINEERING CONSULTANTS
 Experience you can build on
 870 SUMNER DRIVE, SUITE 104
 2110201, MUSKOGEE, OK 74401
 205-271-2124
 FAX: 205-271-1173
 WWW.KJEC.COM

ARCHITECTS/ENGINEERS:

303rd Engineering Group, LLC
 Service-Disabled Veteran-Owned Small Business
 1925 ARDENVALE STREET
 ST. LOUIS, MO 63118
 PHONE: (314) 569-3282
 HTTP://WWW.303ENGINEERING.COM

Dept. of Veterans Affairs
 Jack C. Montgomery
 Medical Center
 1011 Honor Height Drive
 Muskogee, Oklahoma 74401



APPROVED:	APPROVED: President AF.GE. 2250	APPROVED: Energy Engineer	APPROVED: Medical Center Director
APPROVED:	APPROVED:	APPROVED: Safety Manager	APPROVED: Associate Director
APPROVED:	APPROVED:	APPROVED: Infection Control Nurse	APPROVED: Chief of Staff
APPROVED:	APPROVED:	APPROVED: Industrial Hygienist	APPROVED: Chief of Engineering Service

Drawing Title:	SUB-BASEMENT AND BASEMENT
Scale:	AS SHOWN
Building Number:	22

Project Title:	REPLACE SURVEILLANCE SYSTEM		
Date:	08.23.13		
Project No.:	623.12.105		
Approved:	TWC - JCMVAMC	Checked By: DAVLAR	Drawn By: KEIEVE
Location:	Jack C. Montgomery VA Medical Center - Muskogee, OK		

Drawing No.:	22 TY101
Dwg.:	73 of 122



ISSUED FOR CONSTRUCTION