


CONSULTANTS:

MEP Engineer



H.F. Lenz Company

1407 Scalp Avenue
Johnstown, PA 15904
Tel (814) 269-9300
Fax (814) 269-9301

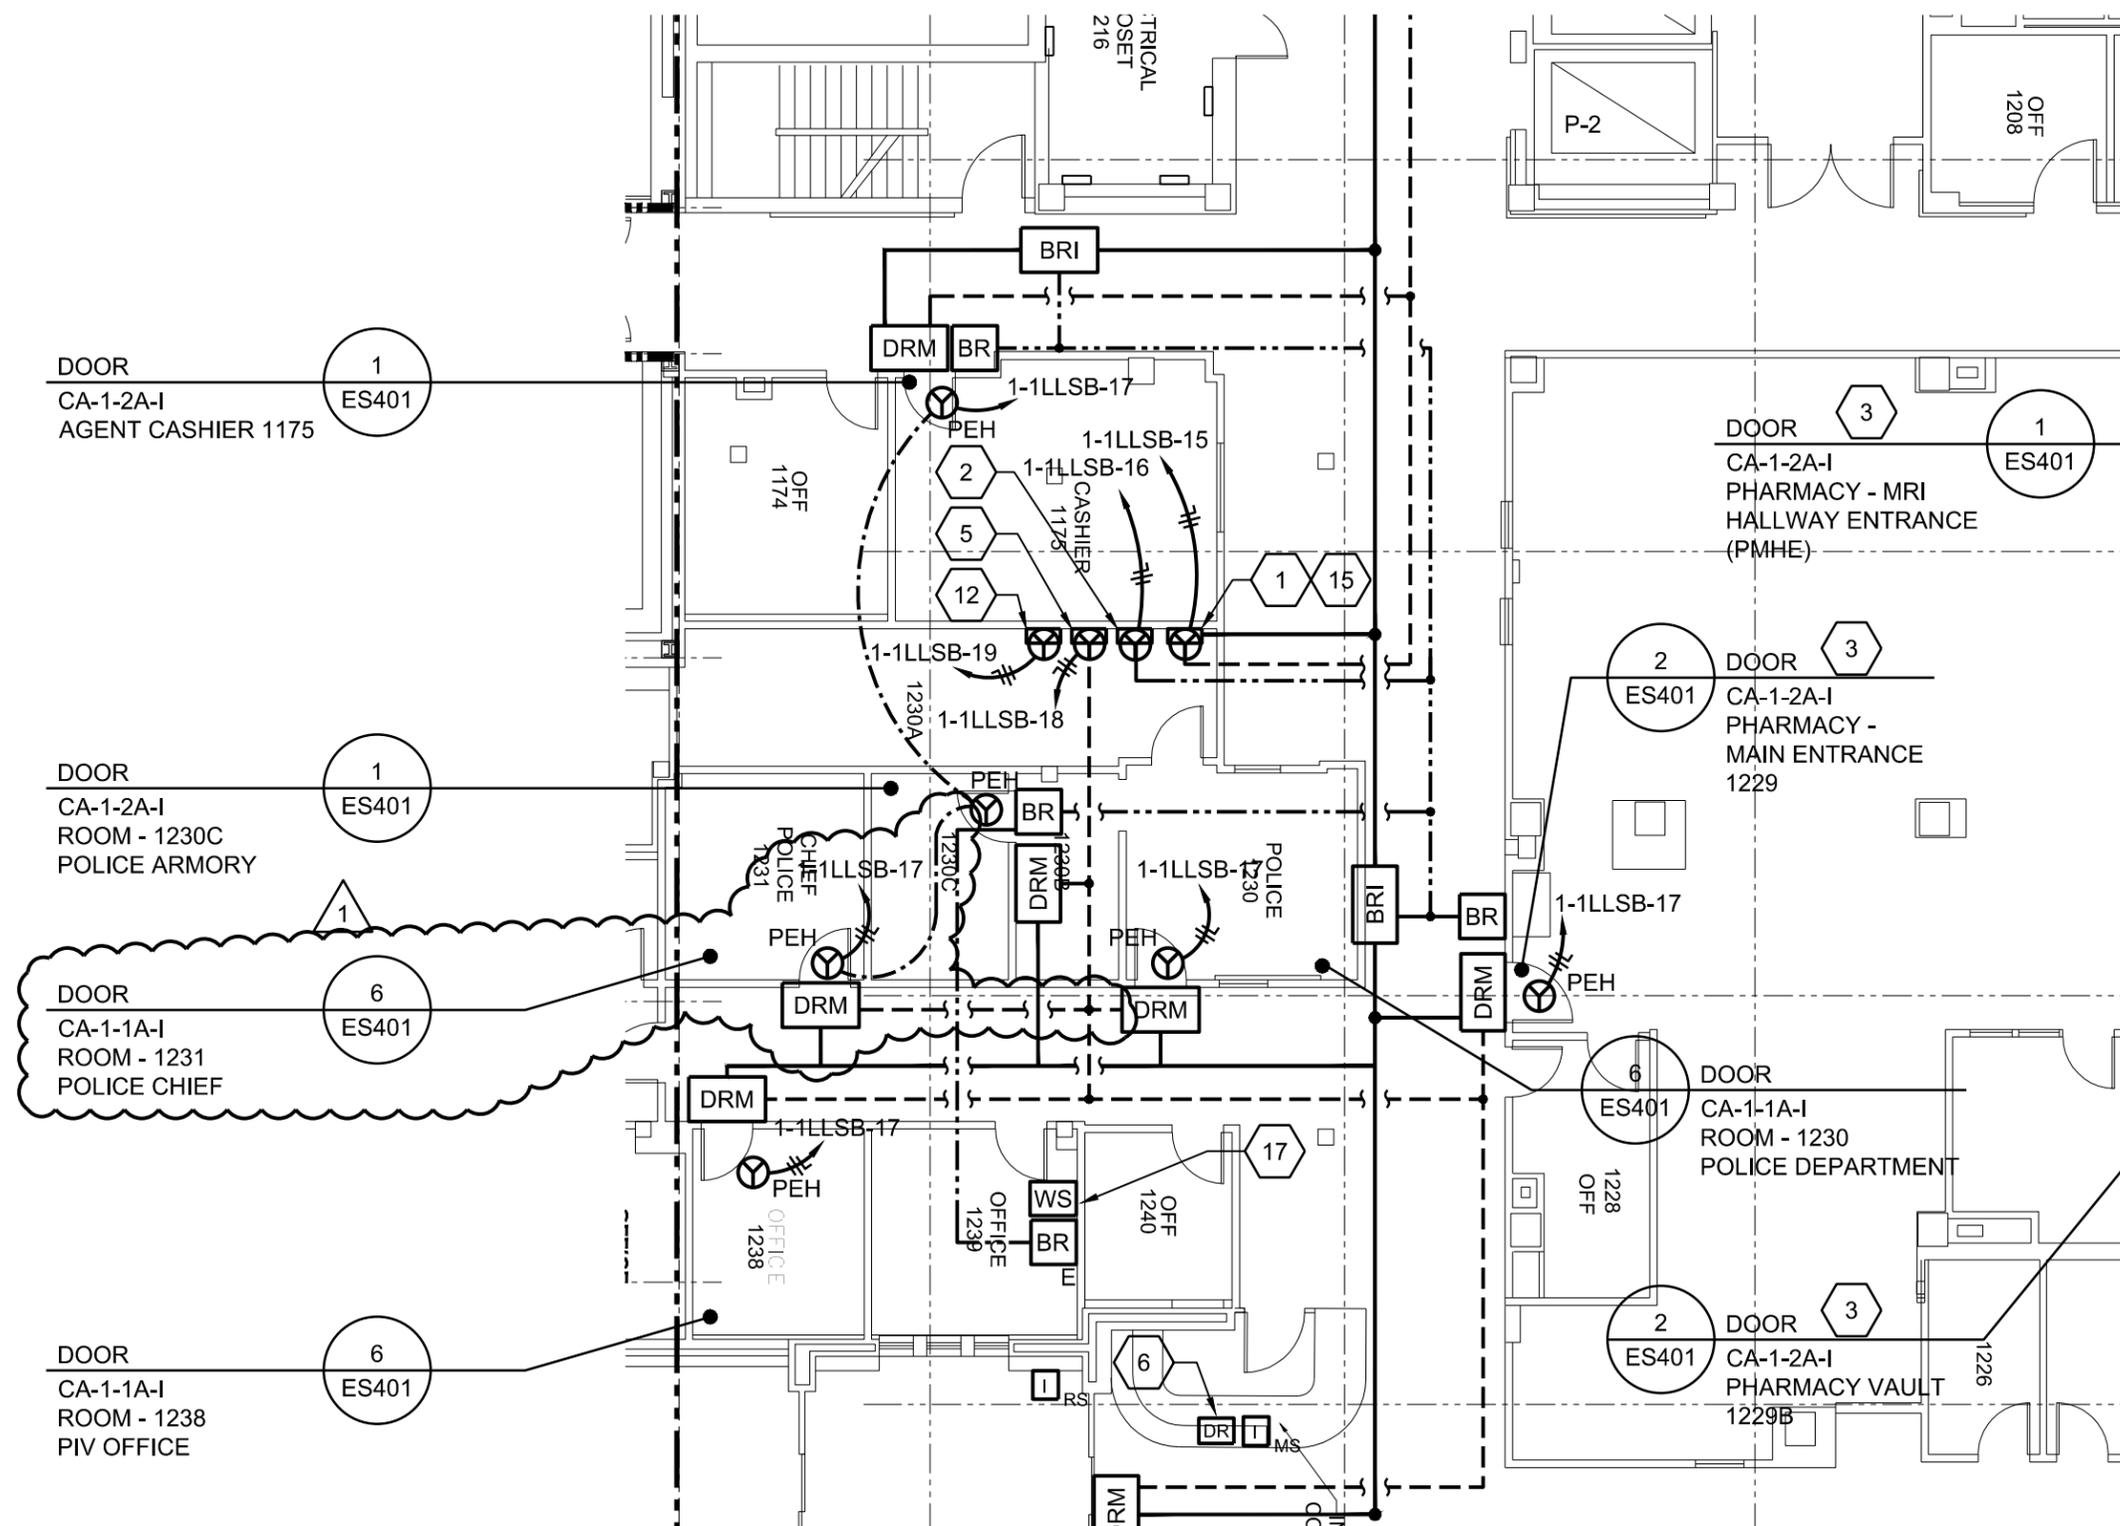

12/16/2014 - AMENDMENT #3
TO CONTRACT DRAWING NUMBER: CA-ES102



SCALE: 3/32" = 1'-0"

OWNER:

VETERANS
HEALTH
ADMINISTRATION

HOSPITAL:

LOUIS A. JOHNSON VA
MEDICAL CENTER

PROJECT:

LAJ VA CLARKSBURG -
PACS/CCTV REPLACEMENT

ADDRESS:

1 MED CENTER DRIVE CLARKSBURG, WV

SKETCH TITLE:

PARTIAL CLINICAL ADDITION
FIRST FLOOR PLAN ELECTRICAL
PACS PLAN

DRAWN:

RJD

DRAWING REFERENCE: CA-ES102

CHECKED:

TME

PROJECT No. VA244-P-1491

DATE: 12/16/14

SCALE: AS NOTED

SHEET NO.

ESK001