


GENERAL NOTES

A. REMOVE ALL LIGHTING FIXTURES AS SHOWN AND REMOVE FIXTURE WHIP BACK TO CLOSEST JUNCTION BOX. MAINTAIN EXISTING CIRCUIT SERVING EACH AREA FOR RECONNECTION TO NEW FIXTURES.

PLAN NOTES

- 1. PROVIDE TEMPORARY STAIRWELL LIGHTING AFTER DEMOLITION AND PRIOR TO INSTALLATION OF NEW FIXTURES. STAIRWELLS SHALL REMAIN ILLUMINATED THROUGHOUT PROJECT. IF DEDUCT ALTERNATE #1 IS ACCEPTED, THEN WORK ASSOCIATED SHALL NOT BE PERFORMED.
- 2. LIGHTING IN THIS AREA IS EXISTING TO REMAIN.

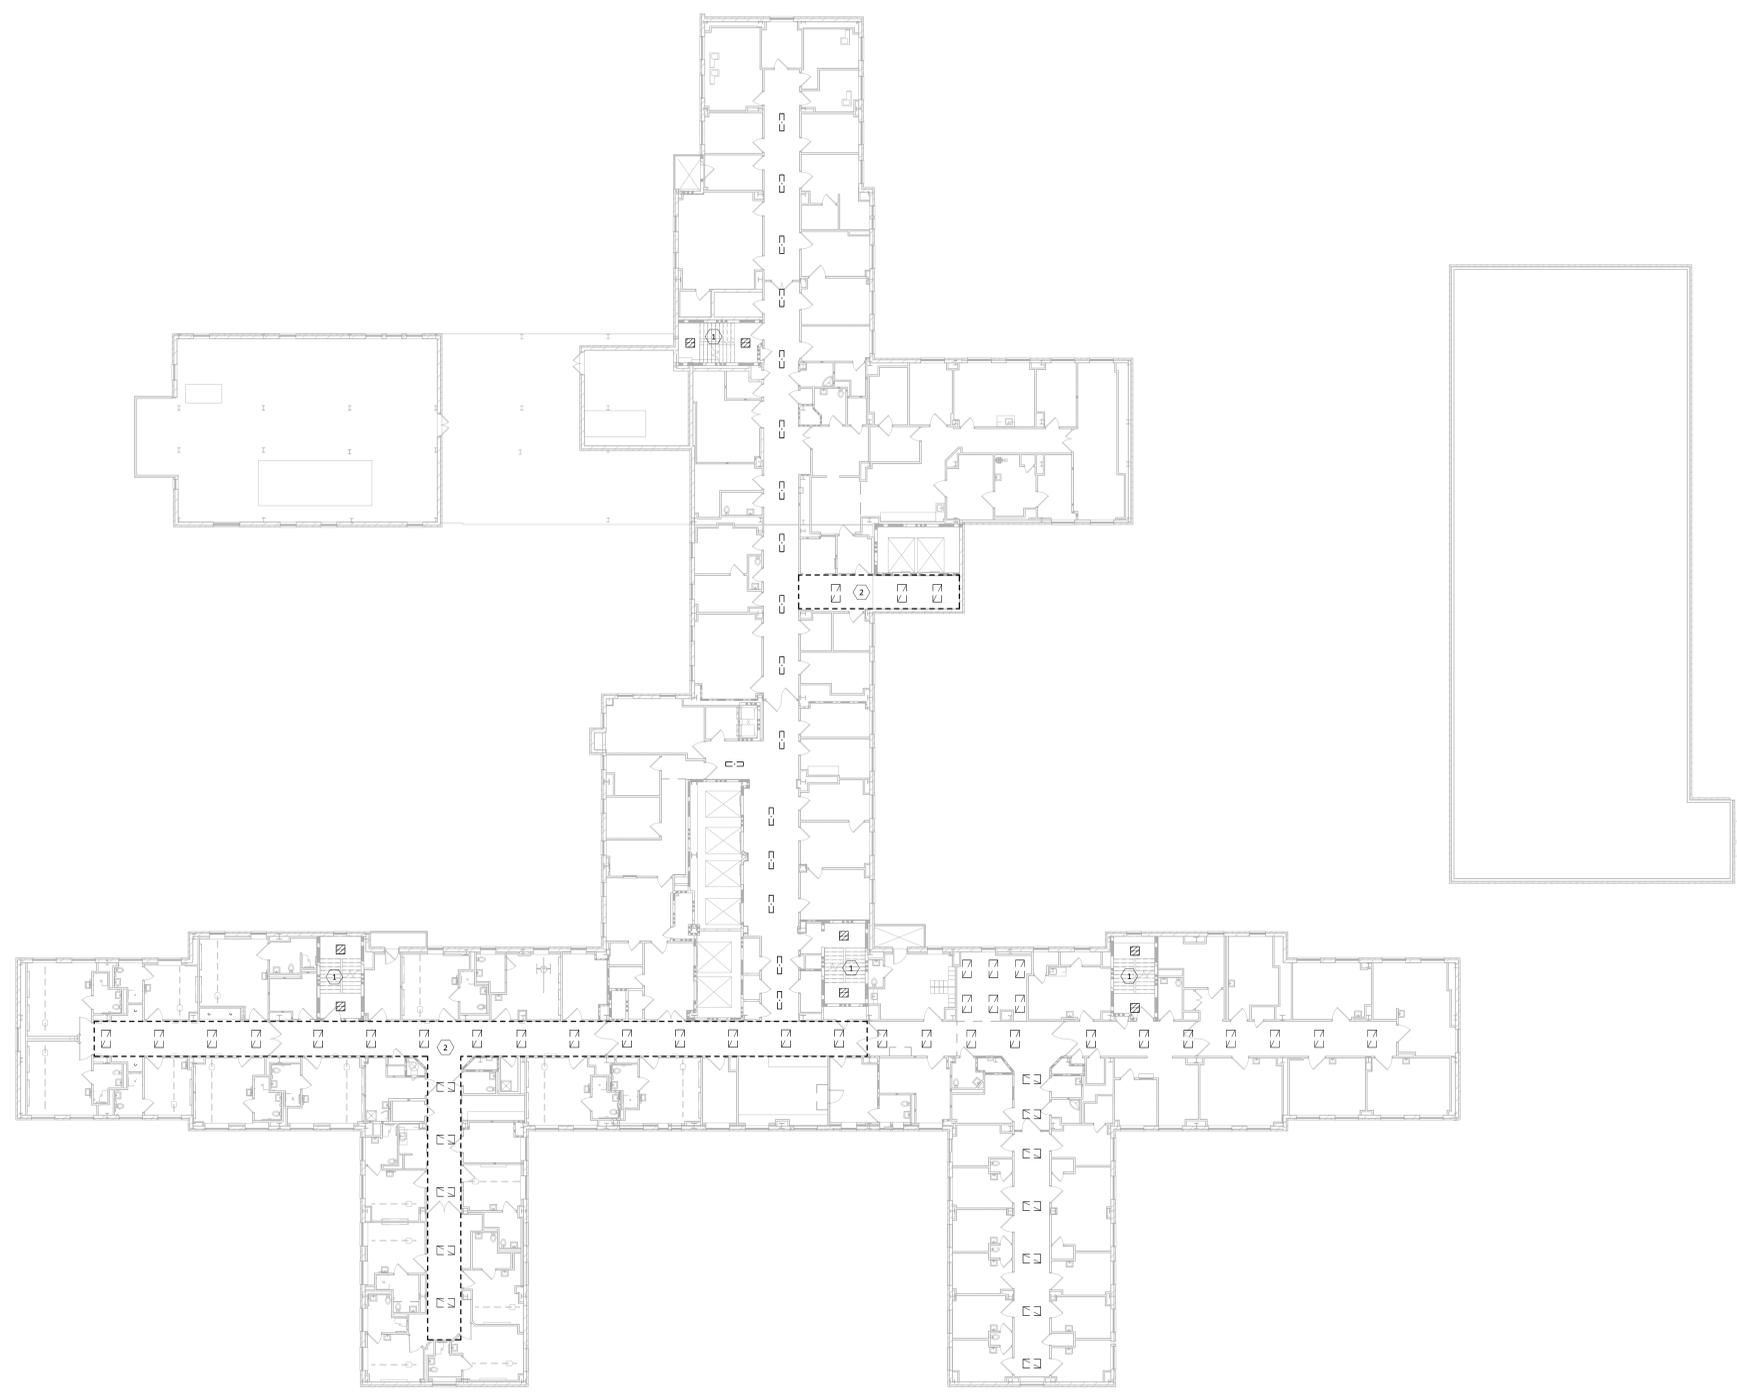


FIFTH FLOOR DEMO LIGHTING PLAN
SCALE: 1/16" = 1'-0"

one eighth inch = one foot
 one quarter inch = one foot
 three eighths inch = one foot
 one half inch = one foot
 three quarters inch = one foot
 one inch = one foot
 one and one half inches = one foot
 two inches = one foot
 three inches = one foot

95% REVIEW	08/08/14
85% REVIEW	08/21/14
100% REVIEW	10/08/14
BID DOCUMENTS	11/25/14
Revisions:	Date

CONSULTANTS:

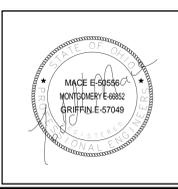

ARCHITECT/ENGINEERS:

Dynamix Engineering Ltd.
 Facility Engineering Consultants
 855 Grandview Avenue, 3rd Floor Columbus, OH 43215
 Phone: (614) 443-1178 Fax: (614) 443-1594
 Email: dynamix@dynamix-rltd.com
 DEL # 34003

Project Status	
Drawing Title FIFTH FLOOR DEMO LIGHTING PLAN	Project Title INSTALL LED LIGHTING
Approved:	Project Number 53-16-207
Location CINCINNATI VA MEDICAL CENTER	Building Number Bldg
Date 11/25/2014	Drawing Number ED105
Checked By: Checker	Drawn By: Author
Office of Construction and Facilities Management Department of Veterans Affairs	

A

B

C

D

E

F

G

H

I

J

K

L

three inches = one foot
 one and one half inches = one foot
 one inch = one foot
 three quarters inch = one foot
 one half inch = one foot
 three eighths inch = one foot
 one quarter inch = one foot
 one eighth inch = one foot
 one sixteenth inch = one foot
 C:\Users\mabaker\Documents\140033 VA Cincinnati Install LED Lighting B1 Central E.mabaker.rvt


GENERAL NOTES

A.- REMOVE ALL LIGHTING FIXTURES AS SHOWN AND REMOVE FIXTURE WHIP BACK TO CLOSEST JUNCTION BOX. MAINTAIN EXISTING CIRCUIT SERVING EACH AREA FOR RECONNECTION TO NEW FIXTURES.

PLAN NOTES

1.- PROVIDE TEMPORARY STAIRWELL LIGHTING AFTER DEMOLITION AND PRIOR TO INSTALLATION OF NEW FIXTURES. STAIRWELLS SHALL REMAIN ILLUMINATED THROUGHOUT PROJECT. IF DEDUCT ALTERNATE #1 IS ACCEPTED, THEN WORK ASSOCIATED SHALL NOT BE PERFORMED.

2.- LIGHTING IN THIS AREA IS EXISTING TO REMAIN.

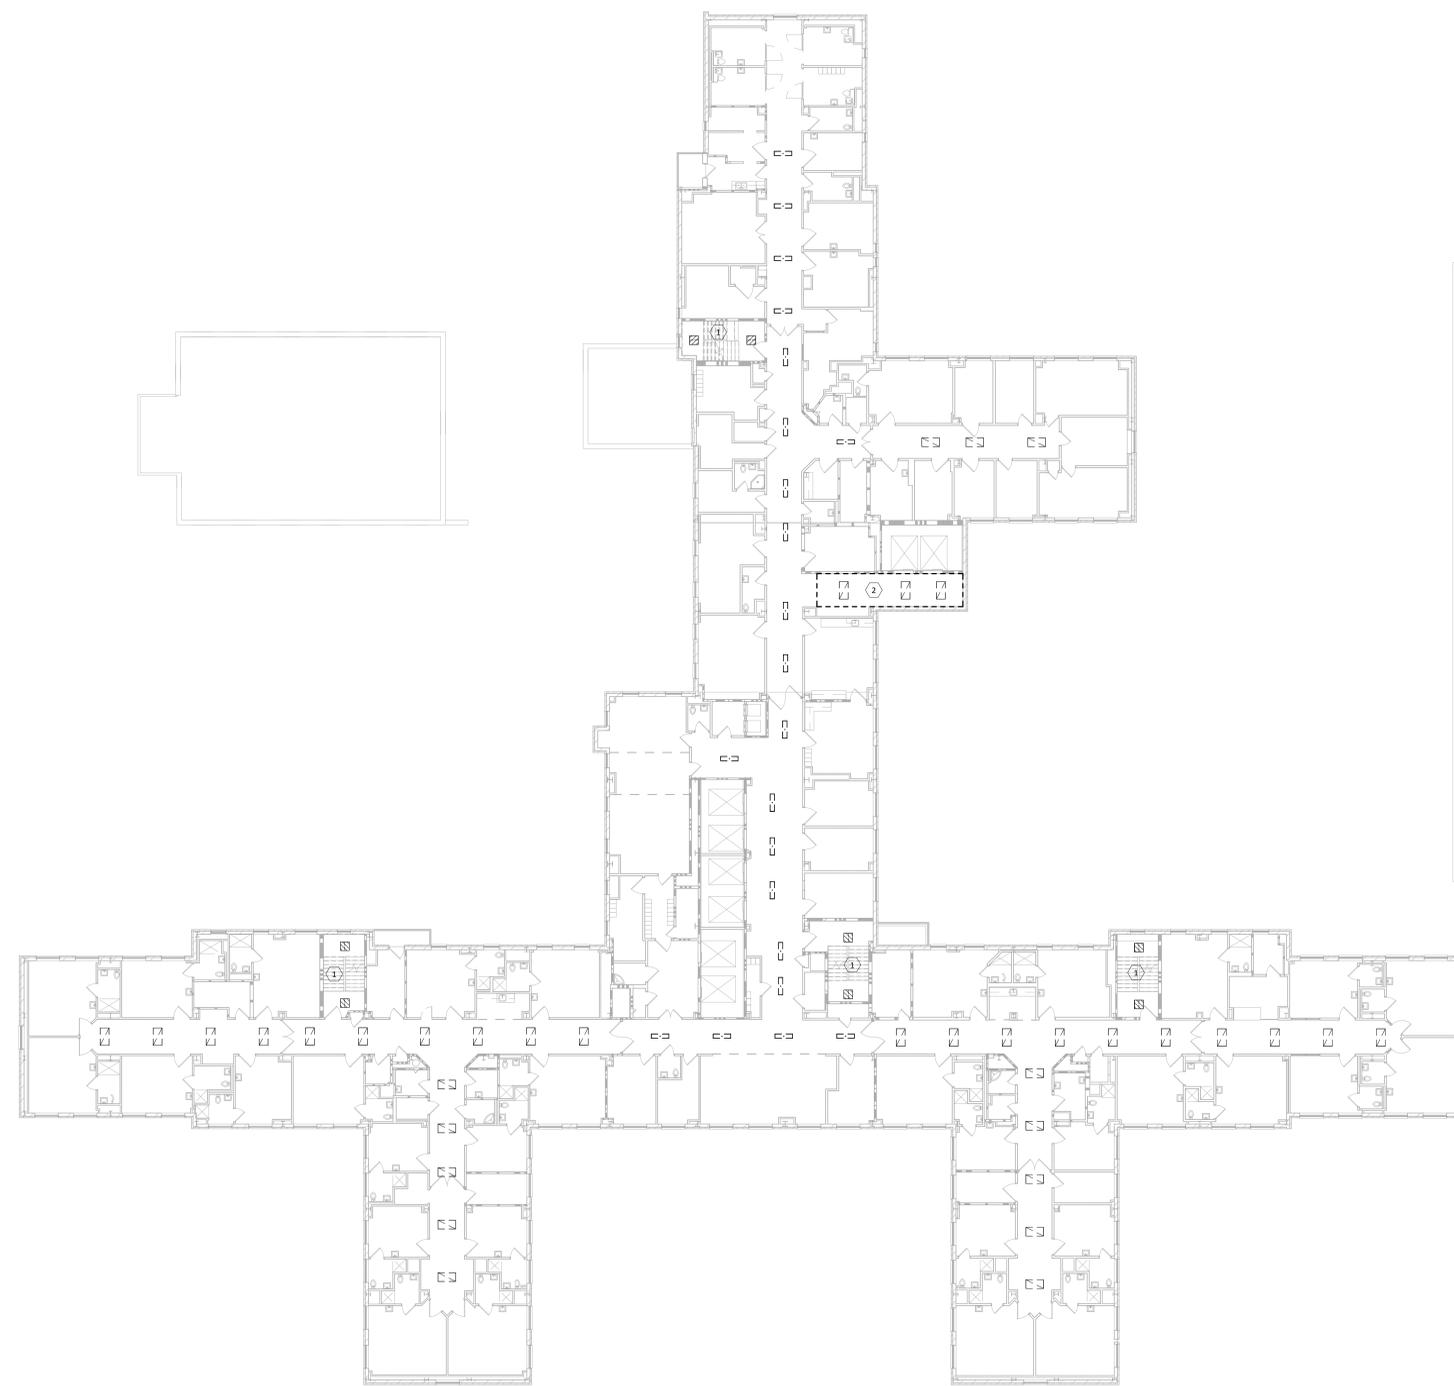

SIXTH FLOOR DEMO LIGHTING PLAN
 SCALE: 1/16" = 1'-0"

95% REVIEW	08/08/14
85% REVIEW	08/21/14
100% REVIEW	10/08/14
BID DOCUMENTS	11/25/14
Revisions:	Date

CONSULTANTS:



ARCHITECT/ENGINEERS:

Dynamix Engineering Ltd.
 Facility Engineering Consultants
 855 Grandview Avenue, 3rd Floor Columbus, OH 43215
 Phone: (614) 443-1178 Fax: (614) 443-1594
 Email: dynamix@dynamix-rtd.com
 DEL # 34004

Project Status	
Drawing Title SIXTH FLOOR DEMO LIGHTING PLAN	Project Title INSTALL LED LIGHTING
Approved:	Project Number 53-16-207 Building Number Bldg Drawing Number ED106
Location CINCINNATI VA MEDICAL CENTER	Office of Construction and Facilities Management Department of Veterans Affairs
Date 11/25/2014	Checked By: Checker Drawn By: Author

A
B
C
D
E
F

three inches = one foot
one and one half inches = one foot
one inch = one foot
three quarters inch = one foot
one half inch = one foot
three eighths inch = one foot
one quarter inch = one foot
one eighth inch = one foot

C:\Users\mabaker\Documents\140043 VA Cincinnati Install LED Lighting B1 Central E.mabaker.rvt

GENERAL NOTES


A.- REMOVE ALL LIGHTING FIXTURES AS SHOWN AND REMOVE FIXTURE WHIP BACK TO CLOSEST JUNCTION BOX. MAINTAIN EXISTING CIRCUIT SERVING EACH AREA FOR RECONNECTION TO NEW FIXTURES.

PLAN NOTES

1.- PROVIDE TEMPORARY STAIRWELL LIGHTING AFTER DEMOLITION AND PRIOR TO INSTALLATION OF NEW FIXTURES. STAIRWELLS SHALL REMAIN ILLUMINATED THROUGHOUT PROJECT. IF DEDUCT ALTERNATE #1 IS ACCEPTED, THEN WORK ASSOCIATED SHALL NOT BE PERFORMED.

2.- LIGHTING IN THIS AREA IS EXISTING TO REMAIN.

3.- THIS AREA IS A SECURE INPATIENT AREA. COORDINATE ACCESS AND SAFETY PROCEDURES WITH VA.

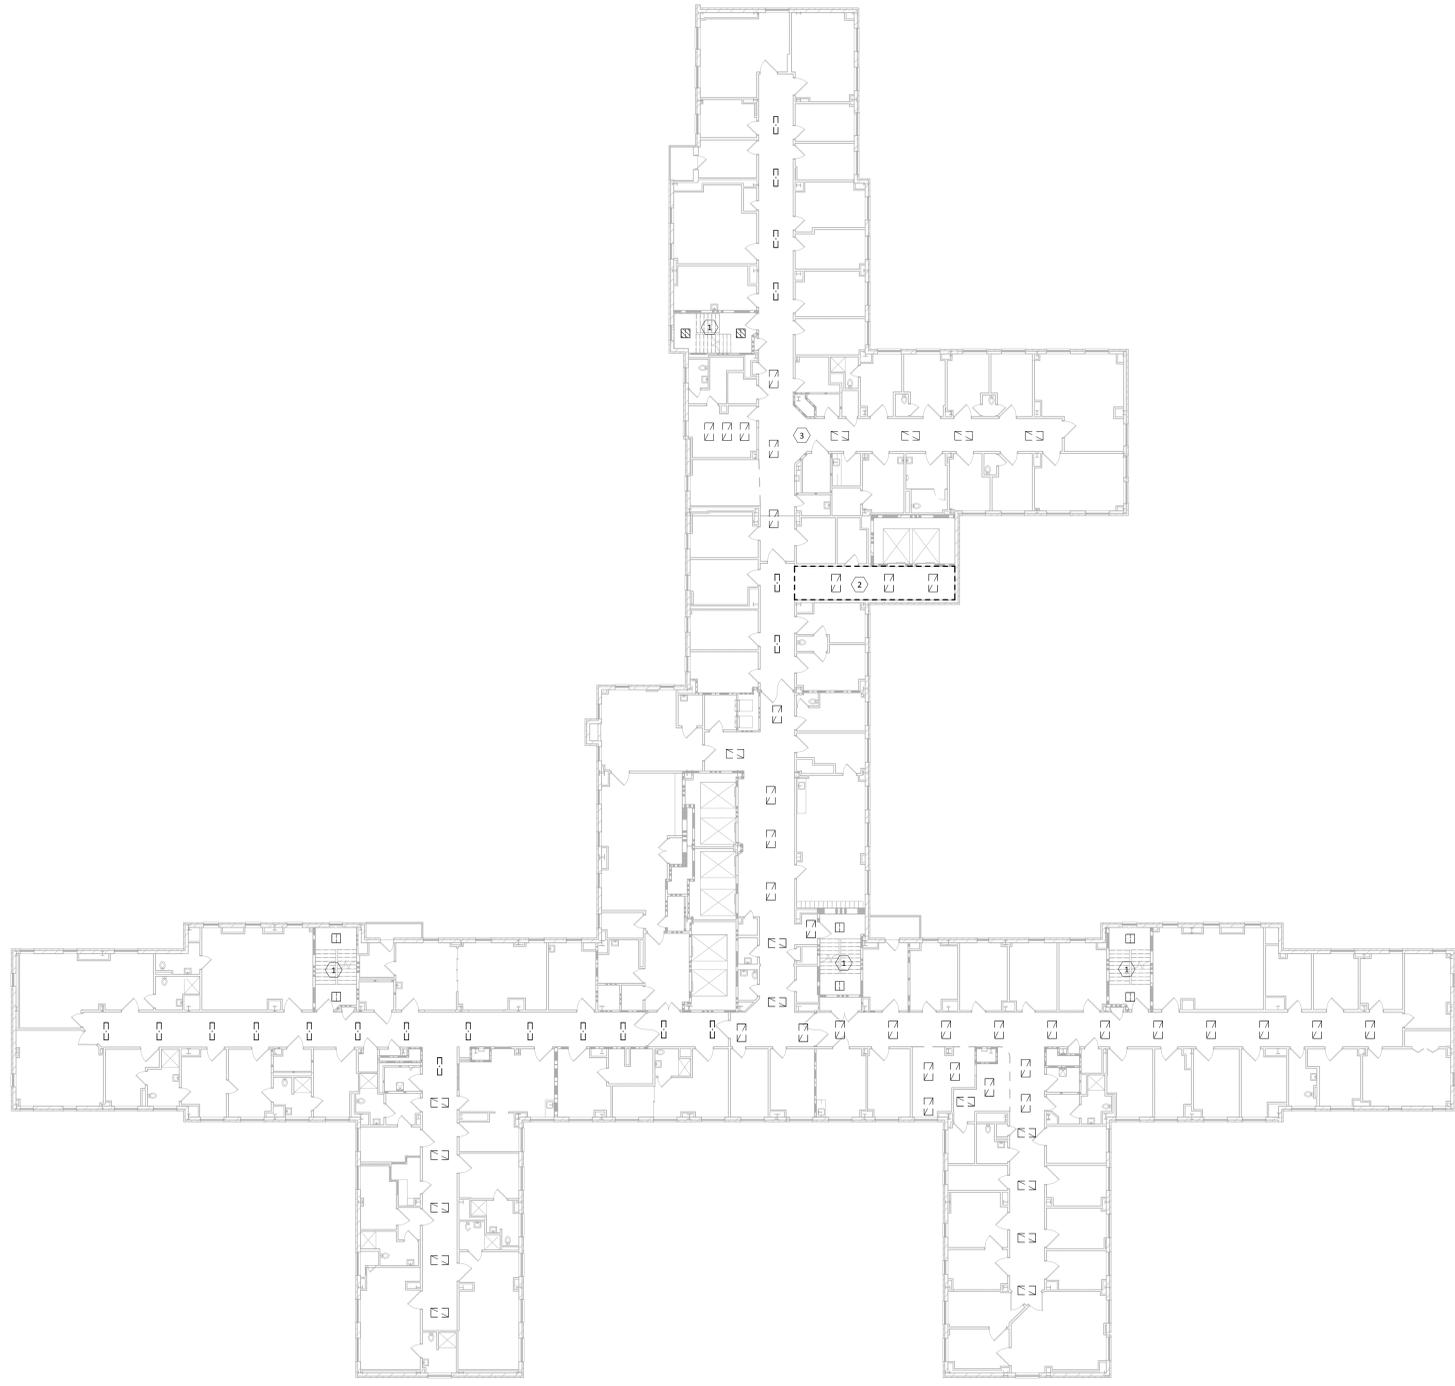

SEVENTH FLOOR DEMO LIGHTING PLAN
SCALE: 1/16" = 1'-0"

95% REVIEW	08/08/14
85% REVIEW	08/21/14
100% REVIEW	10/08/14
BID DOCUMENTS	11/25/14
Revisions:	Date

CONSULTANTS:




ARCHITECT/ENGINEERS:

Dynamix Engineering Ltd.
Facility Engineering Consultants
855 Grandview Avenue, 3rd Floor Columbus, OH 43215
Phone: (614) 443-1178 Fax: (614) 443-1594
Email: dynamix@dynamix-rtd.com
DEL # 34004

Project Status	
Drawing Title SEVENTH FLOOR DEMO LIGHTING PLAN	Project Title INSTALL LED LIGHTING
Approved:	Project Number 53-16-207
Location CINCINNATI VA MEDICAL CENTER	Building Number Bldg
Date 11/25/2014	Drawing Number ED107
Checked By: Checker	Drawn By: Author
Office of Construction and Facilities Management Department of Veterans Affairs	

one eighth inch = one foot
 one quarter inch = one foot
 three eighths inch = one foot
 one half inch = one foot
 one inch = one foot
 one and one half inches = one foot
 three inches = one foot

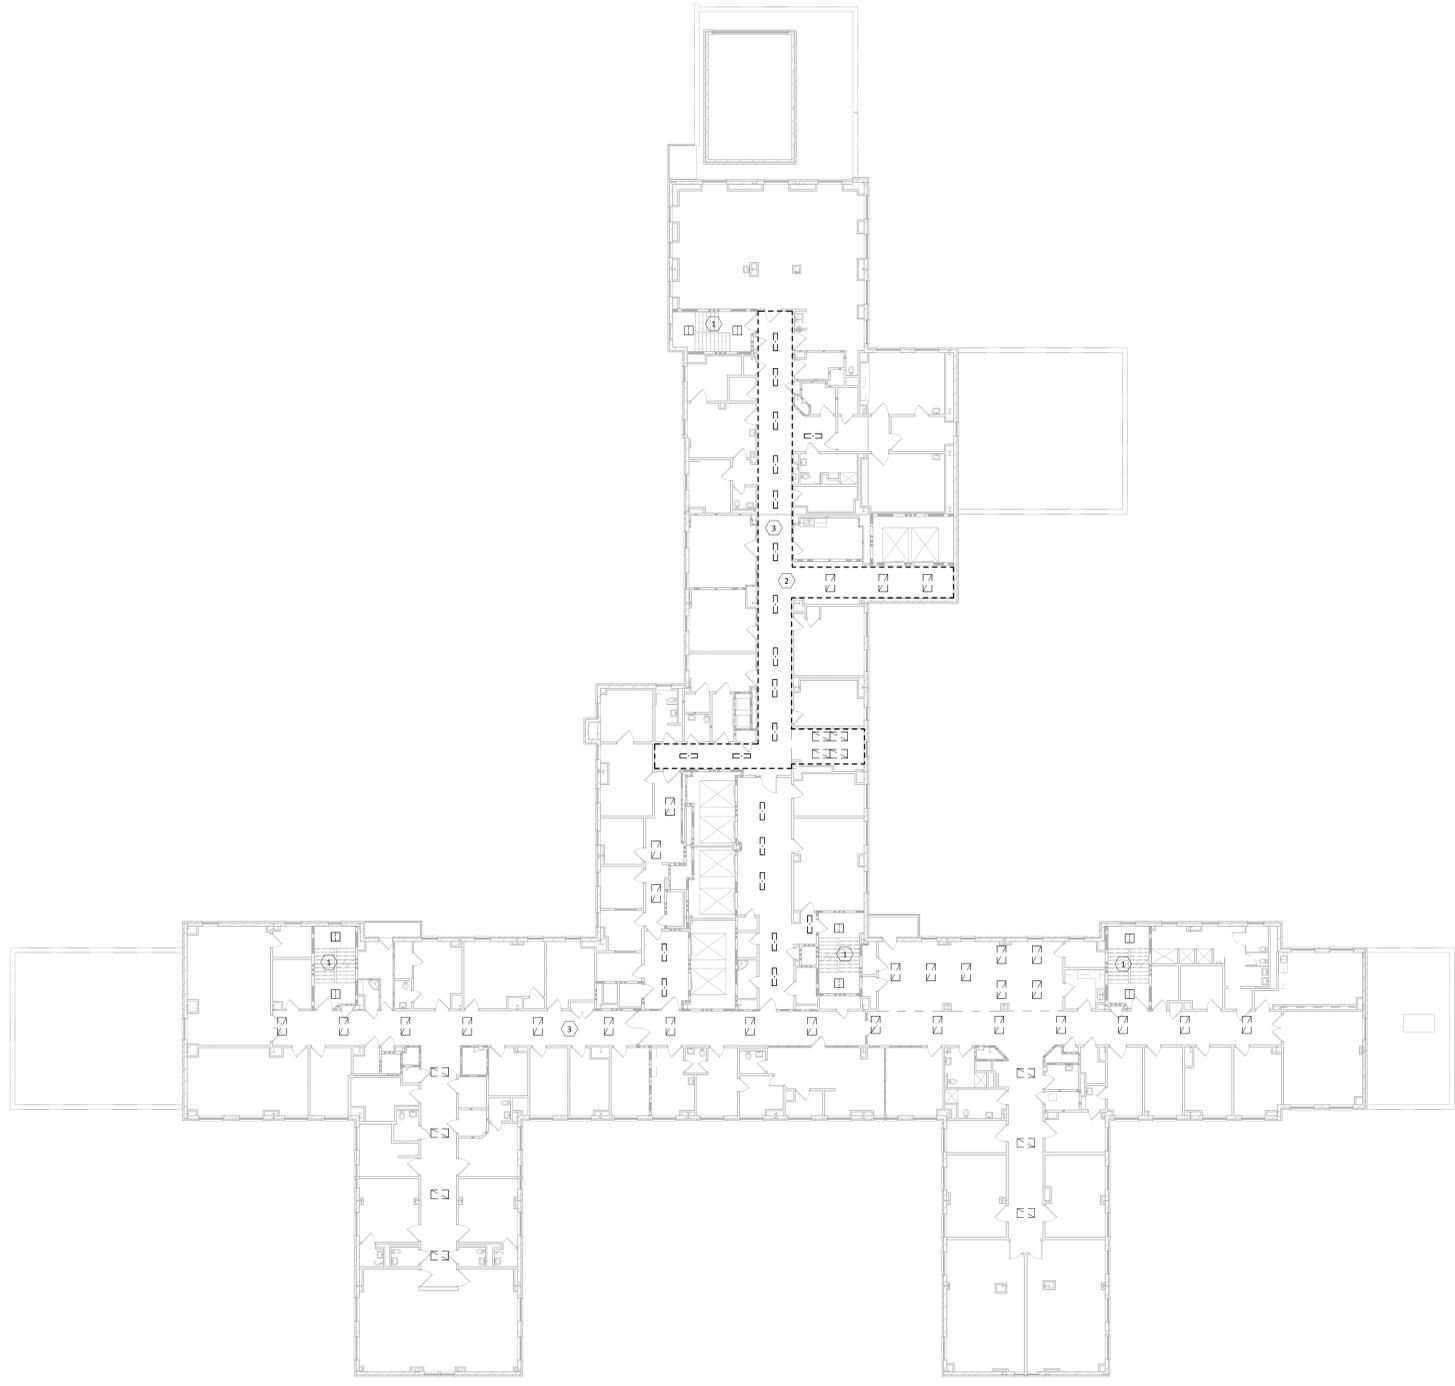

GENERAL NOTES

A.- REMOVE ALL LIGHTING FIXTURES AS SHOWN AND REMOVE FIXTURE WHIP BACK TO CLOSEST JUNCTION BOX. MAINTAIN EXISTING CIRCUIT SERVING EACH AREA FOR RECONNECTION TO NEW FIXTURES.

PLAN NOTES

1.- PROVIDE TEMPORARY STAIRWELL LIGHTING AFTER DEMOLITION AND PRIOR TO INSTALLATION OF NEW FIXTURES. STAIRWELLS SHALL REMAIN ILLUMINATED THROUGHOUT PROJECT. IF DEDUCT ALTERNATE #1 IS ACCEPTED, THEN WORK ASSOCIATED SHALL NOT BE PERFORMED.

2.- LIGHTING IN THIS AREA IS EXISTING TO REMAIN.

3.- THIS AREA IS A SECURE INPATIENT AREA. COORDINATE ACCESS AND SAFETY PROCEDURES WITH VA.

EIGHTH FLOOR DEMO LIGHTING PLAN
 SCALE: 1/16" = 1'-0"

Revisions: 95% REVIEW 08/08/14 85% REVIEW 08/21/14 100% REVIEW 10/08/14 BID DOCUMENTS 11/25/14	CONSULTANTS:			ARCHITECT/ENGINEERS: Dynamix Engineering Ltd. Facility Engineering Consultants 855 Grandview Avenue, 3rd Floor Columbus, OH 43215 Phone: (614) 443-1178 Fax: (614) 443-1594 Email: dynamix@dynamix-rltd.com DEL # 34003		Drawing Title EIGHTH FLOOR DEMO LIGHTING PLAN		Project Title INSTALL LED LIGHTING		Project Number 53-16-207		Office of Construction and Facilities Management
	Approved:			Location CINCINNATI VA MEDICAL CENTER		Building Number Bldg		Drawing Number ED108				
Date 11/25/2014		Checked By: Checker		Drawn By: Author		Department of Veterans Affairs						

three inches = one foot
 one and one half inches = one foot
 one inch = one foot
 three quarters inch = one foot
 one half inch = one foot
 three eighths inch = one foot
 one quarter inch = one foot
 one eighth inch = one foot
 C:\Users\mabaker\Documents\140043 VA Cincinnati Install LED Lighting B1 Central E.mabaker.rvt


GENERAL NOTES

A.- REMOVE ALL LIGHTING FIXTURES AS SHOWN AND REMOVE FIXTURE WHIP BACK TO CLOSEST JUNCTION BOX. MAINTAIN EXISTING CIRCUIT SERVING EACH AREA FOR RECONNECTION TO NEW FIXTURES.

PLAN NOTES

1.- PROVIDE TEMPORARY STAIRWELL LIGHTING AFTER DEMOLITION AND PRIOR TO INSTALLATION OF NEW FIXTURES. STAIRWELLS SHALL REMAIN ILLUMINATED THROUGHOUT PROJECT. IF DEDUCT ALTERNATE #1 IS ACCEPTED, THEN WORK ASSOCIATED SHALL NOT BE PERFORMED.

2.- LIGHTING IN THIS AREA IS EXISTING TO REMAIN.

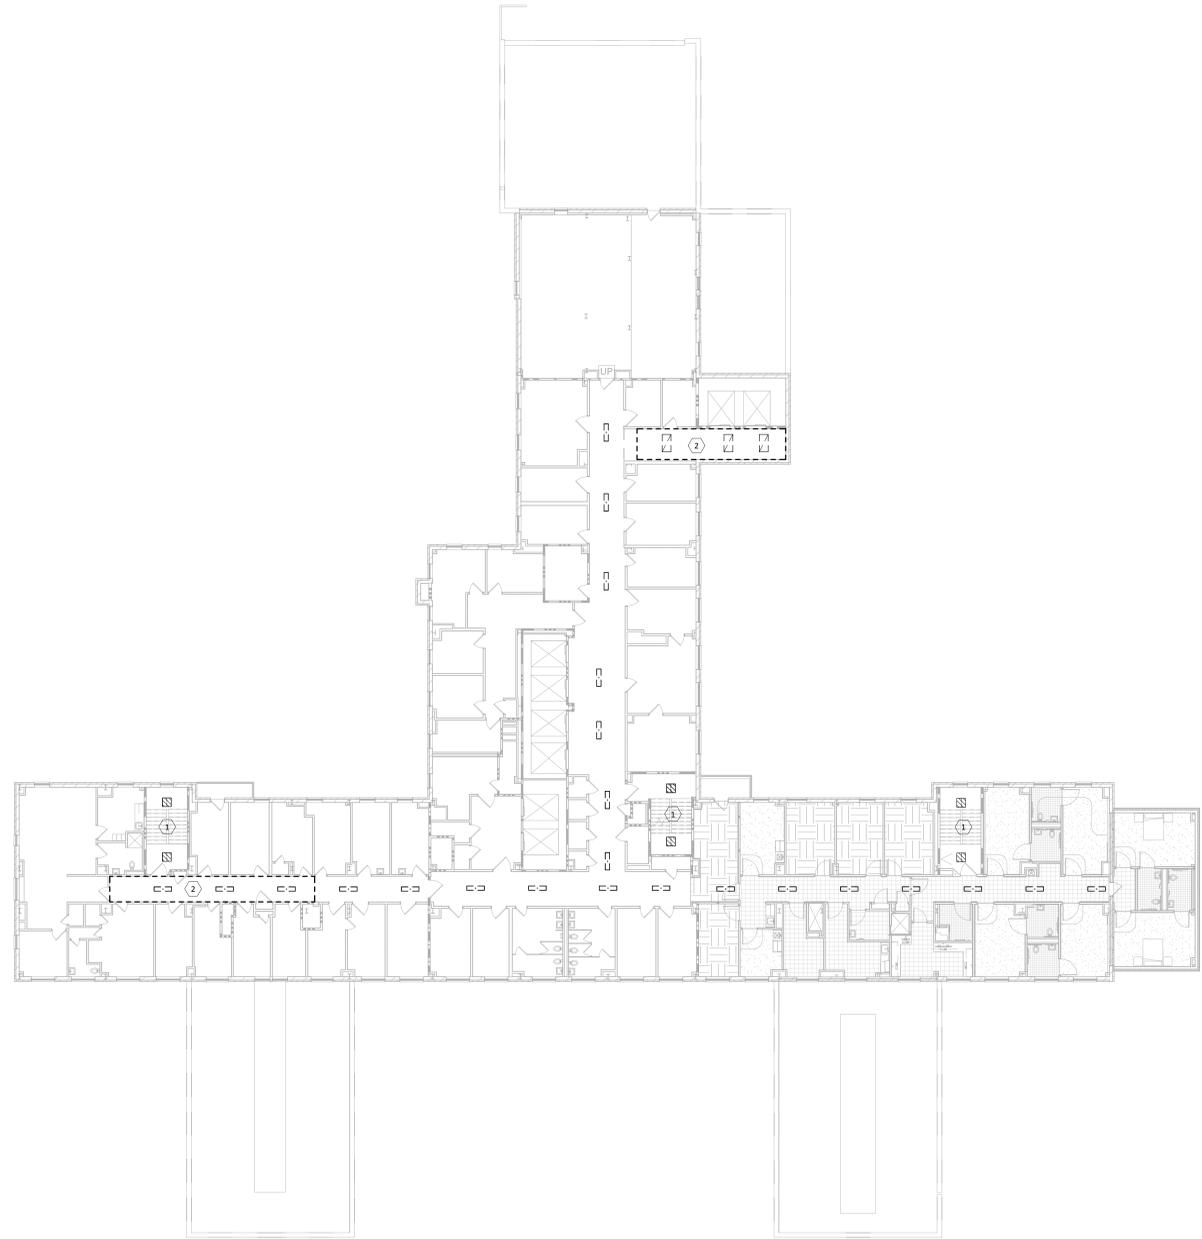

NINTH FLOOR DEMO LIGHTING PLAN
 SCALE: 1/16" = 1'-0"


95% REVIEW 85% REVIEW 100% REVIEW BID DOCUMENTS Revisions:	08/08/14 08/21/14 10/08/14 11/25/14 Date	CONSULTANTS:		ARCHITECT/ENGINEERS: Engineering Ltd. Facility Engineering Consultants 855 Grandview Avenue, 3rd Floor Columbus, OH 43215 Phone: (614) 443-1178 Fax: (614) 443-1594 Email: dynamix@dynamix-rltd.com DEL # 34003	Project Status				Office of Construction and Facilities Management
					Drawing Title NINTH FLOOR DEMO LIGHTING PLAN	Project Title INSTALL LED LIGHTING	Project Number 53-16-207	Building Number Bldg	
Date 11/25/2014		Checked By: Checker	Drawn By: Author						

GENERAL NOTES

A. REMOVE ALL LIGHTING FIXTURES AS SHOWN AND REMOVE FIXTURE WHIP BACK TO CLOSEST JUNCTION BOX. MAINTAIN EXISTING CIRCUIT SERVING EACH AREA FOR RECONNECTION TO NEW FIXTURES.


PLAN NOTES

1. PROVIDE TEMPORARY STAIRWELL LIGHTING AFTER DEMOLITION AND PRIOR TO INSTALLATION OF NEW FIXTURES. STAIRWELLS SHALL REMAIN ILLUMINATED THROUGHOUT PROJECT. IF DUCT ALTERNATE #1 IS ACCEPTED, THEN WORK ASSOCIATED SHALL NOT BE PERFORMED.

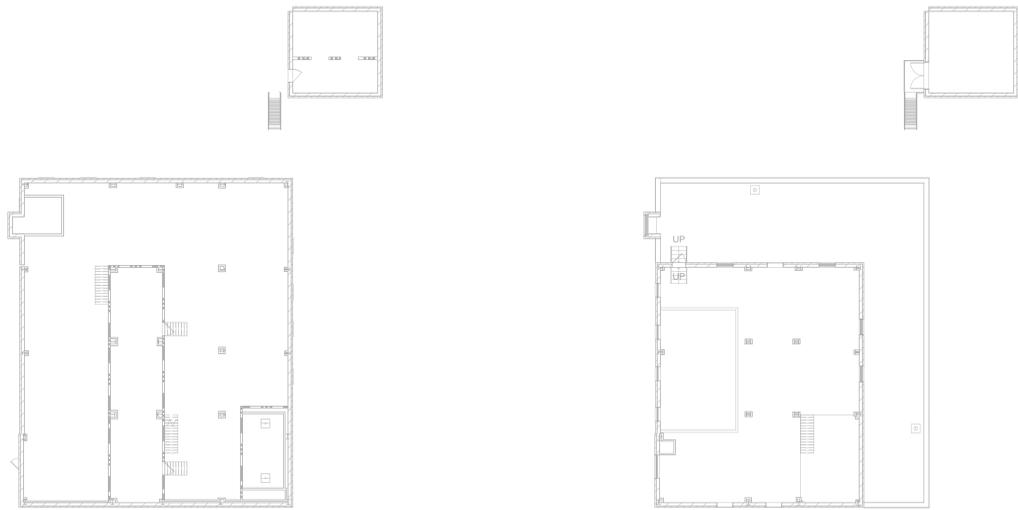

PENTHOUSE MEZZANINE DEMO LIGHTING PLAN
SCALE: 1/16" = 1'-0"

MECHANICAL DEMO LIGHTING PLAN
SCALE: 1/16" = 1'-0"

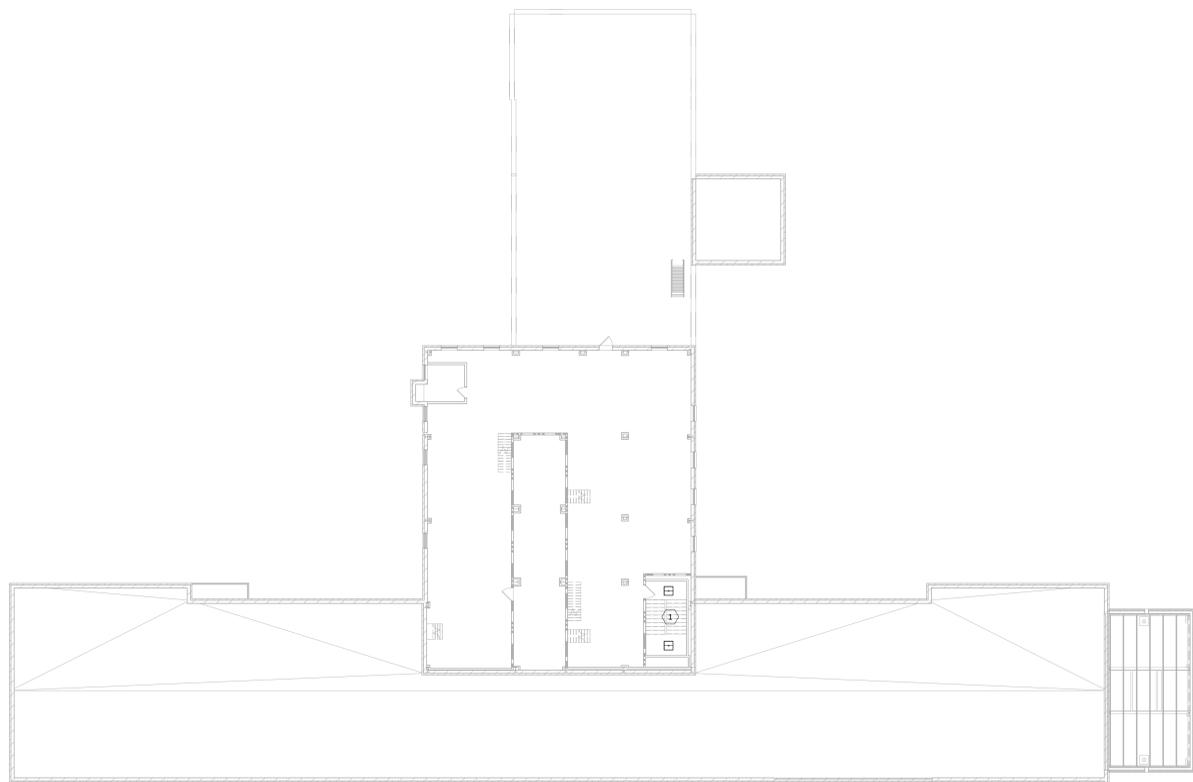


PENTHOUSE DEMO LIGHTING PLAN
SCALE: 1/16" = 1'-0"

three inches = one foot
one and one half inches = one foot
one inch = one foot
three quarters inch = one foot
one half inch = one foot
three eighths inch = one foot
one quarter inch = one foot
one eighth inch = one foot

95% REVIEW	08/08/14
85% REVIEW	08/21/14
100% REVIEW	10/08/14
BID DOCUMENTS	11/25/14
Revisions:	Date

CONSULTANTS:

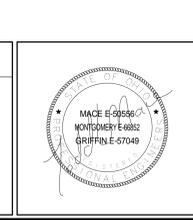


ARCHITECT/ENGINEERS:

Dynamix Engineering Ltd.
Facility Engineering Consultants
855 Grandview Avenue, 3rd Floor Columbus, OH 43215
Phone: (614) 443-1178 Fax: (614) 443-1594
Email: dynamix@dynamix-rltd.com
DEL # 34003

PENTHOUSE, MEZZANINE & MECHANICAL DEMO LIGHTING PLAN		Project Status		Office of Construction and Facilities Management Department of Veterans Affairs
Project Title INSTALL LED LIGHTING		Project Number 53-16-207		
Approved:		Location CINCINNATI VA MEDICAL CENTER		ED110
Date 11/25/2014		Checked By: Checker	Drawn By: Author	

three inches = one foot
 one and one half inches = one foot
 one inch = one foot
 three quarters inch = one foot
 one half inch = one foot
 three eighths inch = one foot
 one quarter inch = one foot
 one eighth inch = one foot

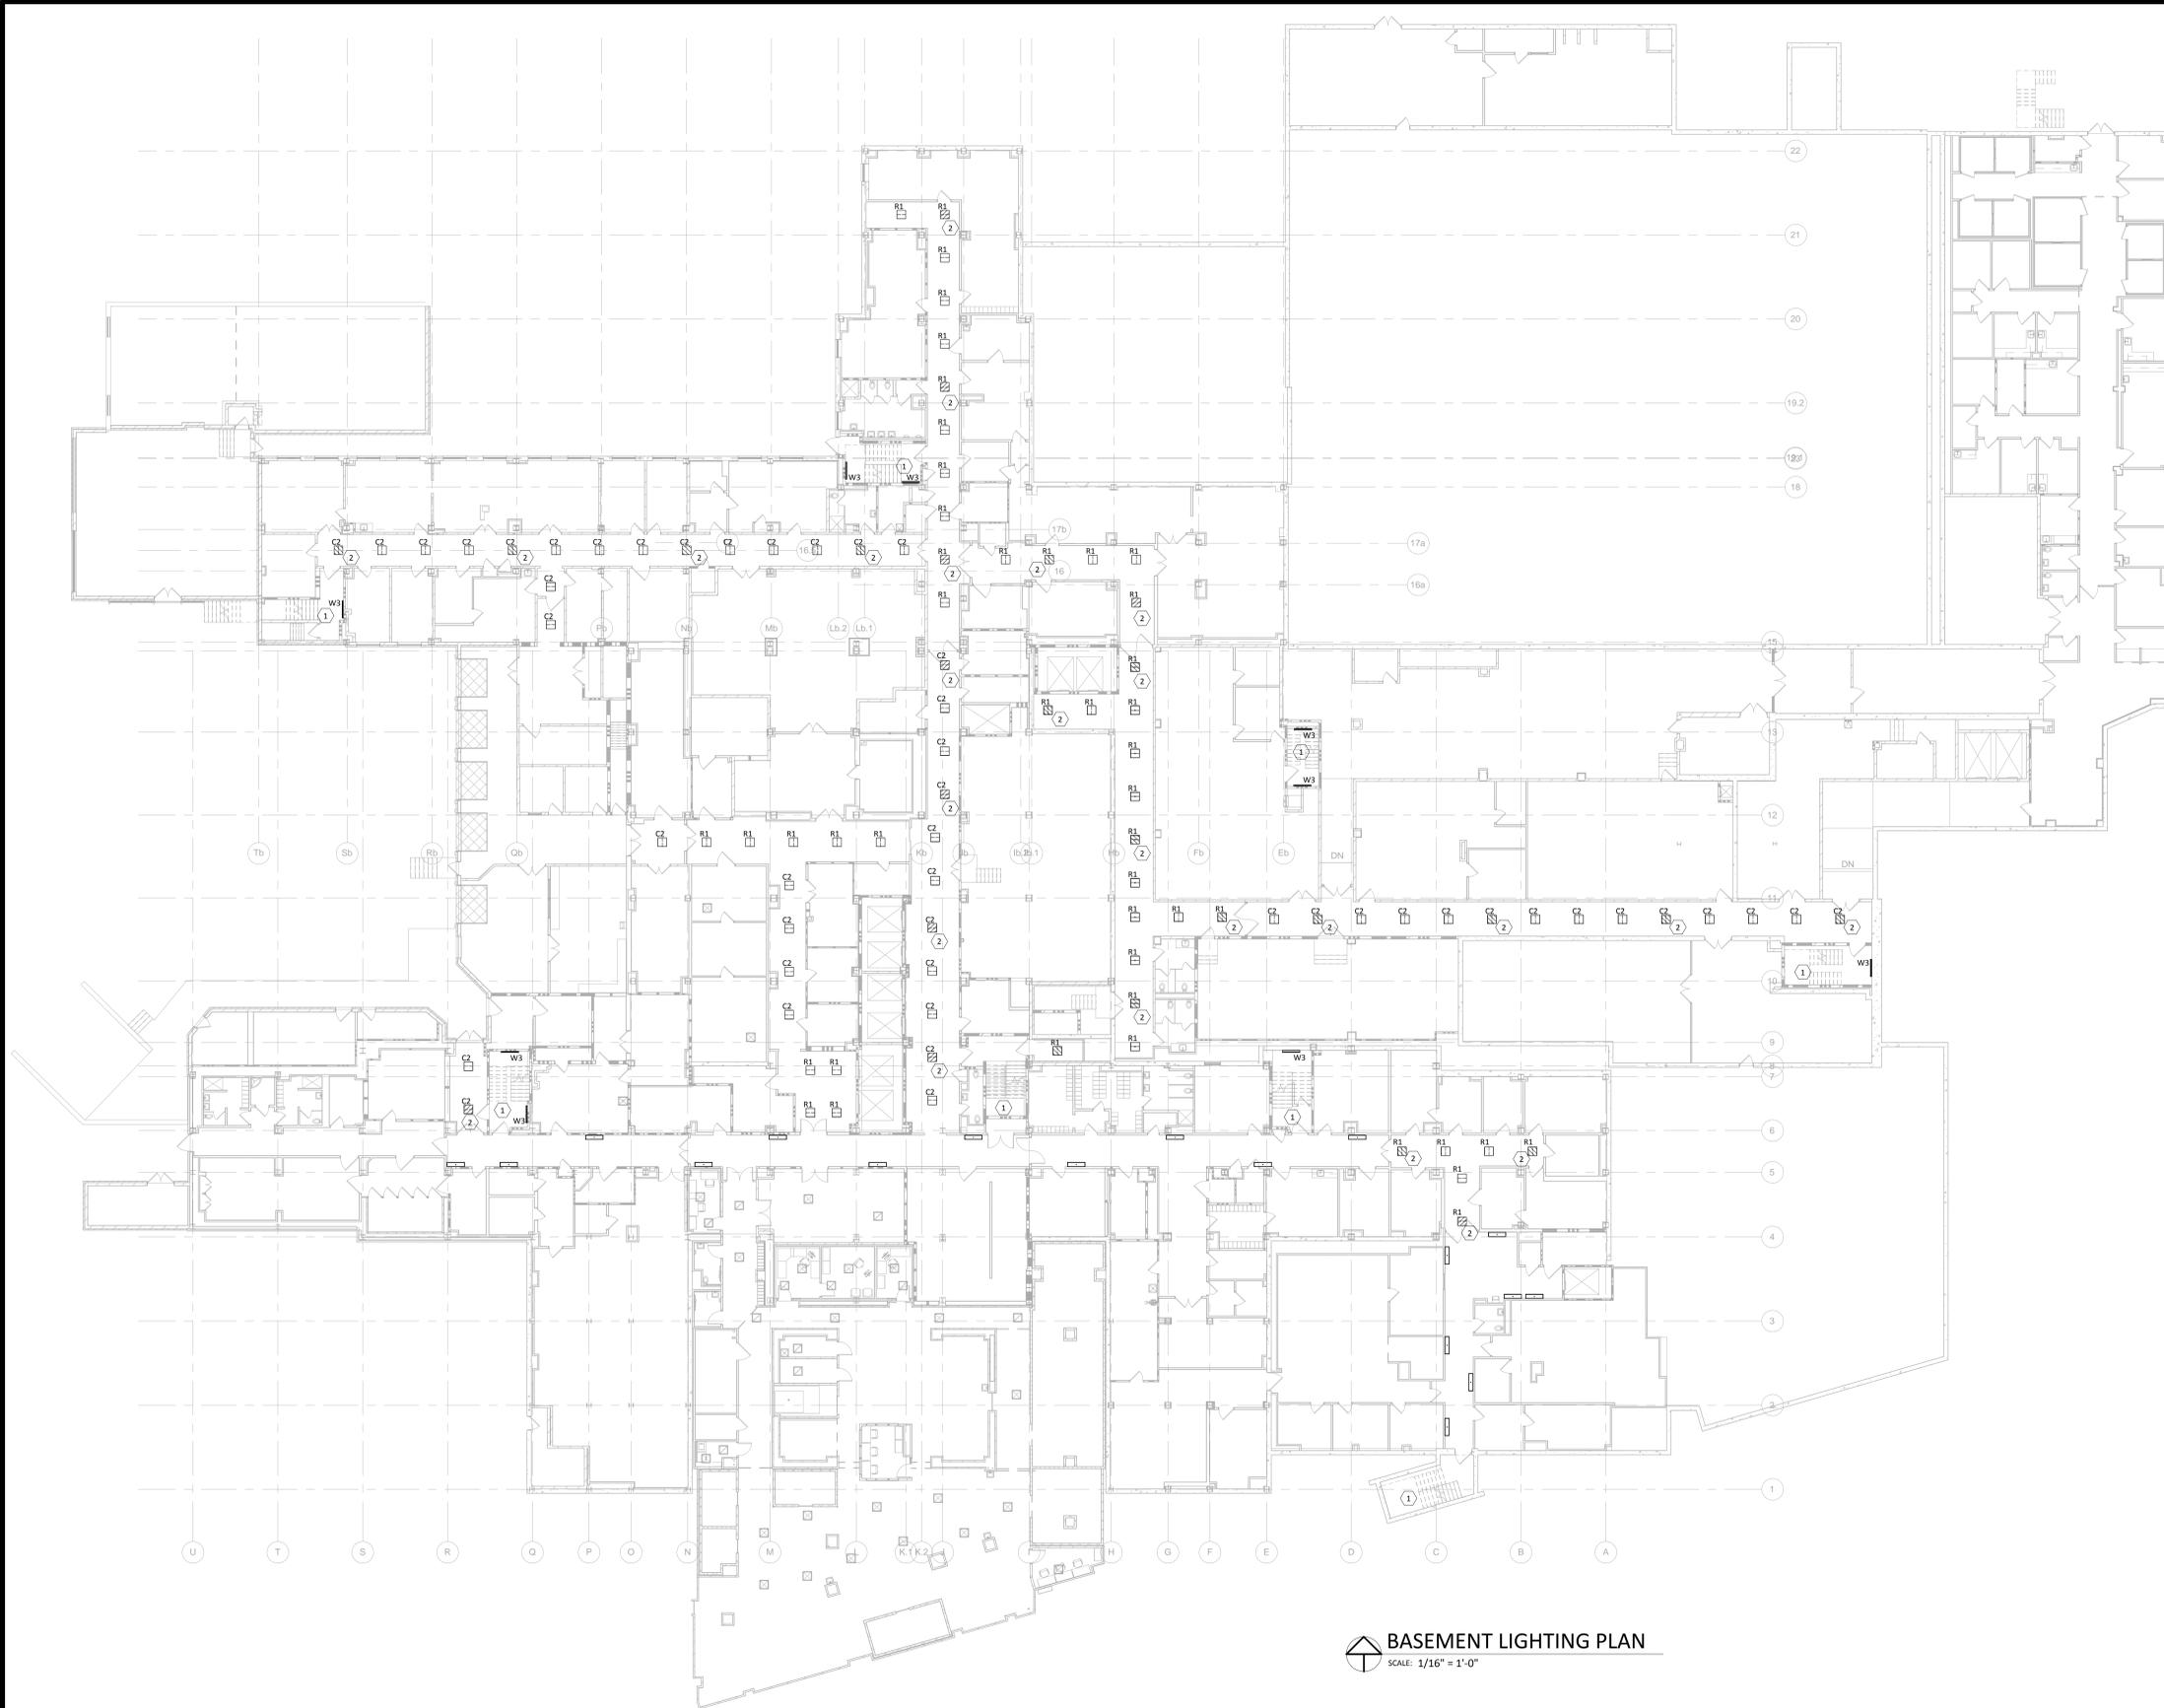

GENERAL NOTES

A- UNLESS NOTED OTHERWISE, CONNECT ALL NEW LIGHTING FIXTURES TO EXISTING LIGHTING CIRCUIT SERVING AREA. EXTEND NEW CIRCUITING TO NEW FIXTURES.

B- ALL WORK ON THIS FLOOR IS PART OF DEDUCT ALTERNATE #1.

C- CONTRACTOR IS RESPONSIBLE FOR ALL PATCHING AND PAINTING OF MODIFIED SURFACES. THE PATCHING SHALL BE PAINTED TO MATCH EXISTING FINISHES.

PLAN NOTES

1- CONNECT NEW STAIRWELL LIGHTING TO EXISTING CIRCUIT SERVING STAIRWELL. EXTEND CIRCUITING TO NEW FIXTURES ON ALL STAIRWELL SURFACES WHERE PATCHING IS APPLIED, THE ENTIRE SURFACE SHALL BE PAINTED TO MATCH EXISTING CONDITIONS.

2- CONNECT EMERGENCY/NIGHT LIGHT FIXTURE TO CLOSET EMERGENCY LIGHTING CIRCUIT, SERVING AREA. EXTEND NEW CIRCUITING AS NECESSARY.

BASEMENT LIGHTING PLAN
 SCALE: 1/16" = 1'-0"

95% REVIEW	08/08/14
85% REVIEW	08/21/14
100% REVIEW	10/08/14
BID DOCUMENTS	11/25/14
Revisions:	Date

CONSULTANTS:



ARCHITECT/ENGINEERS:

Dynamix Engineering Ltd.
 Facility Engineering Consultants
 855 Grandview Avenue, 3rd Floor Columbus, OH 43215
 Phone: (614) 443-1178 Fax: (614) 443-1594
 Email: dynamix@dynamix-rltd.com
 DEL # 34004

Project Status		Office of Construction and Facilities Management	
Drawing Title	Project Title	Project Number	Department of Veterans Affairs
BASEMENT LIGHTING PLAN	INSTALL LED LIGHTING	53-16-207	
Approved:	Location	Building Number	E100
	CINCINNATI VA MEDICAL CENTER	Bldg	
	Date	Checked By:	
	11/25/2014	Checker	
		Drawn By:	
		Author	

three inches = one foot
 one and one half inches = one foot
 one inch = one foot
 three quarters inch = one foot
 one half inch = one foot
 three eighths inch = one foot
 one quarter inch = one foot
 one eighth inch = one foot
 C:\Users\mabaker\Documents\140033 VA Cincinnati Install LED Lighting B1 Central E.mabaker.rvt




PIPE BASEMENT LIGHTING PLAN
 SCALE: 1/16" = 1'-0"


SUB BASEMENT LIGHTING PLAN
 SCALE: 1/16" = 1'-0"

GENERAL NOTES

A- UNLESS NOTED OTHERWISE, CONNECT ALL NEW LIGHTING FIXTURES TO EXISTING LIGHTING CIRCUIT SERVING AREA. EXTEND NEW CIRCUITING TO NEW FIXTURES.

B- ALL WORK ON THIS FLOOR IS PART OF DEDUCT ALTERNATE #1.


C- CONTRACTOR IS RESPONSIBLE FOR ALL PATCHING AND PAINTING OF MODIFIED SURFACES. THE PATCHING SHALL BE PAINTED TO MATCH EXISTING FINISHES.

PLAN NOTES

1- CONNECT NEW STAIRWELL LIGHTING TO EXISTING CIRCUIT SERVING STAIRWELL. EXTEND CIRCUITING TO NEW FIXTURES ON ALL STAIRWELL SURFACES WHERE PATCHING IS APPLIED. THE ENTIRE SURFACE SHALL BE PAINTED TO MATCH EXISTING CONDITIONS.

95% REVIEW	08/08/14
85% REVIEW	08/21/14
100% REVIEW	10/08/14
BID DOCUMENTS	11/25/14
Revisions:	Date

CONSULTANTS:

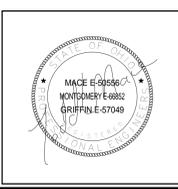


ARCHITECT/ENGINEERS:

Dynamix Engineering Ltd.
 Facility Engineering Consultants
 855 Grandview Avenue, 3rd Floor Columbus, OH 43215
 Phone: (614) 443-1178 Fax: (614) 443-1594
 Email: dynamix@dynamix-rltd.com
 DEL # 34003

Project Status Drawing Title SUB BASEMENT & PIPE BASEMENT LIGHTING PLAN		Project Title INSTALL LED LIGHTING		Project Number 53-16-207	Office of Construction and Facilities Management  Department of Veterans Affairs
		Location CINCINNATI VA MEDICAL CENTER		Building Number Bldg	
Approved:		Date 11/25/2014	Checked By: Checker	Drawing Number E100A	Drawn By: Author

three inches = one foot
 one and one half inches = one foot
 one inch = one foot
 three quarters inch = one foot
 one half inch = one foot
 three eighths inch = one foot
 one quarter inch = one foot
 one eighth inch = one foot

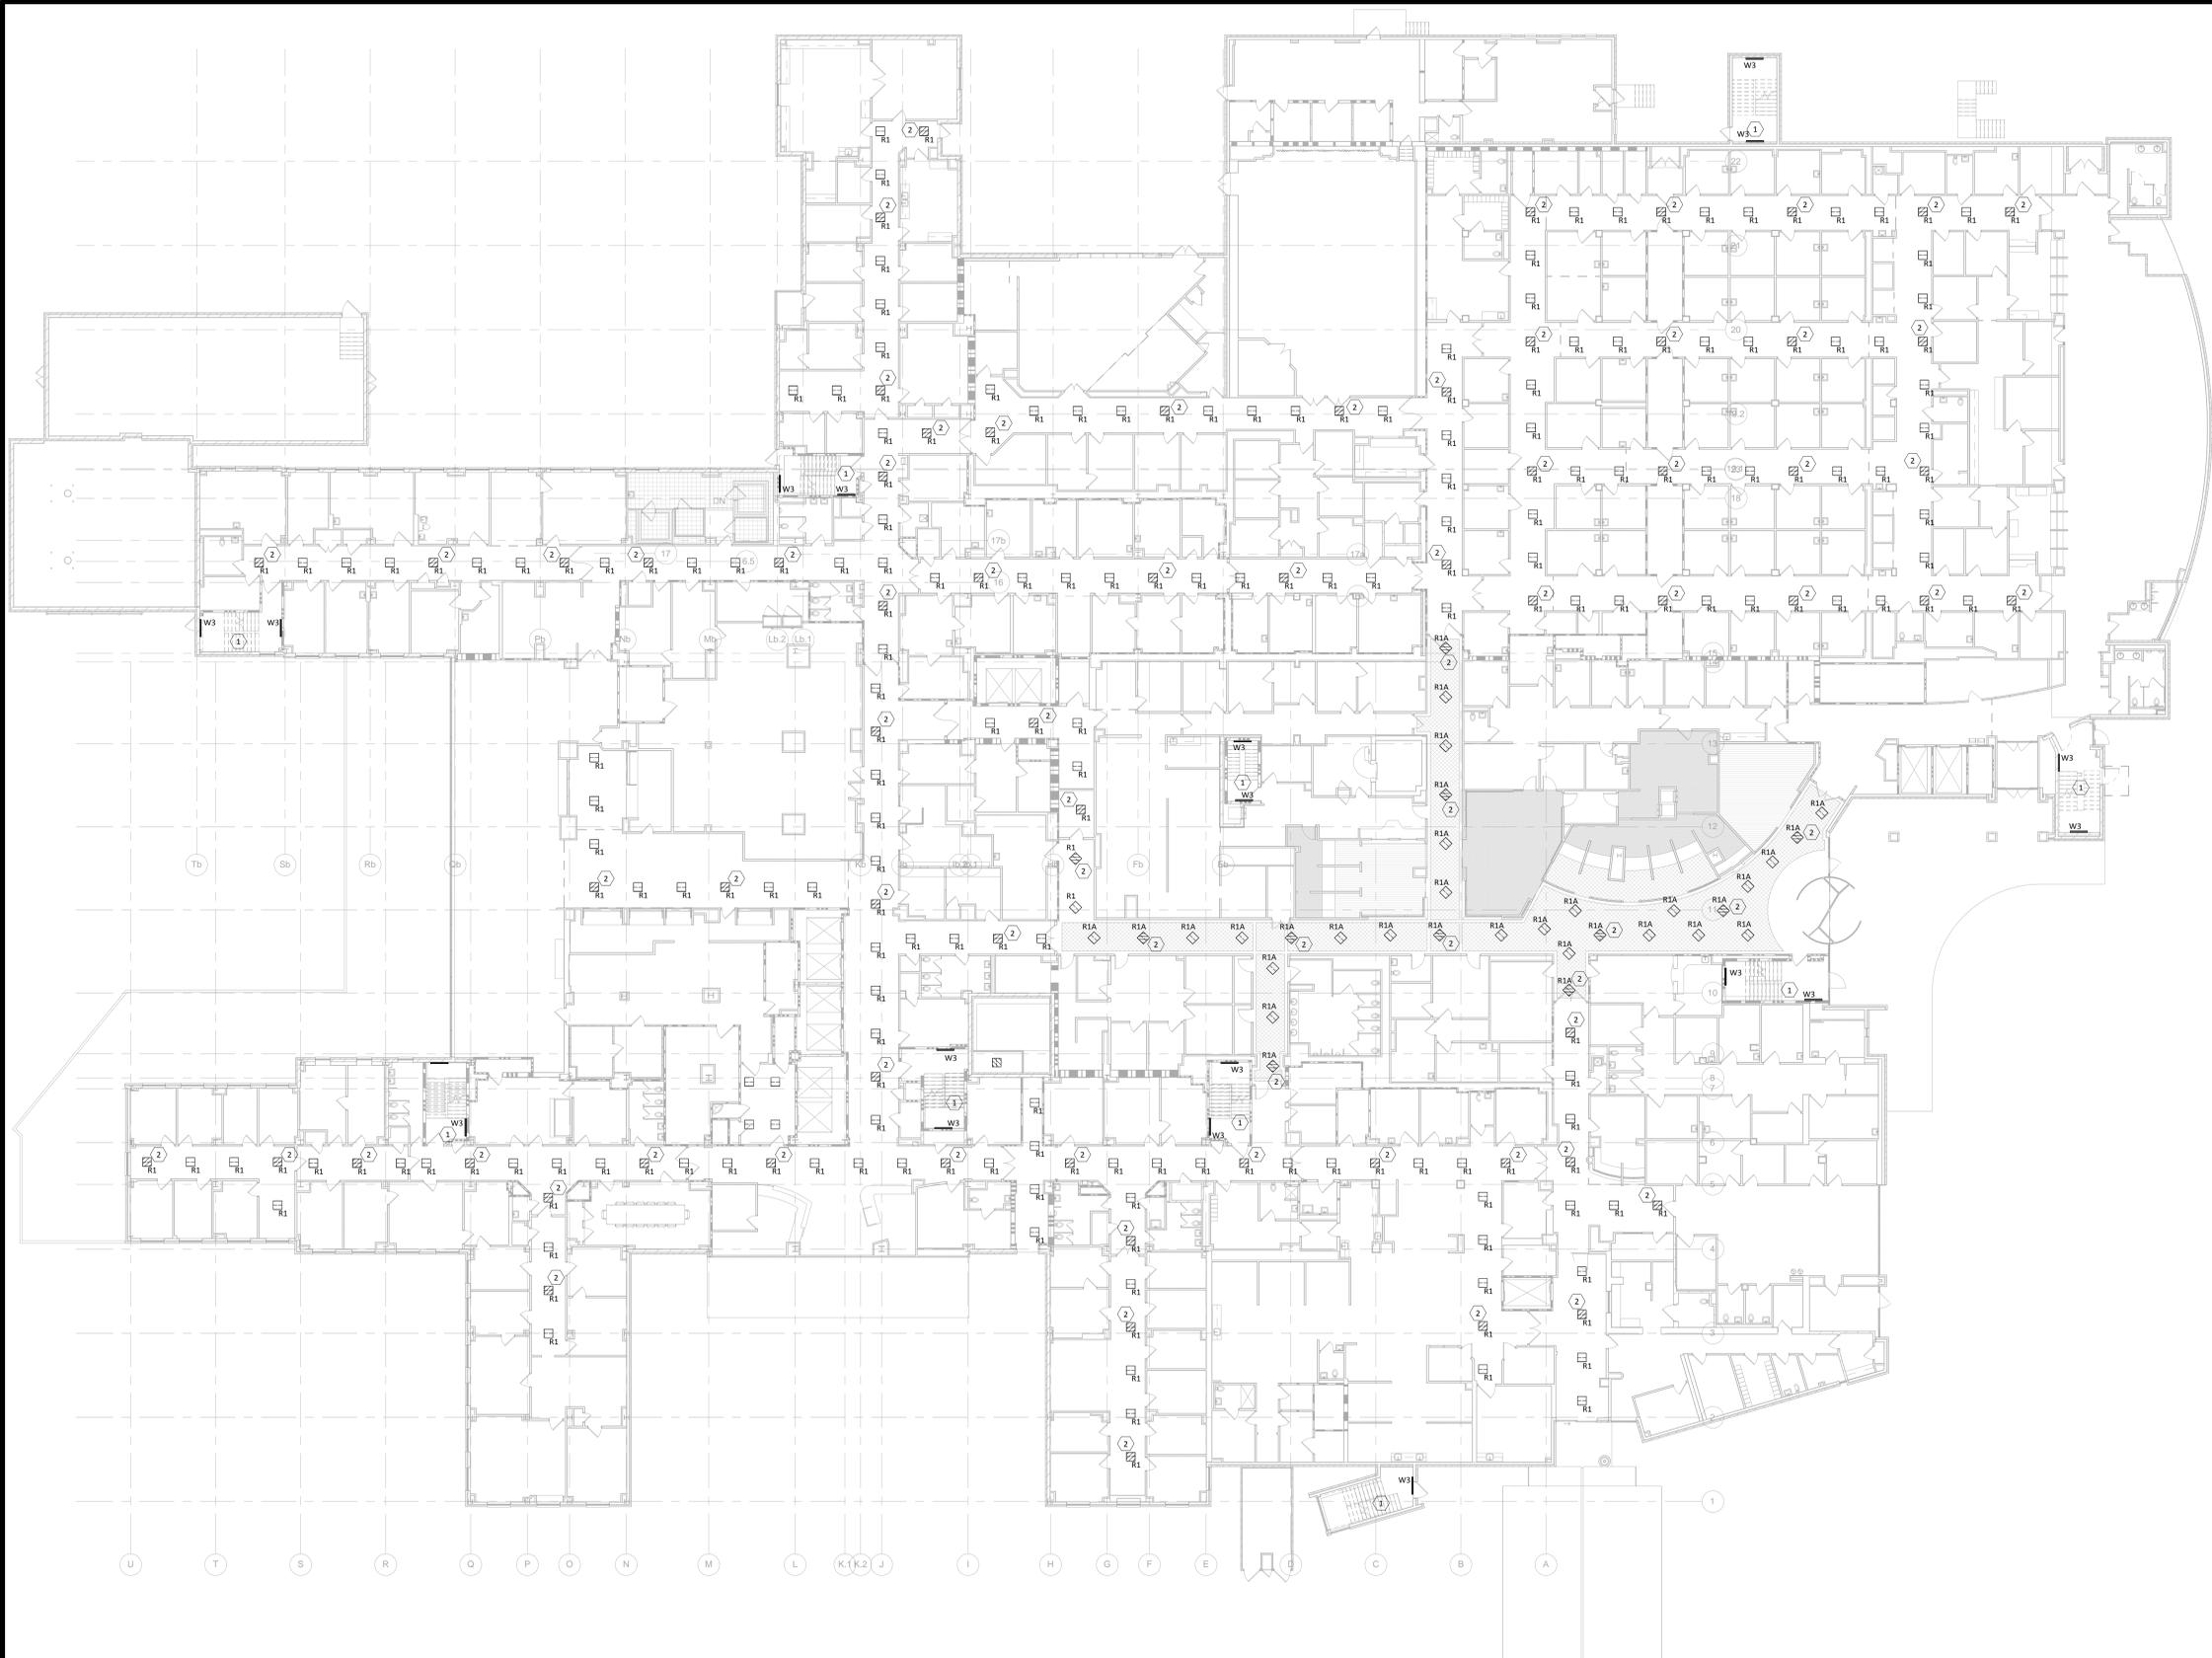

GENERAL NOTES

- A. UNLESS NOTED OTHERWISE, CONNECT ALL NEW LIGHTING FIXTURES TO EXISTING LIGHTING CIRCUIT SERVING AREA. EXTEND NEW CIRCUITING TO NEW FIXTURES.
- B. CONTRACTOR IS RESPONSIBLE FOR ALL PATCHING AND PAINTING OF MODIFIED SURFACES. THE PATCHING SHALL BE PAINTED TO MATCH EXISTING FINISHES.


PLAN NOTES

- 1. CONNECT NEW STAIRWELL LIGHTING TO EXISTING CIRCUIT SERVING STAIRWELL. EXTEND CIRCUITING TO NEW FIXTURES ON ALL STAIRWELL SURFACES WHERE PATCHING IS APPLIED. THE ENTIRE SURFACE SHALL BE PAINTED TO MATCH EXISTING CONDITIONS.
- 2. CONNECT EMERGENCY/NIGHT LIGHT FIXTURE TO CLOSET EMERGENCY LIGHTING CIRCUIT, SERVING AREA. EXTEND NEW CIRCUITING AS NECESSARY.

FIRST FLOOR LIGHTING PLAN
 SCALE: 1/16" = 1'-0"

95% REVIEW	08/08/14
85% REVIEW	08/21/14
100% REVIEW	10/08/14
BID DOCUMENTS	11/25/14
Revisions:	Date

CONSULTANTS:

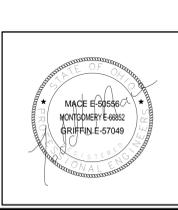


ARCHITECT/ENGINEERS:

Dynamix Engineering Ltd.
 Facility Engineering Consultants
 855 Grandview Avenue, 3rd Floor Columbus, OH 43215
 Phone: (614) 443-1178 Fax: (614) 443-1594
 Email: dynamix@dynamix-rltd.com
 DEL # 34004

Project Status	
Drawing Title FIRST FLOOR LIGHTING PLAN	Project Title INSTALL LED LIGHTING
Project Number 53-16-207	Building Number Bldg
Location CINCINNATI VA MEDICAL CENTER	Drawing Number E101
Date 11/25/2014	Checked By: Checker
Drawn By: Author	Office of Construction and Facilities Management Department of Veterans Affairs

one eighth inch = one foot
 one quarter inch = one foot
 three eighths inch = one foot
 one half inch = one foot
 three quarters inch = one foot
 one inch = one foot
 one and one half inches = one foot
 three inches = one foot

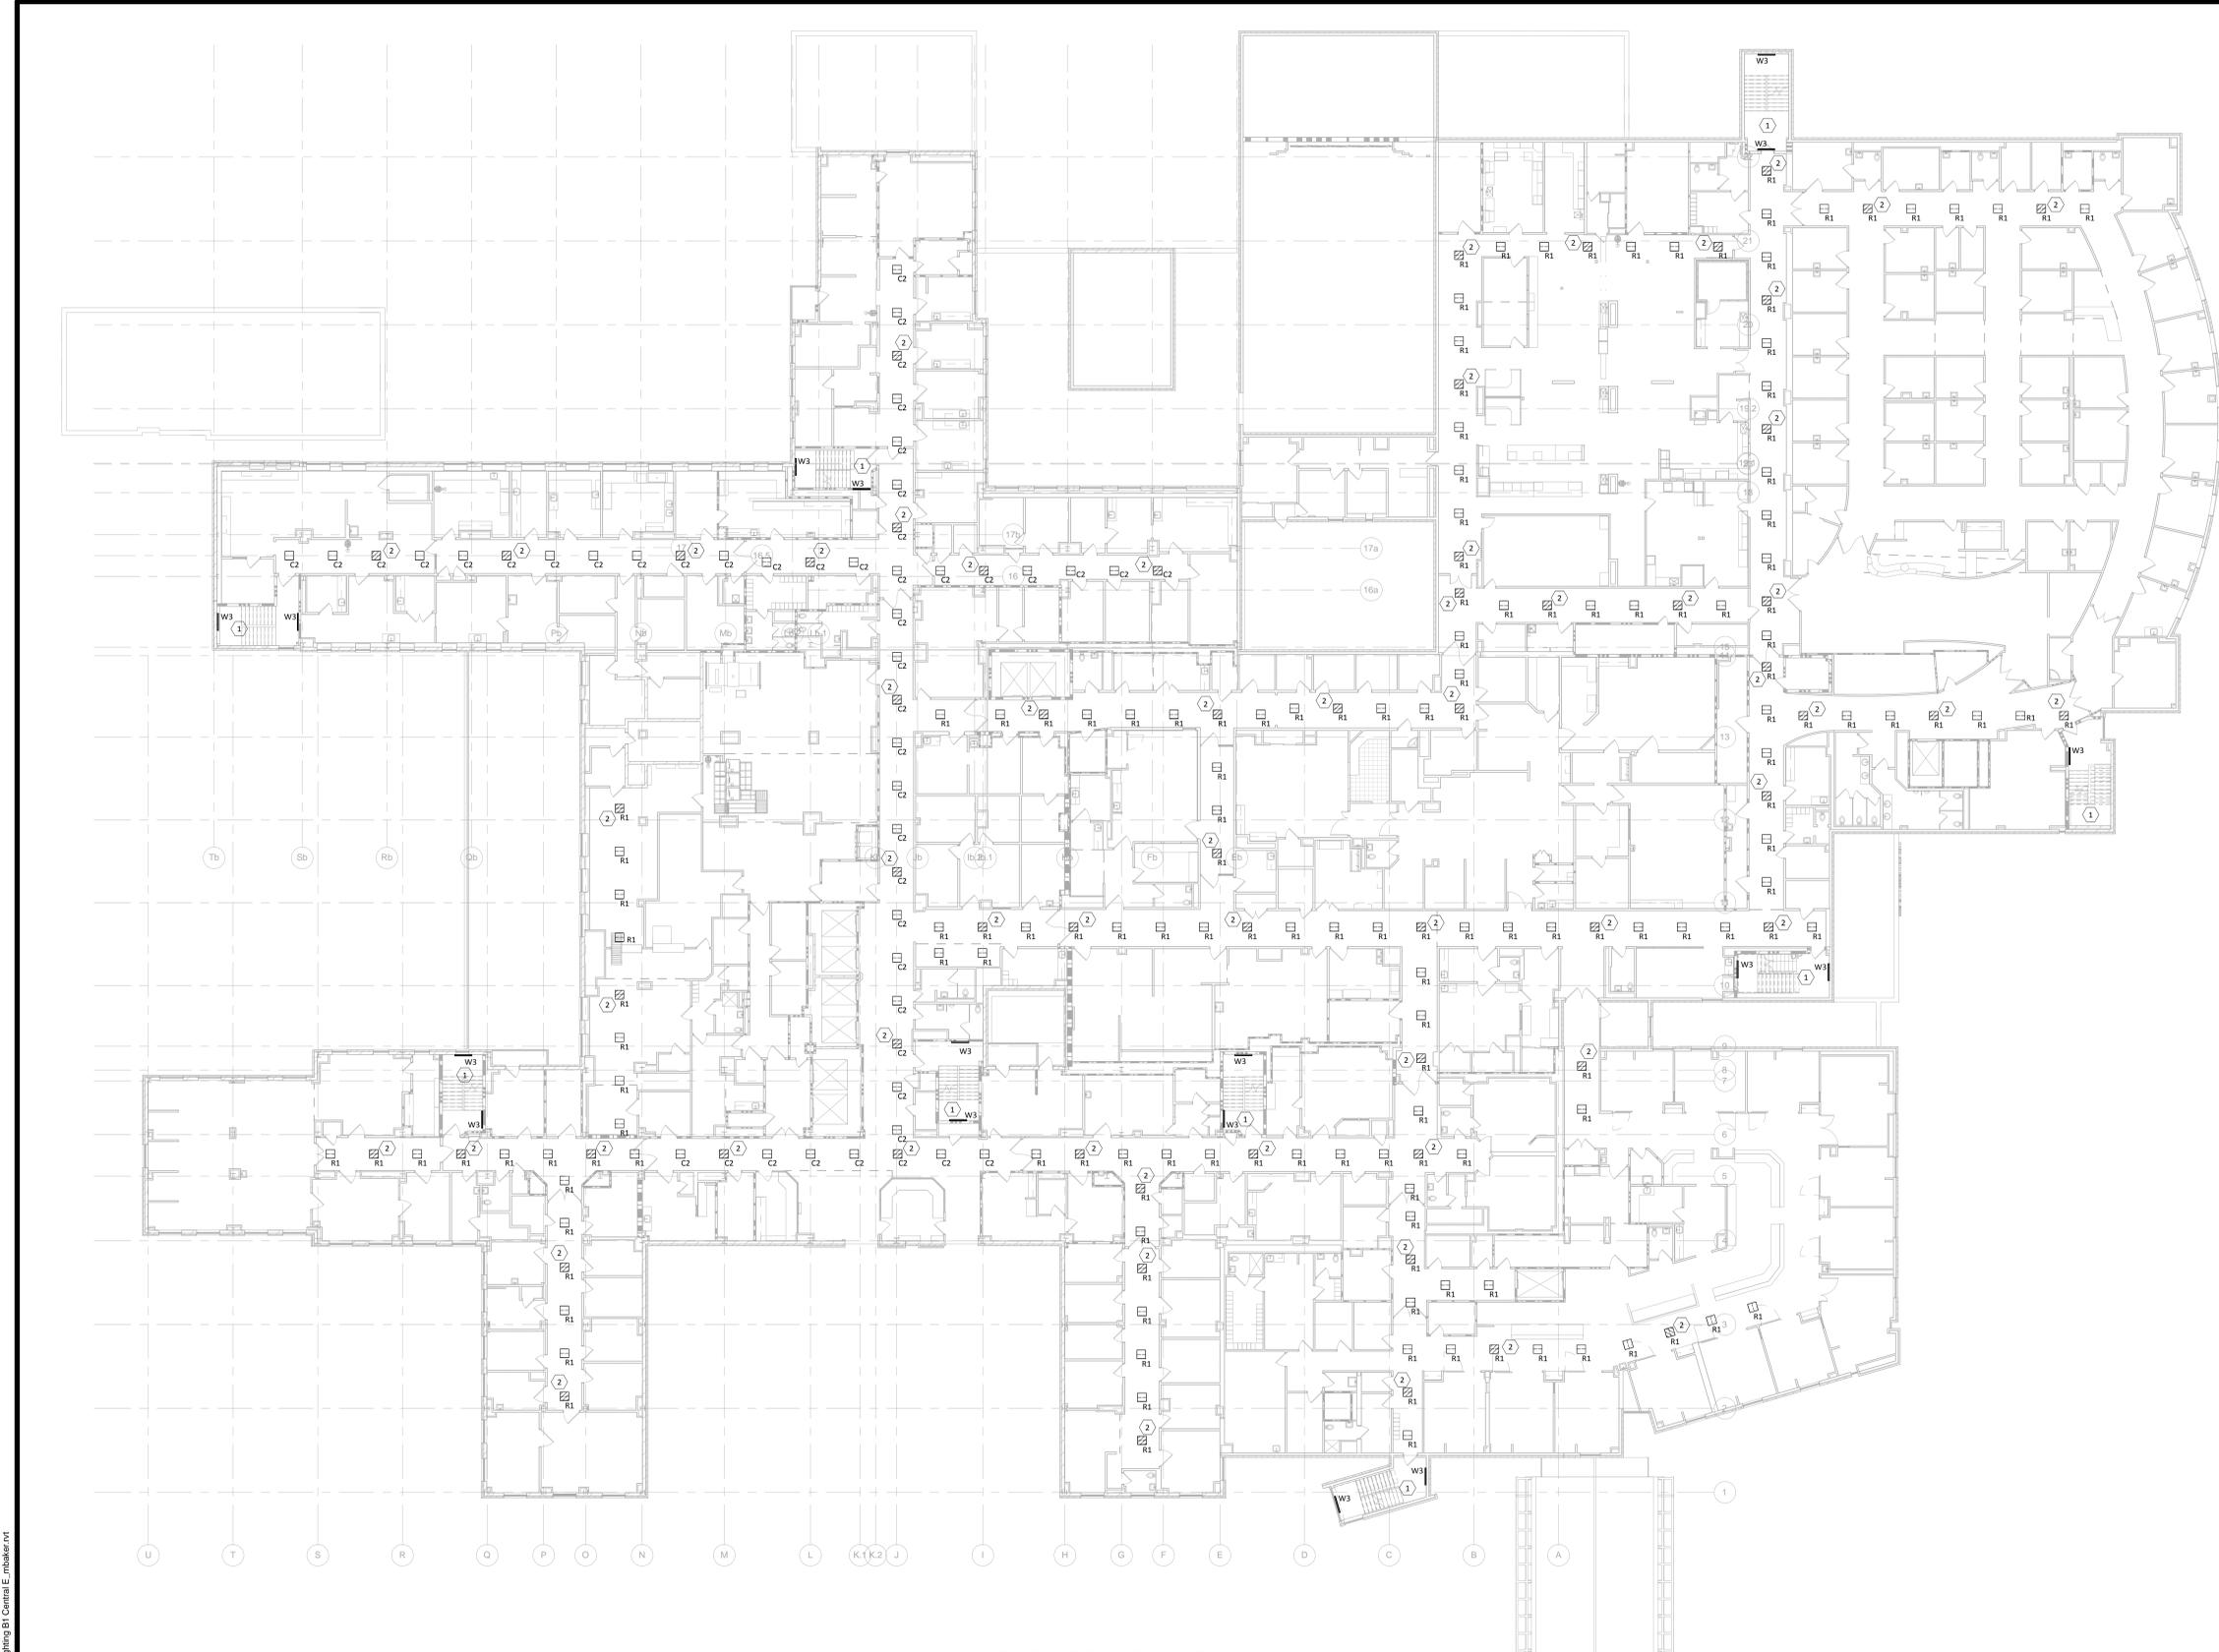

GENERAL NOTES

- A- UNLESS NOTED OTHERWISE, CONNECT ALL NEW LIGHTING FIXTURES TO EXISTING LIGHTING CIRCUIT SERVING AREA. EXTEND NEW CIRCUITING TO NEW FIXTURES.
- B- CONTRACTOR IS RESPONSIBLE FOR ALL PATCHING AND PAINTING OF MODIFIED SURFACES. THE PATCHING SHALL BE PAINTED TO MATCH EXISTING FINISHES.


PLAN NOTES

- 1- CONNECT NEW STAIRWELL LIGHTING TO EXISTING CIRCUIT SERVING STAIRWELL. EXTEND CIRCUITING TO NEW FIXTURES ON ALL STAIRWELL SURFACES WHERE PATCHING IS APPLIED, THE ENTIRE SURFACE SHALL BE PAINTED TO MATCH EXISTING CONDITIONS. THIS WORK IS PART OF DEDUCT ALTERNATE #1.
- 2- CONNECT EMERGENCY/NIGHT LIGHT FIXTURE TO CLOSET EMERGENCY LIGHTING CIRCUIT, SERVING AREA. EXTEND NEW CIRCUITING AS NECESSARY.

SECOND FLOOR LIGHTING PLAN
 SCALE: 1/16" = 1'-0"

95% REVIEW	08/08/14
85% REVIEW	08/21/14
100% REVIEW	10/08/14
BID DOCUMENTS	11/25/14
Revisions:	Date

CONSULTANTS:

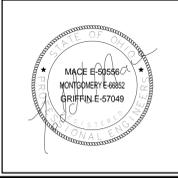

ARCHITECT/ENGINEERS:

Dynamix Engineering Ltd.
 Facility Engineering Consultants
 855 Grandview Avenue, 3rd Floor Columbus, OH 43215
 Phone: (614) 443-1178 Fax: (614) 443-1594
 Email: dynamix@dynamix-rltd.com
 DEL # 34004

Project Status	
Drawing Title SECOND FLOOR LIGHTING PLAN	Project Title INSTALL LED LIGHTING
Project Number 53-16-207	Building Number Bldg
Location CINCINNATI VA MEDICAL CENTER	Drawing Number E102
Date 11/25/2014	Checked By: Checker
Drawn By: Author	Office of Construction and Facilities Management Department of Veterans Affairs