


one eighth inch = one foot
 one quarter inch = one foot
 one half inch = one foot
 three eighths inch = one foot
 one inch = one foot
 one and one eighth inch = one foot
 one and one quarter inch = one foot
 one and one half inch = one foot
 one and three quarters inch = one foot
 two inches = one foot
 three inches = one foot
 four inches = one foot
 five inches = one foot
 six inches = one foot
 seven inches = one foot
 eight inches = one foot
 nine inches = one foot
 ten inches = one foot
 eleven inches = one foot
 twelve inches = one foot

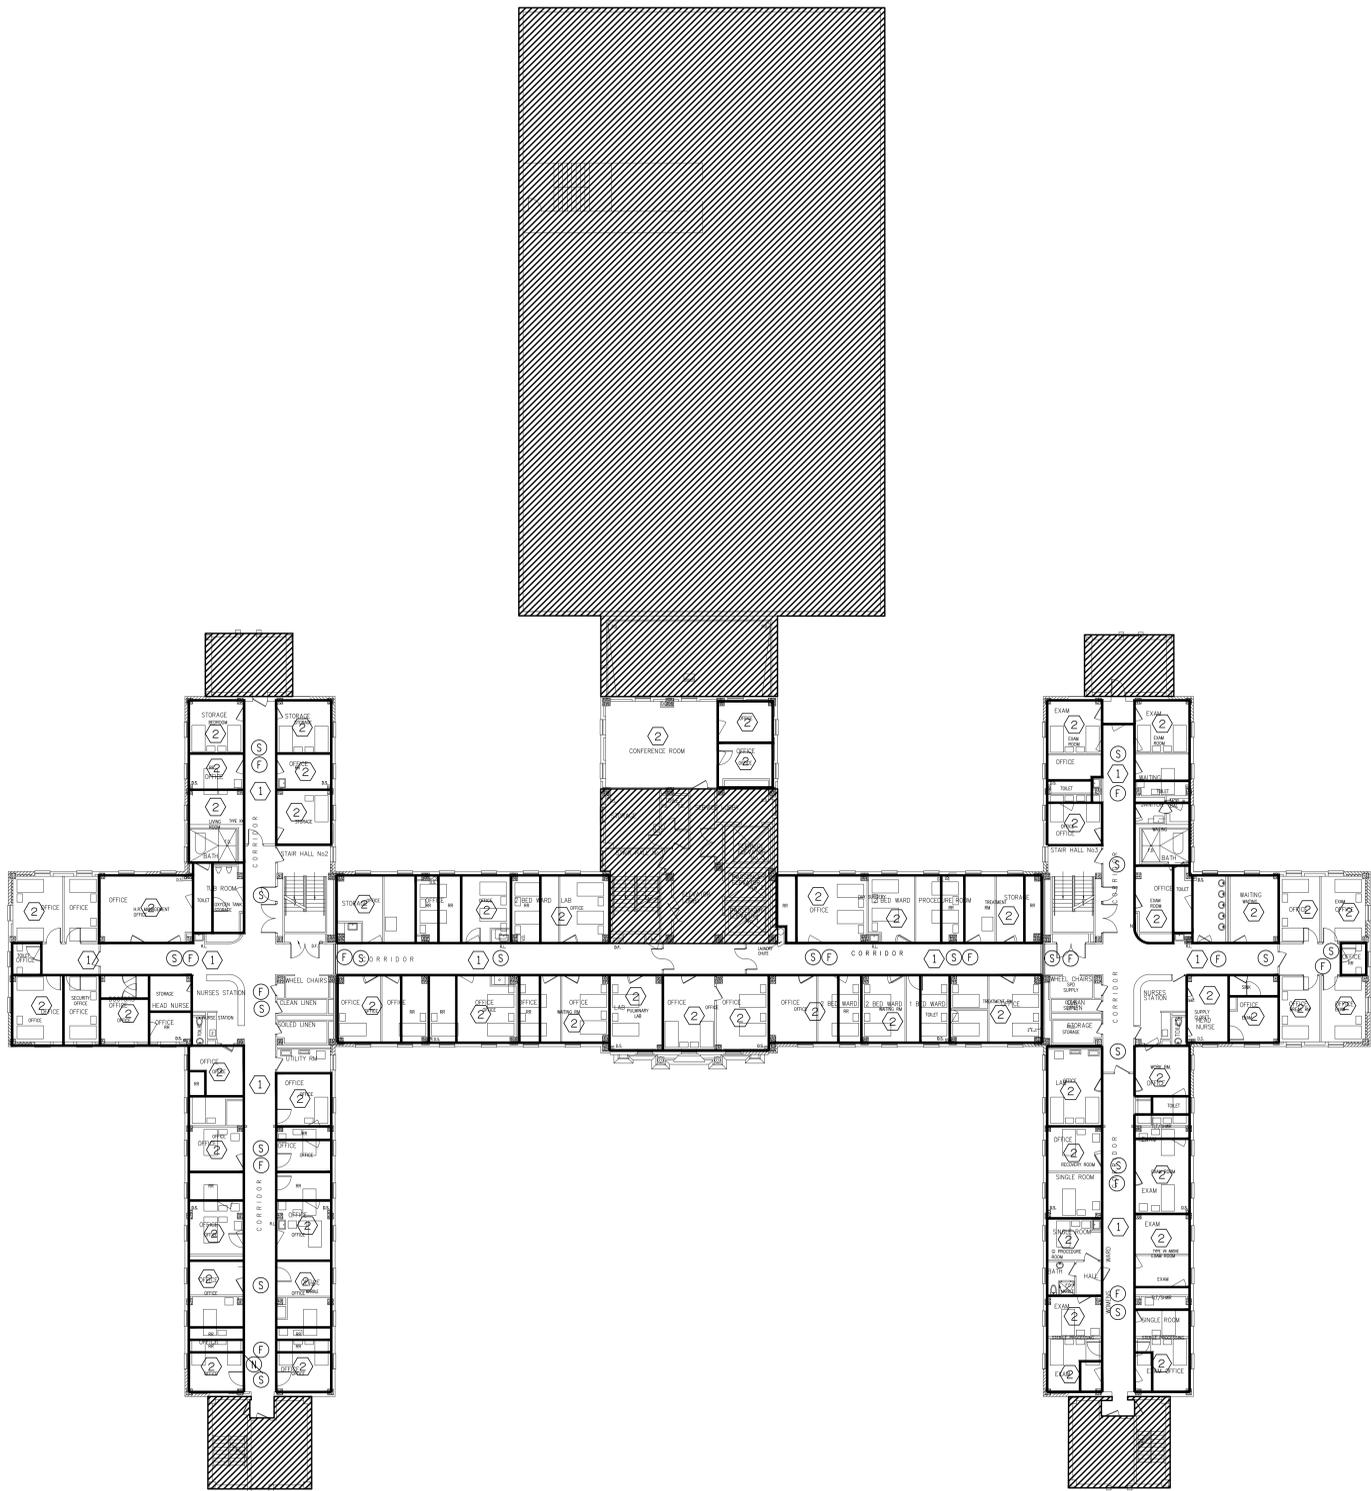


NOTICE: DEMOLITION
 CONTRACTOR SHALL REMOVE ALL EXISTING SPECIAL SYSTEMS DEVICES SHOWN ON DRAWINGS IN DEMOLITION (NON-SHADED) AREAS, UNLESS OTHERWISE NOTED. ALL WIRING CONNECTED TO DEVICES BEING REMOVED SHALL BE DISCONNECTED, CAPPED, AND LEFT IN SAFE CONDITION FOR LATER RECONNECTION TO RELOCATED DEVICES IN NEW CONSTRUCTION PHASE. ALL DEVICES SHALL BE STORED AND PROTECTED FROM DAMAGE UNTIL THEY HAVE BEEN REINSTALLED.

GENERAL NOTES: (THIS SHEET ONLY)
 1. ALL WORK WITH FIRE ALARM SYSTEM SHALL BE COORDINATED AND SCHEDULED WITH HOSPITAL PRIOR TO COMMENCING WORK.

KEYED NOTES: (THIS SHEET ONLY)
 ① REMOVE EXISTING SPECIAL SYSTEM DEVICES IN EXISTING CORRIDOR CEILING AND RELOCATE TO NEW CEILING.
 ② REMOVE AND RELOCATE EXISTING SPECIAL SYSTEM DEVICES IN CEILING IN THIS SPACE AS REQUIRED DURING THE REMOVAL AND REINSTALLATION OF HVAC DUCT BY OTHERS.

1 BLDG. 11 - 4TH FLR.
 SCALE: 1/16" = 1'-0"

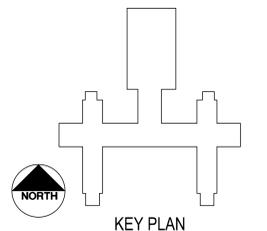

CONSULTANTS:  Goetting & Associates, Inc. 12710 Research Blvd, Suite 355 Austin, Texas 78759 512/416-1654 FAX: 512/416-7547		ARCHITECT/ENGINEERS:  RH SHACKELFORD, INC. SDVOSB		Approved: Assistant Director Approved: Service Chief Approved: Chief, Bio-Med Approved: Chief, IT Approved: Chief, Safety	Approved: Chief of Staff Approved: Service Chief Approved: Chief, EMS Approved: Chief, M&O Approved: Chief	Approved: Chief, Engineering Approved: Service Chief Approved: Chief, Infection Control Approved: Chief, Police Approved: Chief	Drawing Title ELECTRICAL DEMOLITION BUILDING 11 - FOURTH FLOOR AUXILIARY SYSTEMS PLAN Location Kerrville Veterans Hospital Veterans Affairs 2600 Memorial Blvd. Kerrville, TX 78028	Project Name KD AIR HANDLER REPLACEMENT (AHU) PROJECT - PHASE II	Project Number 671A4-09-119 Date 09/13/12 Drawing Number 11-ED110 Dwg. of	Building Number Checked RTO Drawn RTO	Office of Construction and Facilities Management 
--	--	--	--	---	--	---	--	---	--	---	--