



three inches = one foot  
 one and one half inches = one foot  
 one inch = one foot  
 three quarters inch = one foot  
 one half inch = one foot  
 one quarter inch = one foot  
 one eighth inch = one foot

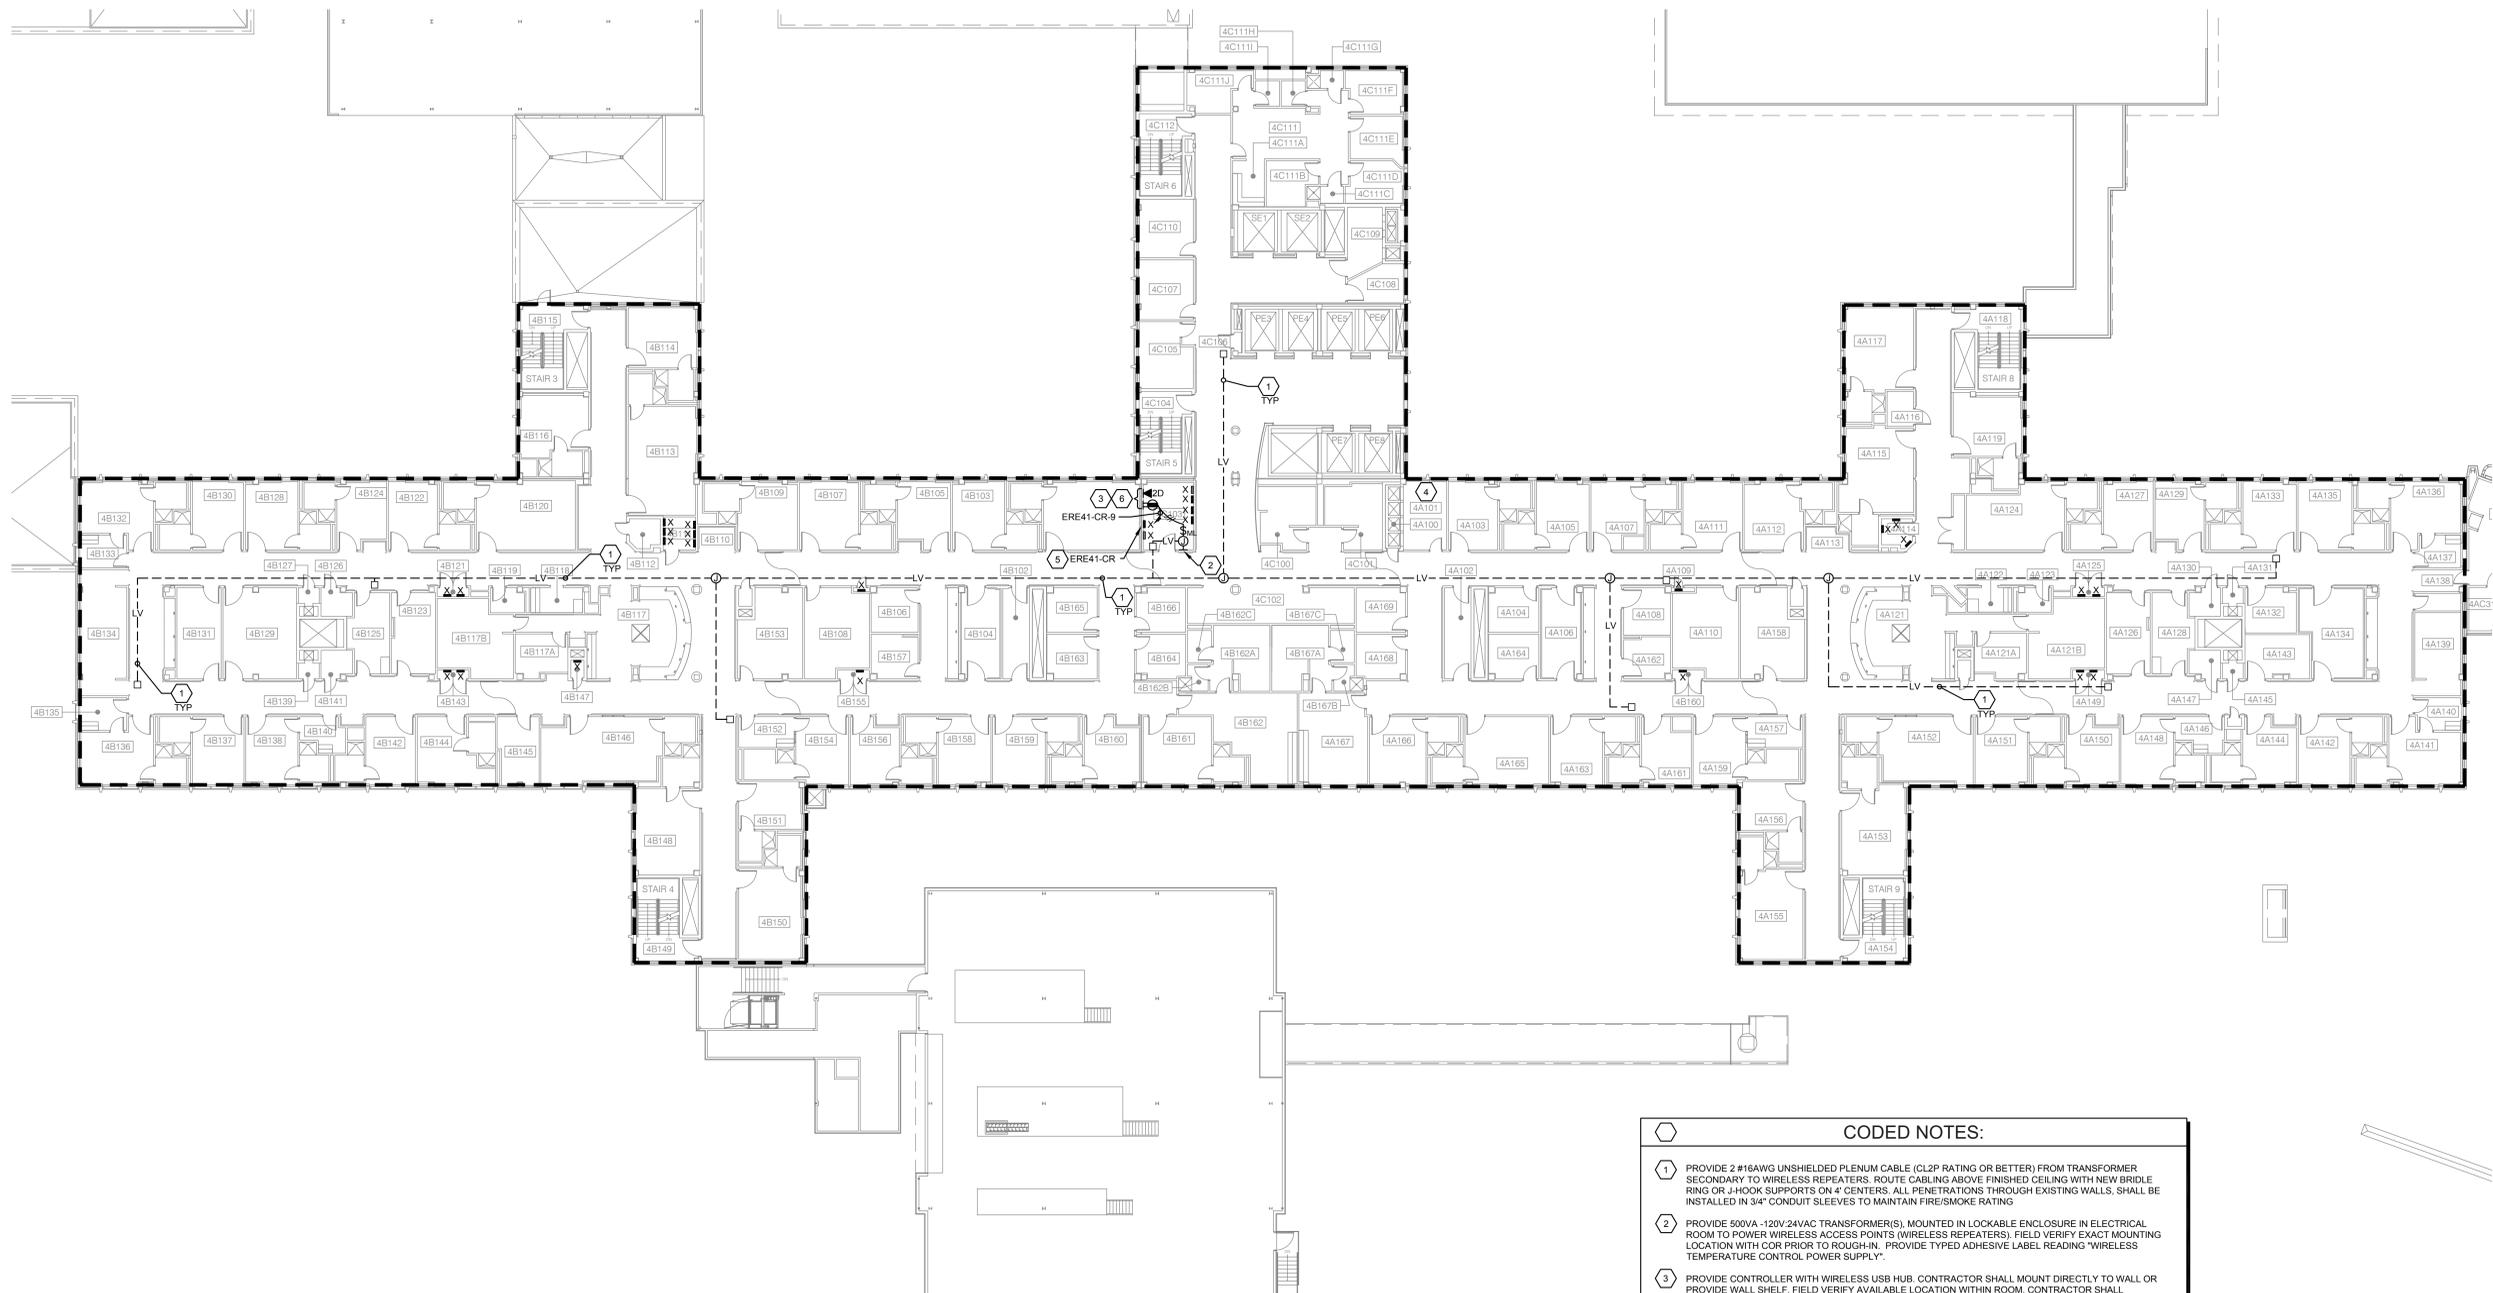

**FOURTH FLOOR ELECTRICAL PLAN**  
 SCALE: 1/16" = 1'-0"  
 0' 8' 16' 32' 64'

- CODED NOTES:**
- 1 PROVIDE 2 #16AWG UNSHIELDED PLENUM CABLE (CL2P RATING OR BETTER) FROM TRANSFORMER SECONDARY TO WIRELESS REPEATERS. ROUTE CABLING ABOVE FINISHED CEILING WITH NEW BRIDLE RING OR JHOOK SUPPORTS ON 4' CENTERS. ALL PENETRATIONS THROUGH EXISTING WALLS, SHALL BE INSTALLED IN 3/4" CONDUIT SLEEVES TO MAINTAIN FIRE/SMOKE RATING.
  - 2 PROVIDE 500VA - 120V/24VAC TRANSFORMER(S), MOUNTED IN LOCKABLE ENCLOSURE IN ELECTRICAL ROOM TO POWER WIRELESS ACCESS POINTS (WIRELESS REPEATERS). FIELD VERIFY EXACT MOUNTING LOCATION WITH COR PRIOR TO ROUGH-IN. PROVIDE TYPED ADHESIVE LABEL READING "WIRELESS TEMPERATURE CONTROL POWER SUPPLY".
  - 3 PROVIDE CONTROLLER WITH WIRELESS USB HUB. CONTRACTOR SHALL MOUNT DIRECTLY TO WALL OR PROVIDE WALL SHELF. FIELD VERIFY AVAILABLE LOCATION WITHIN ROOM. CONTRACTOR SHALL PROVIDE 120V-1P EMERGENCY CIRCUIT AND SURFACE MOUNTED DUPLEX RECEPTACLE MOUNTED ADJACENT TO CONTROLLER.
  - 4 LOCATION OF EXISTING ANDOVER NETWORK SWITCH INDICATED FOR REFERENCE.
  - 5 PROVIDE UPDATED PANEL LOAD SCHEDULES.
  - 6 PROVIDE 2-PORT SURFACE MOUNTED DATA OUTLET MOUNTED ADJACENT TO CONTROLLER. PROVIDE (2) CAT6 CABLES (1 SPARE) FROM EXISTING ANDOVER NETWORK SWITCH INDICATED ON DRAWINGS AND CONNECT COMPLETE. COORDINATE WORK WITH COR.

- GENERAL NOTES:**
- A. ACCESS TO ROOMS SHALL BE SCHEDULED WITH VA COR AND DEPARTMENT STAFF. SUBMIT PROPOSED SCHEDULE TO VA FOR REVIEW WITHIN 10 BUSINESS DAYS OF NOTICE TO PROCEED. AREAS CONSIDERED CRITICAL OR LIMITED AVAILABILITY SHALL BE COORDINATED WITH THE VA DURING THE DEVELOPMENT OF THE SCHEDULE.
  - B. FINAL QUANTITIES AND LOCATIONS OF WIRELESS REPEATERS SHALL BE DETERMINED BY THE CONTRACTOR AND VENDOR IN ORDER TO GUARANTEE A FULLY FUNCTIONAL SYSTEM.
  - C. CONTRACTOR TO DOCUMENT THE LOCATION OF ALL TRANSFORMERS ON AS-BUILT DRAWINGS.

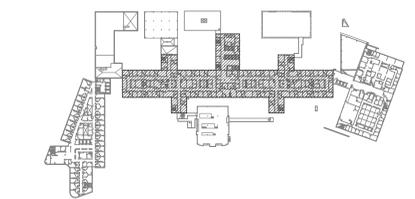

**FOURTH FLOOR KEY PLAN**  
 NOT TO SCALE


**FOR CONSTRUCTION**

**FULLY SPRINKLERED**

Revisions:	Date
1	
2	
3	
4	
5	
6	
7	
8	
9	
10	

**CONSULTANTS:**

Bid Issue	03-30-15

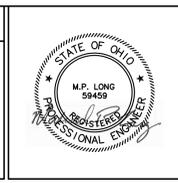

**ARCHITECT/ENGINEER:**

**FREDRICK, FREDRICK & HELLER ENGINEERS, INC.**  
 672 EAST ROYALTON ROAD  
 BROADVIEW HTS., OHIO 44147  
 TEL: (440) 546-9888  
 FAX: (440) 546-9899

**FOURTH FLOOR ELECTRICAL PLAN**

Approved: Project Director

Project Title <b>CONVERT PNEUMATIC VAV BOXES TO DDC CONTROL</b>			Project Number 541-15-202
Location <b>VAMC - WADE PARK</b>			Building Number 1
Date 03-30-15	Checked LDH	Drawn TWM	Drawing Number <b>1-E5</b>
Dwg. of			

**Office of Facilities Management**

Department of Veterans Affairs