


(FOR AS BUILT SEE APPROVED SQUARE "D" SUBMITTALS)

**2** E6.2.1 ESSENTIAL DISTRIBUTION SWITCHGEAR "EHD1002A"


SCALE: 1/2"=1'-0"

GENERAL SHEET NOTES

- EACH EMERGENCY CIRCUIT FEED SHALL BE FIRE TAPE IN TROUGH.
- THE ENLARGED ROOM PLAN SHOW EQUIPMENT LAYOUT ONLY.
- REFER TO LIGHTING FLOOR PLANS FOR LIGHTING IN THESE CLOSETS.
- REFER TO POWER FLOOR PLANS FOR RECEPTACLES.
- REFER TO SIGNAL FLOOR PLANS FOR SIGNAL DEVICES.
- THE UNDER FLOOR BEAMS ARE SHOWN AS DASHED LINE.
- CONTRACTOR MAY USE THESE DRAWINGS IN THE PREPARATION OF THE REQUIRED ROOM LAYOUT DRAWINGS.

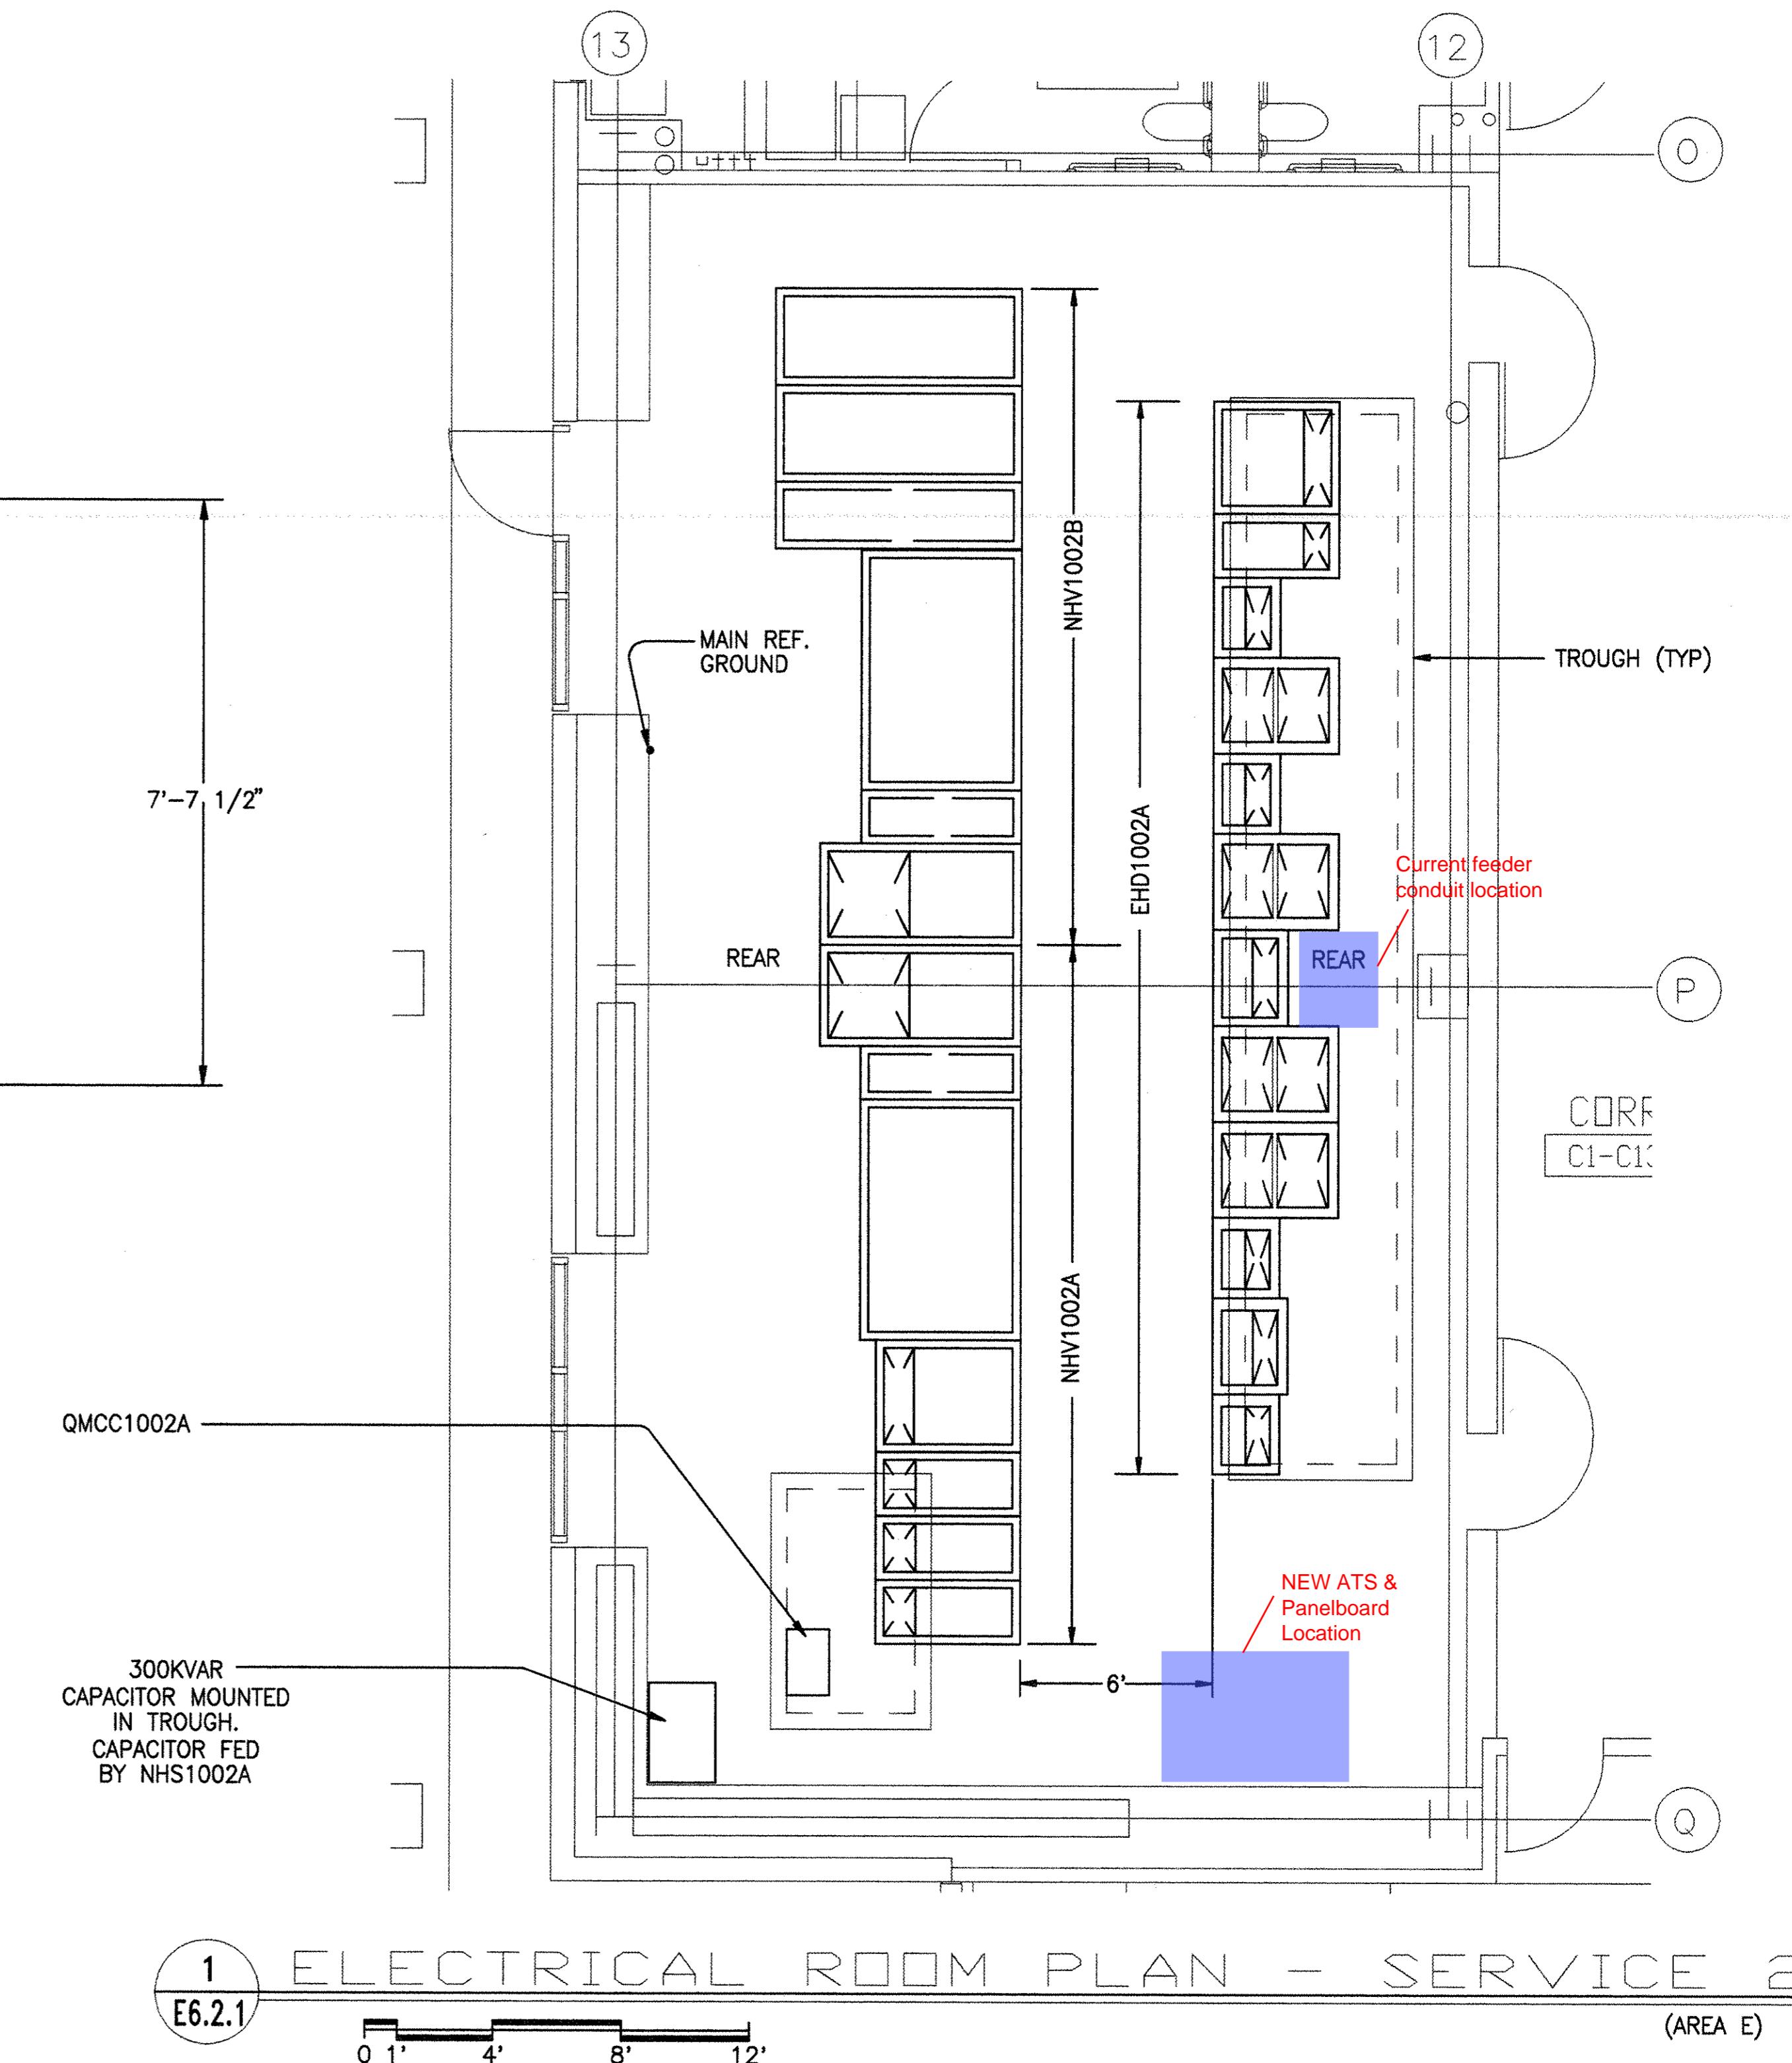

**1** E6.2.1 ELECTRICAL ROOM PLAN - SERVICE 2 (AREA E)

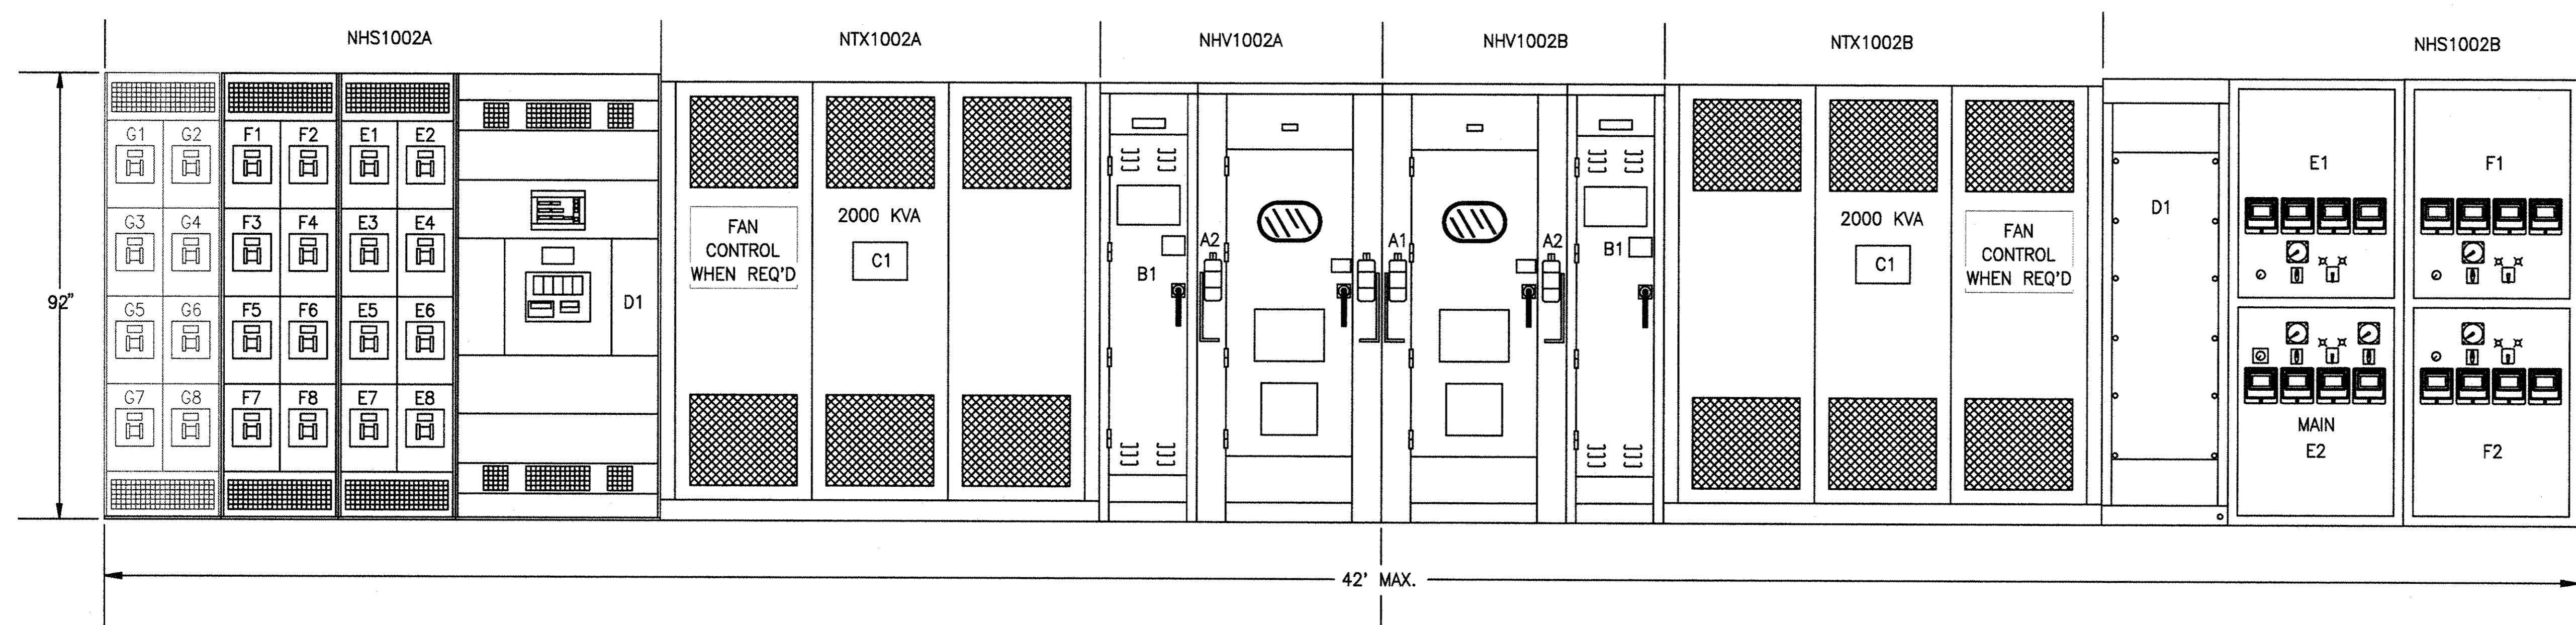

(FOR AS BUILT SEE APPROVED SQUARE "D" SUBMITTALS)

**3** E6.2.1 UNIT SUBSTATION "NHV1002A"

SCALE: 1/2"=1'-0"

(FOR AS BUILT SEE APPROVED SQUARE "D" SUBMITTALS)

**4** E6.2.1 UNIT SUBSTATION "NHV1002B"

SCALE: 1/2"=1'-0"

**AS BUILT**

DATE: 2-05-97

BLDG-100

DRAWING NO.	DATE	REVISION	DATE	DESCRIPTION
REI-E6.2.1	NO. 557	△	△	AS BUILT DATE: 2-05-97

**ENLARGED ELECT. ROOM PLAN  
SERVICE 2 FIRST FLOOR**

ROSENDIN ELECTRIC, INC.  
DESIGN AND CONSTRUCT CONTRACTORS  
440 9TH STREET, SAN FRANCISCO, CA 94103  
880 N. MABRY RD., SAN JOSE, CA 95133  
(415) 575-1600  
(408) 288-2600

