## VA NORTHERN INDIANA HEALTH CARE SYSTEM, FORT WAYNE


## SPS BASEMENT ADDITION VA PROJECT # 610A4-12-400



## VA NORTHERN INDIANA HEALTH CARE SYSTEM

FORT WAYNE 2121 Lake Ave. Fort Wayne, IN 46805

ASBESTOS CONTAINING MATERIAL (ACM) AND LEAD BASED PAINT (LBP) STATEMENT (Place an "X" in the appropriate box.)	
This facility contains no known or suspected asbestos or LBP.	
This facility contains asbestos and/or LBP that will be removed by the Air Force.	
This facility contains asbestos and/or LBP that will be removed under this contract.	X
This facility contains asbestos and/or LBP that will be removed under a seperate contract.	

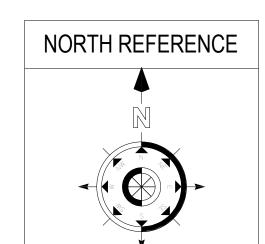


## **INDEX OF DRAWINGS**

SHEET NUMBER	SHEET NAME						
GENERAL							
GI-001	COVER SHEET						
GI-002	SYMBOLS/LEGEND/ARCHITECTURAL ABBREVIATIONS						
GI-003	CONSTRUCTION SIGN  LIFE SAFETY PLANS						
LS-001	LIFE SAFETY PLANS						
LS-002	FIRE RATINGS						
SITE							
CI-002	CIVIL GENERAL NOTES						
CI-003	CONSTRUCTION STAGING PLAN EXISTING TOPOGRAPHY						
VF-101	EXISTING TOPOGRAPHY						
CD-101	SITE DEMOLITION PLAN						
CD-102	UTILITY DEMOLITION PLAN						
CS-101	SITE PLAN						
CS-102	ALTERNATE SITE PLAN						
CG-101	GRADING PLAN						
CU-101	UTILITY PLAN						
CU-102	SANITARY SEWER PLAN & PROFILE						
CE-101	EROSION CONTROL PLAN						
CE-501	STORMWATER POLLUTION PREVENTION PLAN						
CE-502	EROSION CONTROL DETAILS						
CE-503	EROSION CONTROL DETAILS						
CS-501	SITE DETAILS						
CS-502	SITE DETAILS						
CS-503	SITE DETAILS						
STRUCTURAL							
SS-001	STRUCTURAL ABBREVIATIONS AND SYMBOLS						
SS-002	STRUCTURAL GENERAL NOTES						
SS-003	LOAD MAPS						
SS-004	STRUCTURAL SPECIAL INSPECTION REQUIREMENTS						
SS-101	FOUNDATION / BASEMENT PLAN						
SS-201	FIRST FLOOR FRAMING PLAN						
SS-202	STAIR TOWER ROOF FRAMING PLAN						
SS-240	BASEMENT MASONRY WALL AND LINTEL PLAN						
SS-250	ENLARGED PLANS						
SS-301	FOUNDATION TYPICAL SECTIONS AND DETAILS						
SS-302	FOUNDATION SCHEDULES, SECTIONS AND DETAILS						
SS-303	FOUNDATION SECTIONS AND DETAILS						
SS-304	FOUNDATION SECTIONS AND DETAILS						
SS-310	CONCRETE COLUMN SCHEDULE AND DETAILS						
SS-315	CONCRETE WALL SECTIONS AND DETAILS						
SS-316	CONCRETE WALL ELEVATIONS						
SS-317	CONCRETE WALL ELEVATIONS						
SS-320	CONCRETE FRAMING TYPICAL DETAILS						

SHEET NUMBER	SHEET NAME					
SS-321	CONCRETE FRAMING DETAILS					
SS-325	CONCRETE BEAM SCHEDULE					
SS-326	CONCRETE JOIST SCHEDULE					
SS-401	MASONRY TYPICAL DETAILS AND SCHEDULES					
SS-501	SLAB AND DECK SCHEDULES					
SS-502	STEEL FRAMING SECTIONS AND DETAILS					
SS-601	ALTERNATE DEDUCT #03 - STRUCTURAL PLANS					
SS-602	ALTERNATE DEDUCT #03 - CONCRETE WALL ELEVATION					
ARCHITECTURE						
AD-101	DEMOLITION PLANS					
AD-102	DEMOLITION DIAGRAMS					
AS-001	WALL TYPES					
AS-002	DEDUCT & PHASING					
AS-003	FUTURE CONSTRUCTION PHASE					
AS-100	FLOOR PLAN -LOWER LEVEL					
AS-102	ENLARGED PLANS					
AS-103	ACCESS FLOOR SYSTEM					
AS-131	OVERALL EQUIPMENT PLAN - LOWER LEVEL					
AS-132	EQUIPMENT PLAN - AREA 'A'					
AS-133	EQUIPMENT PLAN - AREA 'B'					
AS-202	EXTERIOR ELEVATIONS					
AS-301	BUILDING SECTIONS					
AS-312	WALL SECTIONS					
AS-412	INTERIOR ELEVATIONS					
AS-413	INTERIOR ELEVATIONS - RESTROOMS					
AS-414	INTERIOR ELEVATIONS - RESTROOMS & KITCHEN					
AS-421	STAIR PLANS & SECTIONS					
AS-501	SECTION DETAILS					
AS-503	PLAN DETAILS					
AS-601	DOORS SCHEDULES AND DETAILS					
AS-602	WINDOWS AND STOREFRONTS					
AS-701	FINISH PLAN					
AS-702	SIGNAGE PLAN					
AS-703	SIGN DETAILS					
AS-801	ALTERNATE DEDUCT #01					
AS-811	ALTERNATE DEDUCT #03					
AS-812	ALTERNATE DEDUCT #03-ELEVATIONS					
AS-813	ALTERNATE DEDUCT #03-SECTIONS					
PLUMBING	<u></u>					
PP-000	PLUMBING SYMBOLS & ABBREVIATIONS					
PD-100	PLUMBING FOUNDATION DEMOLITION PLAN					
PP-100	PLUMBING FOUNDATION NEW WORK PLAN					
PP-101	PLUMBING BASEMENT NEW WORK PLAN					

PP-102	PLUMBING FIRST FLOOR NEW WORK PLAN						
PP-301	PLUMBING RISER DIAGRAMS						
PP-401	PLUMBING DETAILS						
PP-501	PLUMBING SCHEDULES						
FIRE	'						
FA-000	SYMBOLS AND ABBREVIATIONS						
FD-101	BASEMENT DEMOLITION PLAN						
FA-101	BASEMENT NEW WORK PLAN						
FA-102	FIRST FLOOR NEW WORK PLAN						
	·						
MECHANICAL							
M-000	SYMBOLS, ABBREVIATIONS & GENERAL NOTES						
MD-101	BASEMENT LEVEL DEMOLITION PLAN						
MH-101	BASEMENT LEVEL DUCTWORK PLAN - NEW WORK						
MH-102	ROOF PLAN & ENLARGED MECH. ROOM- NEW WORK						
MH-301	MECHANICAL SECTIONS						
MH-511	MECHANICAL DUCTWORK DETAILS						
MP-101	BASEMENT LEVEL PIPING PLAN - NEW WORK						
MP-311	FLOW DIAGRAMS						
MP-312	FLOW DIAGRAMS						
MP-511	MECHANICAL PIPING DETAILS						
MP-512	MECHANICAL PIPING DETAILS						
MH-611	MECHANICAL SCHEDULES						
MH-612	MECHANICAL SCHEDULES						
MH-801	MECHANICAL DEDUCT ALTERNATE #03						
MI-711	MECHANICAL CONTROLS						
MI-712	MECHANICAL CONTROLS						
ELECTRICAL	·						
E000	LEGEND AND ABBREVIATIONS						
ED002	ELECTRICAL SITE PLAN - DEMOLITION						
ED100	BASEMENT LEVEL PLAN - ELECTRICAL DEMOLITION						
E002	ELECTRICAL SITE PLAN						
EL100	BASEMENT FLOOR PLAN - LIGHTING						
EL101	FIRST FLOOR PLAN - LIGHTING						
EP100	BASEMENT FLOOR PLAN - POWER						
ES100	BASEMENT FLOOR PLAN - SYSTEMS						
E200	ROOF PLAN - ELECTRICAL						
E301	ELECTRICAL DETAILS						
E401	ELECTRICAL SCHEMATICS						
E402	ELECTRICAL SCHEMATICS						
E500	ELECTRICAL ONE-LINE DIAGRAM						
E501	ELECTRICAL DIAGRAMS						
E600	ELECTRICAL SCHEDULES						
E601	ELECTRICAL SCHEDULES						
E501 E600	ELECTRICAL DIAGRAMS ELECTRICAL SCHEDULES						

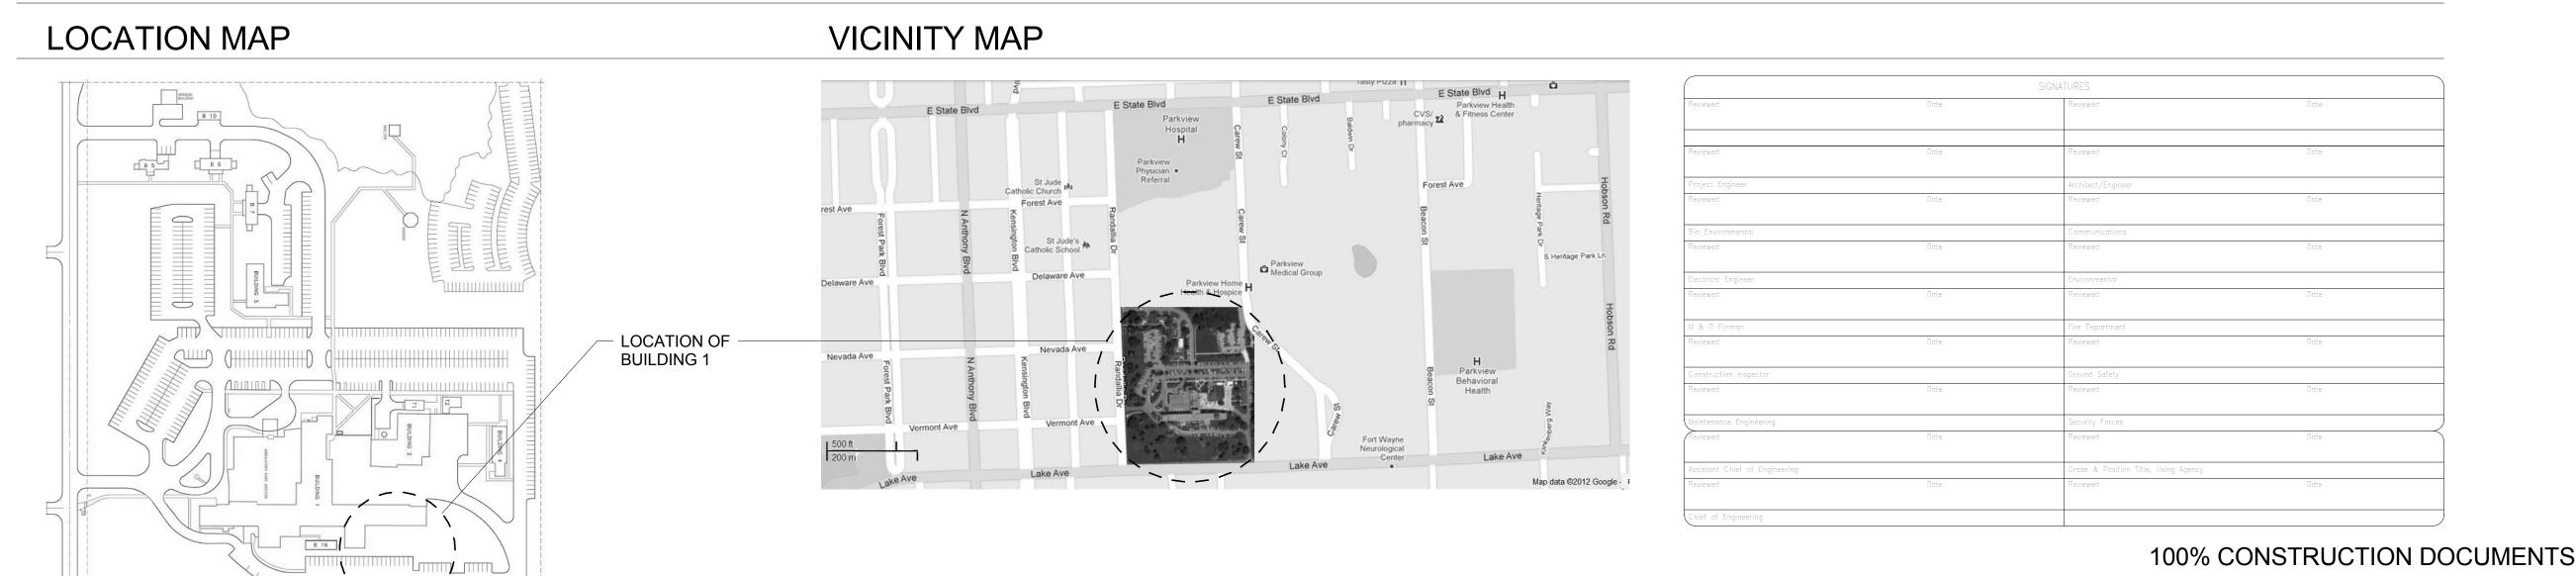

00% CONSTRUCTION DOCUMENTS FULLY SPRINKLERED

0629_VA_F			ARCHITECT/ENGINEERS:		CONSULTANTS:	MINIMAN PARILLE	Drawing Title COVER SHEET	Project Title SPS BASEMENT ADDITION	Project Number 2010.00629.0005	Office of
ijes\2012_00		VA NORTHERN INDIANA HEALTH CARE SYSTEM,	AMERICAN	Ross Baruzzini		AR11000109		VA PROJECT # 610A4-12-400	Building Number 01	Construction and Facilities
SI Local Cop		HEALTH CARE SYSTEM, FORT WAYNE 2121 Lake Ave. Fort Wayne,	STRUCTUREPOINT  1 NC.  7260 SHADELAND STATION INDIANAPOLIS, IN 46256-3957			STATE OF STA	Approved: Project Director	Location 2121 Lake Ave. Fort Wayne, IN 46805	Drawing Number GI-001	Management
Revisions:	Date	IN 46805	INDIANAPOLIS, IN 46256-3957 TEL 317.547.5580 FAX 317.543.0270 www.structurepoint.com	8250 Haverstick Road Suite 285 Indianapolis, IN 46240 317.638.8383		2/15/20/4		Date Checked Drawn 08/15/2014 JDF/ FMF APN		VA Department of Veterans Affairs