




# Department Of Veterans Affairs

## FORT MCPHERSON NATIONAL CEMETERY MAXWELL, NEBRASKA


### NEW IRRIGATION PUMP BUILDING PROJECT NUMBER 890-15-201

#### SHEET INDEX:

- X - 1 TITLE SHEET
- L - 1 OVERALL SITE PLAN & PLAN VIEW OF EXISTING CONDITIONS
- L - 2 PLAN, ELEVATION, AND SECTION VIEWS

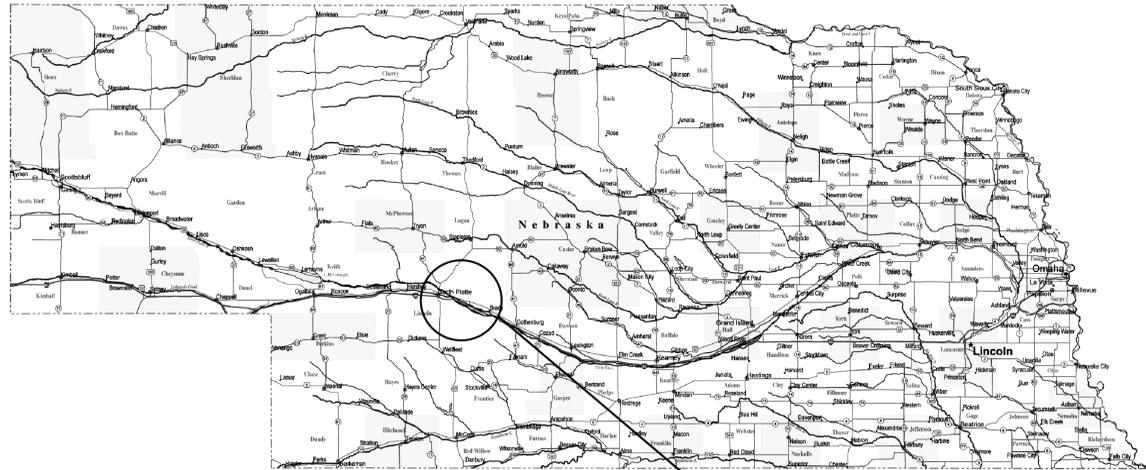

Maxwell, NE

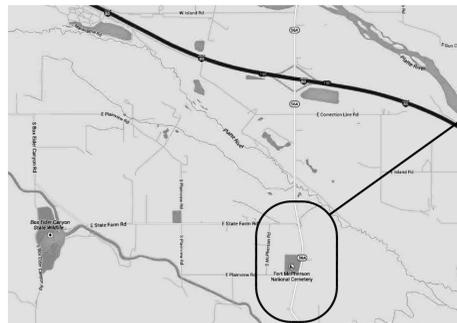

Fort McPherson  
National Cemetery

#### LOCATION MAPS


### NOT FOR CONSTRUCTION

Revisions	Date




NATIONAL  
CEMETERY  
ADMINISTRATION


Drawing Title <b>COVER SHEET &amp; SHEET INDEX</b>	Project Title <b>NEW IRRIGATION PUMP BUILDING</b>			Date <b>04/15/2015</b>
	Approved: Division Chief	Building Number ----	Checked .	Drawn <b>RLD</b>
Approved: Service Director	Location <b>FORT MCPHERSON NATIONAL CEMETERY</b>			DRAWING NO. <b>X-1</b> Dwg. 1 Of 3

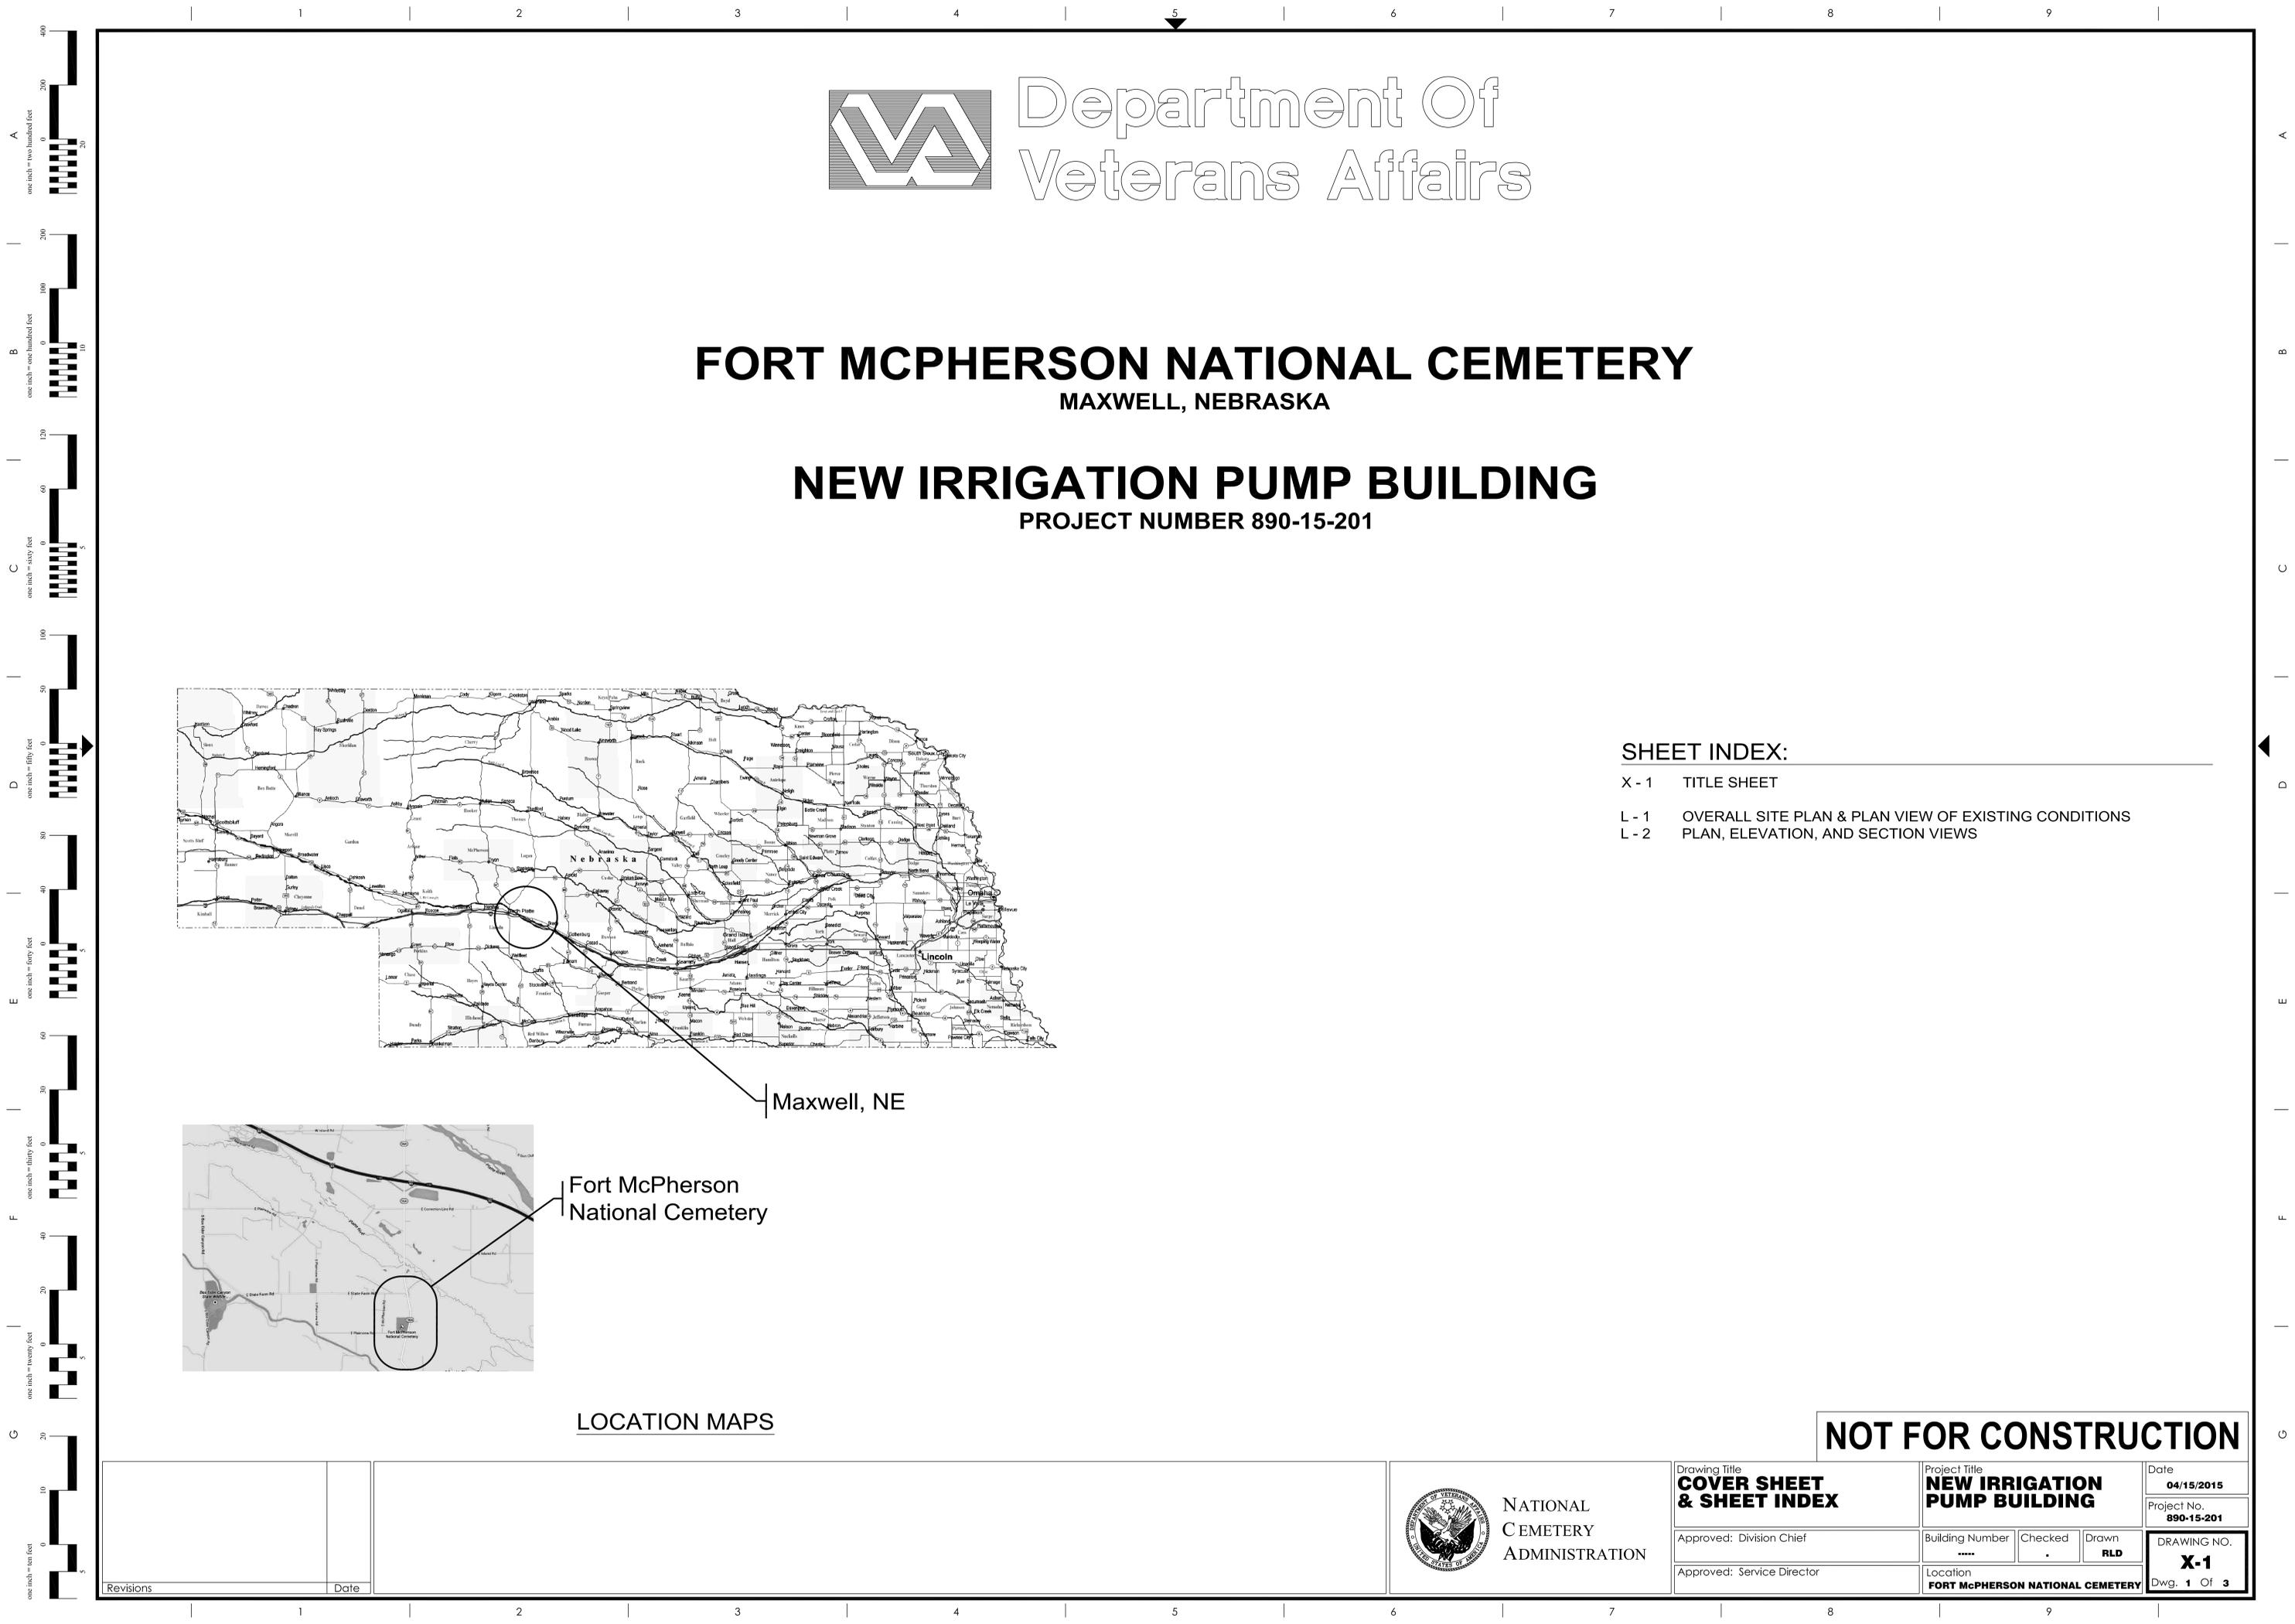

A  
 one inch = two hundred feet  
 0 200 400  
 B  
 one inch = one hundred feet  
 0 100 200  
 C  
 one inch = sixty feet  
 0 60 120  
 D  
 one inch = fifty feet  
 0 50 100  
 E  
 one inch = forty feet  
 0 40 80  
 F  
 one inch = thirty feet  
 0 30 60  
 G  
 one inch = twenty feet  
 0 20 40  
 H  
 one inch = ten feet  
 0 10 20

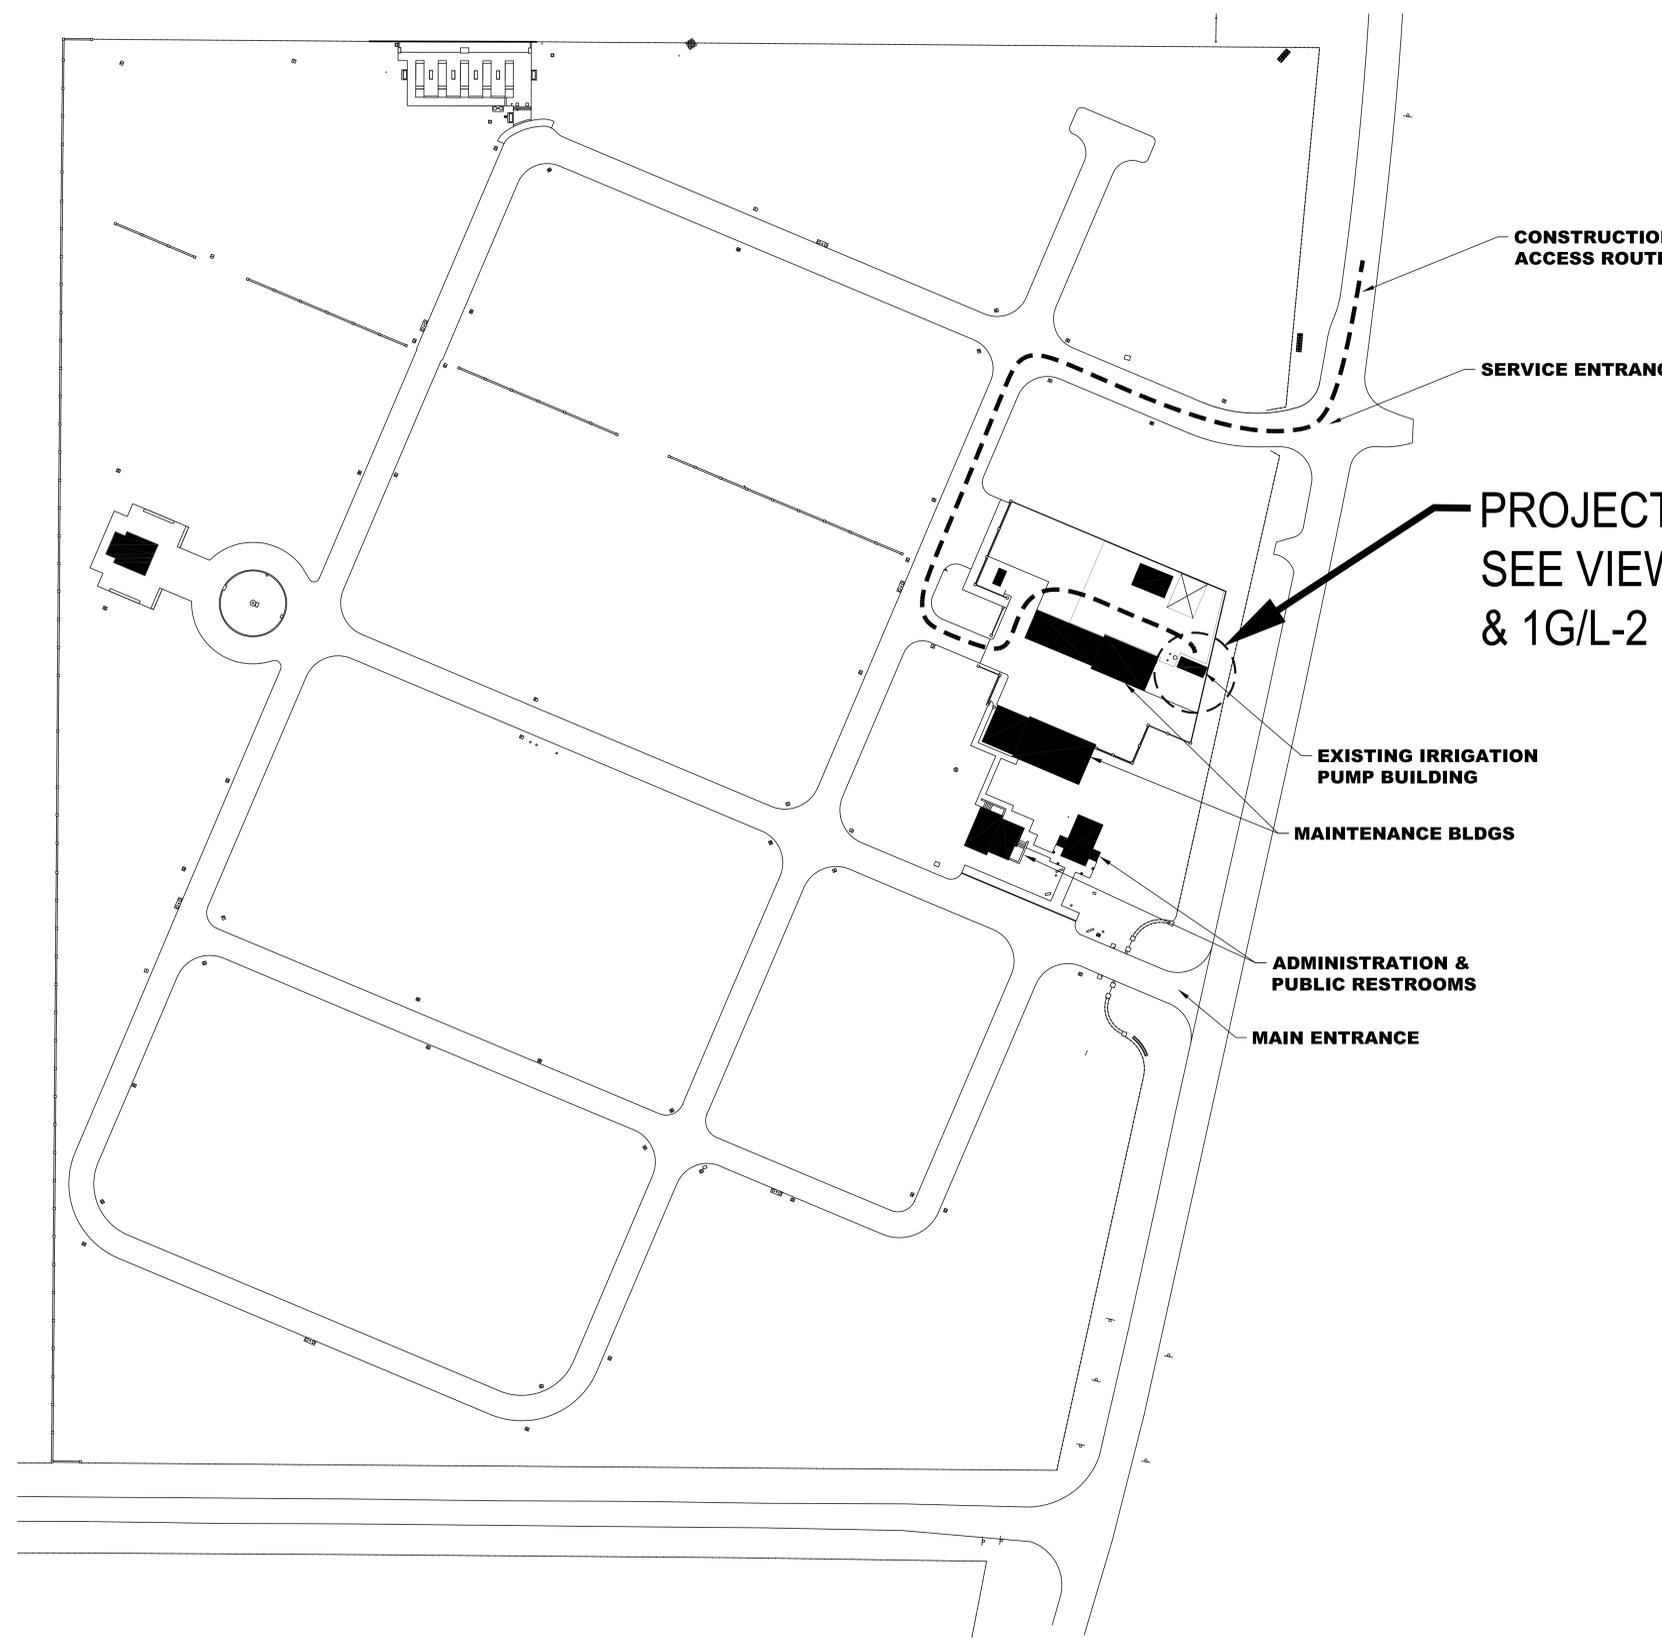

**2G**  
**L-1**  
**OVERALL CEMETERY SITE PLAN**  
 SCALE: 1" = 50' - 0"

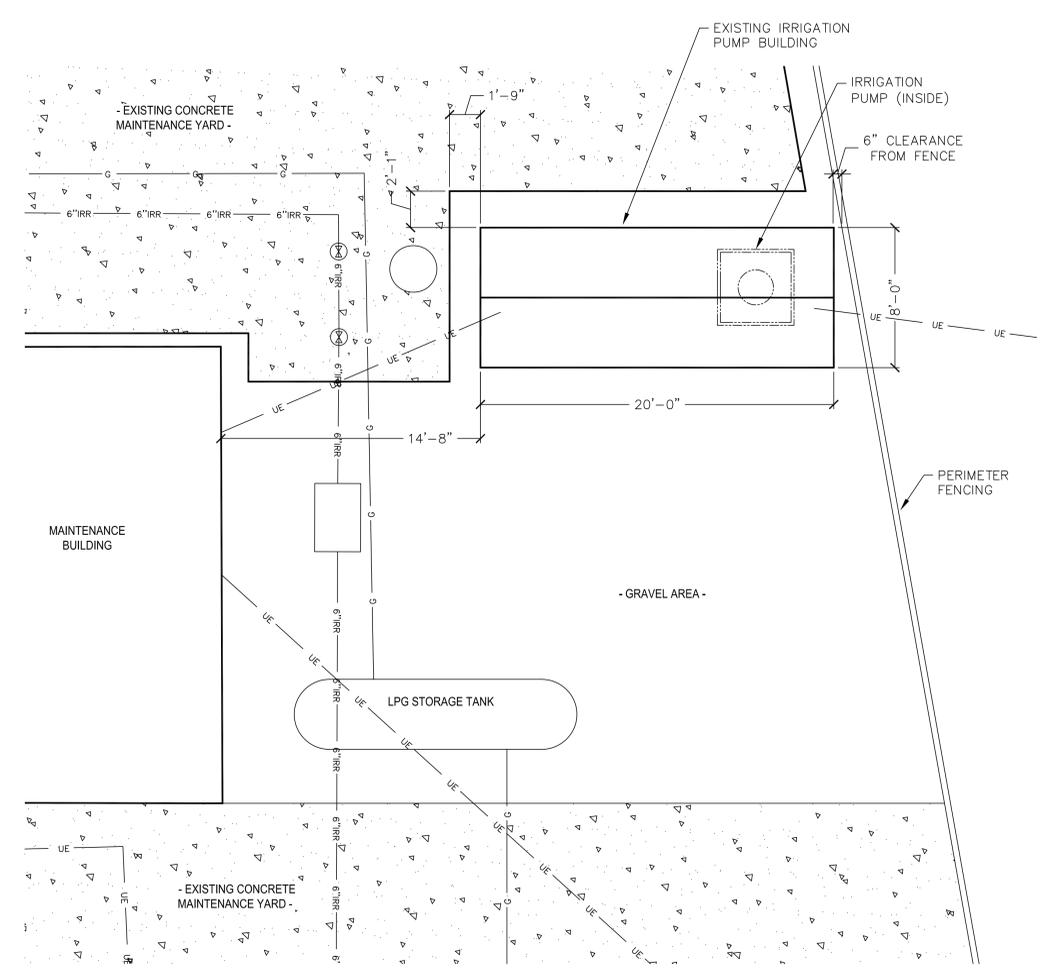


**7G**  
**L-1**  
**PLAN VIEW OF EXISTING CONDITIONS**  
 SCALE: 1/4" = 1' - 0"




**NOT FOR CONSTRUCTION**


Revisions	Date

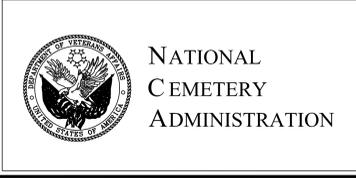


Drawing Title <b>OVERALL SITE PLAN &amp; PLAN VIEW OF EXISTING CONDITIONS</b>		Project Title <b>NEW IRRIGATION PUMP BUILDING</b>		Date <b>04/15/2015</b>
Approved: Division Chief		Building Number *****	Checked .	Drawn <b>RLD</b>
Approved: Service Director		Location <b>FORT McPHERSON NATIONAL CEMETERY</b>		Project No. <b>904-15-201</b>
<b>DRAWING NO.</b> <b>L-1</b>				<b>Dwg. 2 Of 3</b>

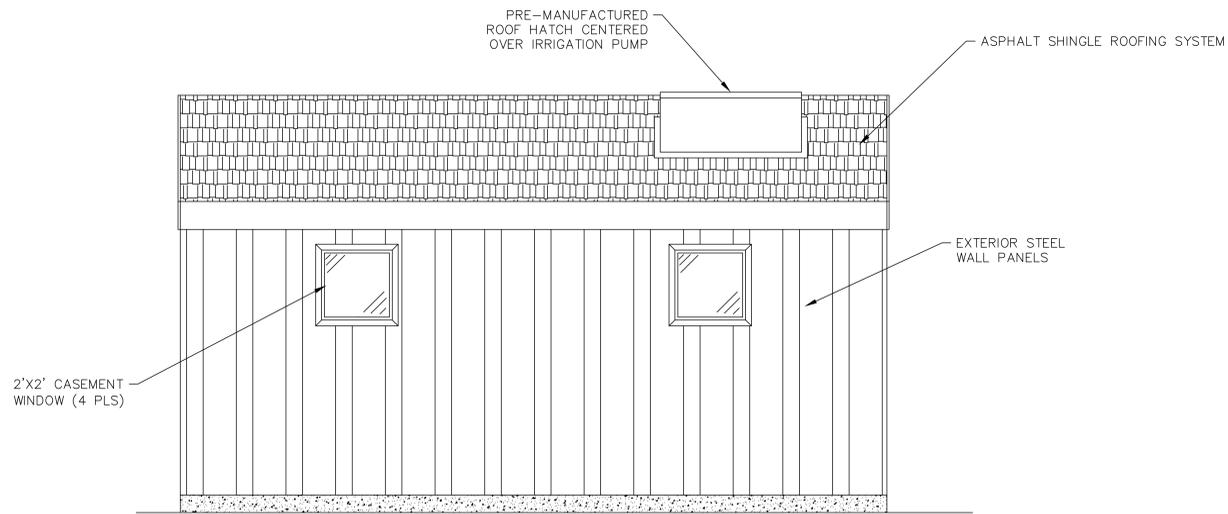

**1C** ELEVATION VIEW - SOUTH LOOKING NORTH  
**L-2** SCALE: 1/2" = 1'-0"

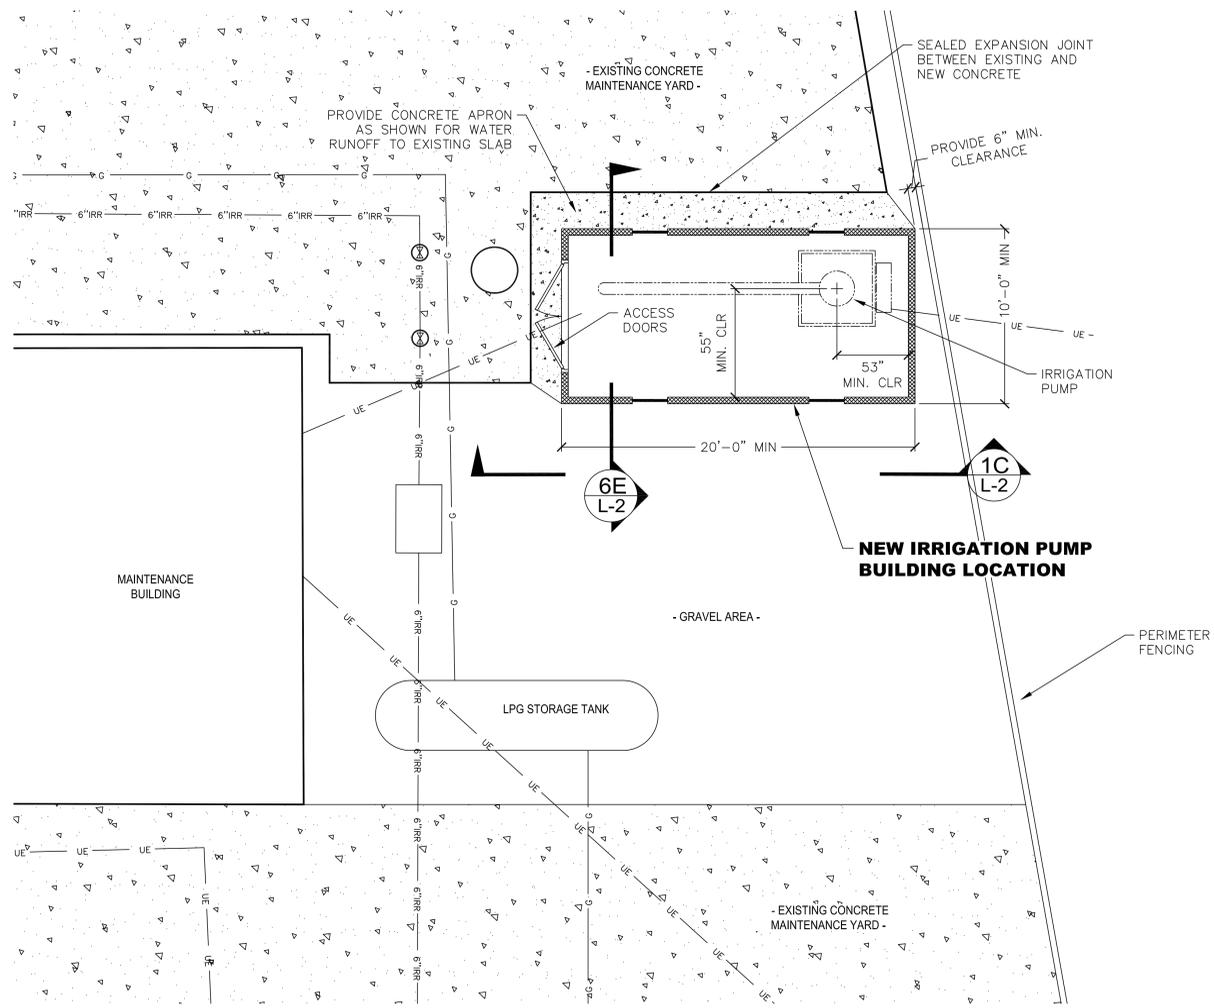

**1G** PLAN VIEW & CROSS-SECTION - NEW CONSTRUCTION  
**L-2** SCALE: 1/4" = 1'-0"

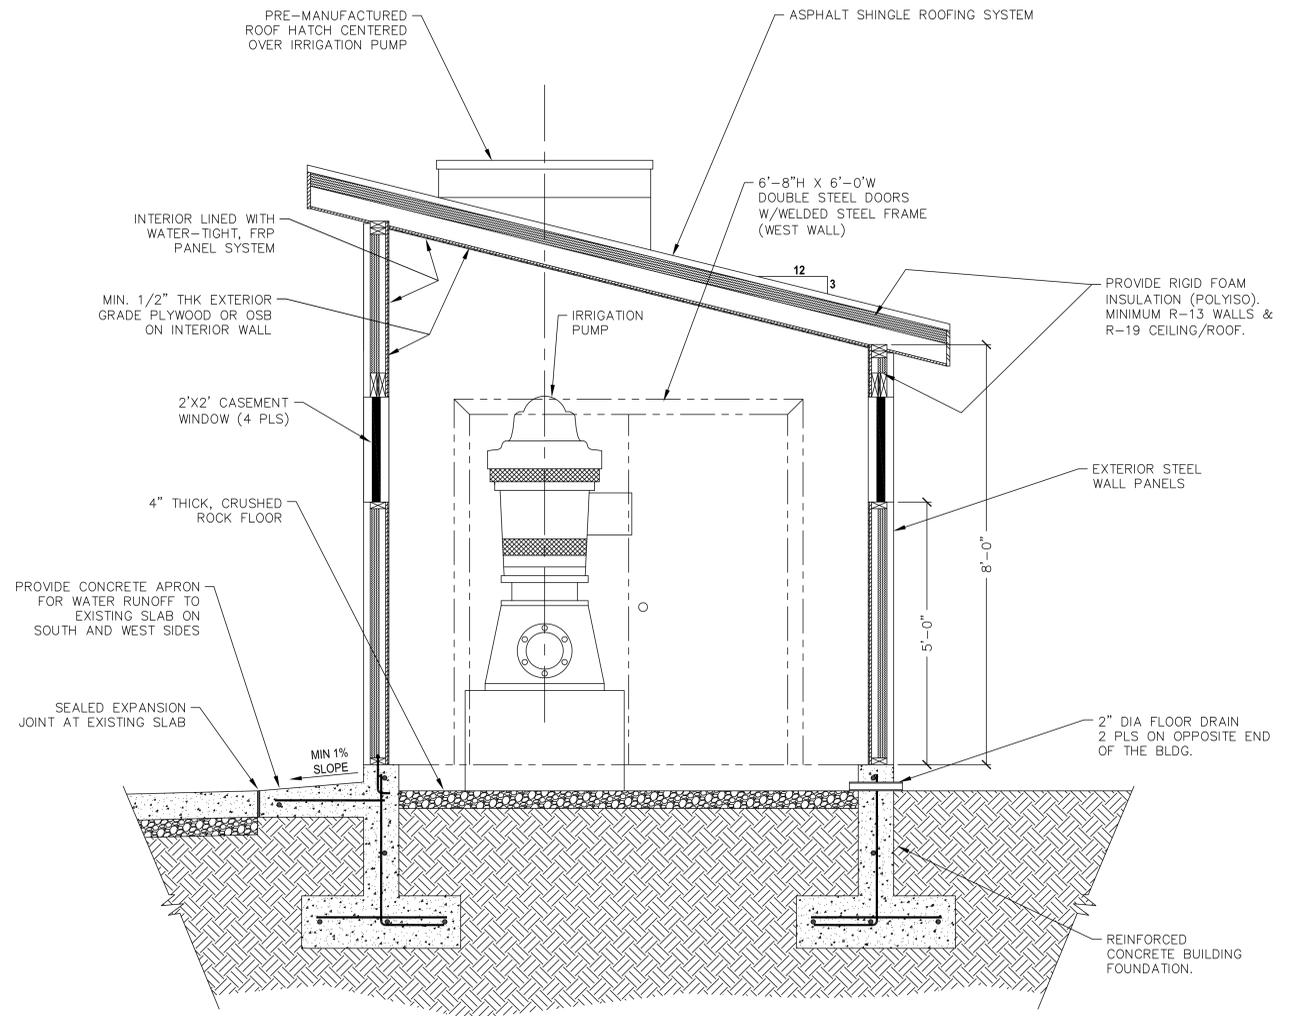

**6E** SECTION VIEW - NEW IRRIGATION PUMP BUILDING  
**L-2** SCALE: 3/4" = 1'-0"

**NOT FOR CONSTRUCTION**

Revisions	Date



NATIONAL  
 CEMETERY  
 ADMINISTRATION

Drawing Title <b>PLAN, ELEVATION, AND SECTION VIEWS</b>	Project Title <b>NEW IRRIGATION PUMP BUILDING</b>	Date <b>04/15/2015</b>
Approved: Division Chief	Building Number .....	Checked .
Approved: Service Director	Drawn <b>RLD</b>	Location <b>FORT McPHERSON NATIONAL CEMETERY</b>

Project No. <b>890-15-201</b>	DRAWING NO. <b>L-2</b>
Dwg. 3 Of 3	