


three inches = one foot
 one and one half inches = one foot
 one inch = one foot
 three quarters inch = one foot
 one half inch = one foot
 three eighths inch = one foot
 one quarter inch = one foot
 one eighth inch = one foot
 one sixteenth inch = one foot

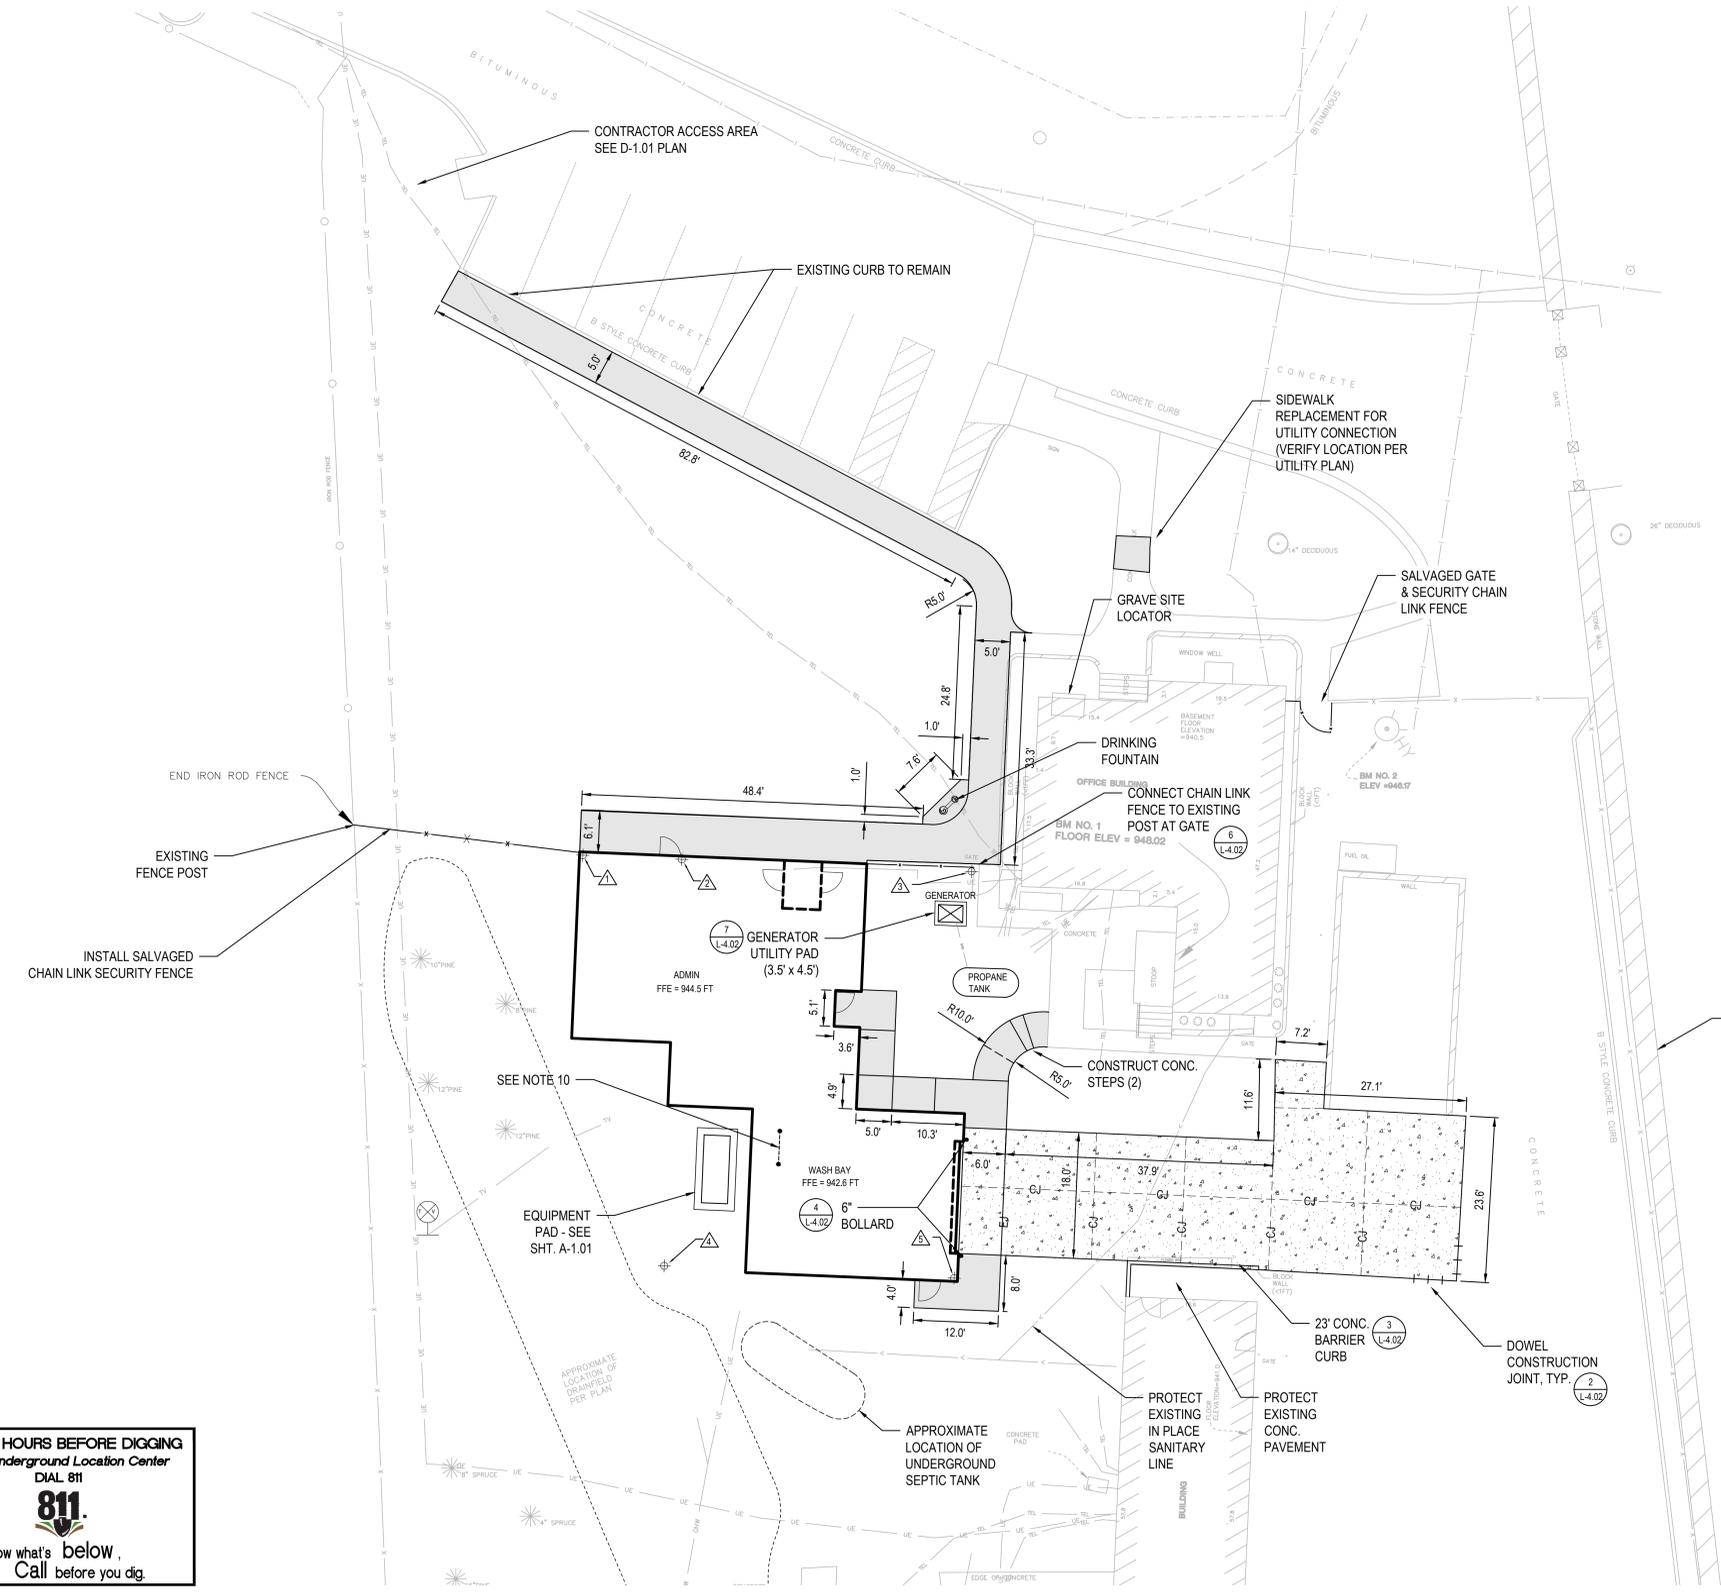


- NOTES:**
- CONTRACTOR SHALL STAKE LOCATION OF NEW BUILDING AND VERIFY WITH COR THAT LOCATION IS CORRECT PRIOR TO CONSTRUCTION.
 - ALL DIMENSIONS ARE FROM EDGE OF PAVEMENT OR BACK OF CURB, UNLESS OTHERWISE NOTED.
 - NOTIFY COR OF ANY LAYOUT DISCREPANCIES SHOWN ON THIS PLAN. FIELD VERIFY ALL DIMENSIONS PRIOR TO CONSTRUCTION.
 - ALL CONTROL OF TRAFFIC REQUIRED TO PERFORM WORK SHALL BE THE CONTRACTOR'S RESPONSIBILITY.
 - CONTROL AND EXPANSION JOINTS TO ALIGN W/ ADJACENT PAVEMENT, CURBS, WALKS, ETC. ALIGN JOINTS PERPENDICULAR TO PAVEMENT EDGE.
 - PROVIDE CONTROL JOINTS AT 8' O.C. AND EXPANSION JOINTS AT 64' O.C. IN SIDEWALK.
 - COORDINATE ACCESS WITHIN MAINTENANCE AREA WITH COR AND CEMETERY DIRECTOR.
 - VERIFY LOCATION OF GENERATOR AND PROPANE TANK (500 GAL.) WITH MECHANICAL PLANS. PROPANE TANK RELOCATED BY EMPIRE GAS COMPANY.
 - INSTALL DOWELS AT 24" O.C. AT ALL NEW/EXISTING CONCRETE PAVEMENT INTERFACE PER DETAIL 2/L-4.02.
 - STEEL GUARDRAIL. CONFIRM LOCATION WITH ARCHITECTURAL AND MECHANICAL TO PROTECT DUCTWORK.


BUILDING LAYOUT TABLE

POINT ID	NORTHING	EASTING	DESCRIPTION
△	104,148.57	1,538,918.06	ARCH GRID A-1
△	104,147.96	1,538,932.04	ARCH GRID A-2
△	104,146.24	1,538,973.07	ARCH GRID A-3
△	104,089.90	1,538,929.58	ARCH GRID F-2
△	104,088.16	1,538,970.60	ARCH GRID F-5

- LEGEND**
- AIR CONDITIONER
 - CULVERT
 - CLEAN OUT
 - CATCH BASIN
 - CONTROL POINT
 - COMMUNICATION JUNCTION BOX
 - ELECTRIC BOX
 - ELECTRIC METER
 - ELECTRIC MANHOLE
 - GUARD POST
 - HYDRANT
 - HANDICAPPED PARKING
 - HANDHOLD ELECTRIC
 - MANHOLE
 - POWER POLE
 - SIGN
 - SOIL BORING
 - WATER VALVE
 - ROOF DRAIN
 - VENT PIPE
 - SATELLITE DISH
 - CONIFEROUS TREE
 - DECIDUOUS TREE
 - SHRUB
 - BALLAD
 - POWER POLE ANCHOR
 - CHAIN LINK FENCE
 - ROD IRON FENCE
 - GAS MAIN
 - OVERHEAD WIRES
 - SANITARY SEWER
 - STORM SEWER
 - TELEPHONE
 - UNDERGROUND ELECTRIC
 - WATER MAIN
 - TV
 - DRAINFIELD LIMITS (PER PLAN)
 - HEAVY-DUTY CONCRETE PAVEMENT
 - CONCRETE SIDEWALK PAVEMENT
 - CONTROL JOINT
 - EXPANSION JOINT
 - BUILDING CONTROL POINT
 - BOLLARD

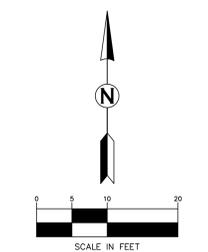

KEY PLAN

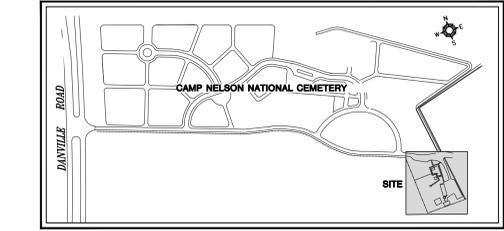

CALL 48 HOURS BEFORE DIGGING
 Utilities Underground Location Center
 DIAL 811
811
 Know what's below,
 Call before you dig.

100% CONSTRUCTION DOCUMENTS

<p>Revisions</p> <table border="1"> <tr><th>No.</th><th>Description</th><th>Date</th></tr> <tr><td> </td><td> </td><td> </td></tr> <tr><td> </td><td> </td><td> </td></tr> <tr><td> </td><td> </td><td> </td></tr> <tr><td> </td><td> </td><td> </td></tr> </table>	No.	Description	Date													<p>CONSULTANTS:</p> <p>AEI AMERICAN ENGINEERS, INC. 65 ABERDEEN DR. GLASGOW, KY 42414 (270) 651-7220 TEL. (270) 651-3246 FAX WWW.AEI.CC</p> <p>AT ADVANCED STRUCTURAL TECHNOLOGIES 7212 METRO BLVD EDINA, MN 55439 (952) 854-9302 TEL. (952) 854-9890 FAX WWW.ASTMN.COM</p> <p>KJW ENGINEERING CONSULTANTS Experience you can build on.SM STRUCTURAL • MECHANICAL • ELECTRICAL TECHNOLOGY • MEDICAL EQUIPMENT SOLUTIONS (309) 788-8673 TEL. (309) 788-5967 FAX QUAD CITIES, IL WWW.KJW.COM</p>	<p>I HEREBY CERTIFY THAT THIS PLAN, SPECIFICATION, OR REPORT WAS PREPARED BY ME OR UNDER MY DIRECT SUPERVISION AND THAT I AM A DULY LICENSED PROFESSIONAL ENGINEER UNDER THE LAWS OF THE STATE OF MINNESOTA.</p> <p>PRINT NAME: MICHAEL B. BRANDVOLD SIGNATURE: <i>[Signature]</i> DATE: 05/20/2015 LICENSE # 41258</p>	<p>ARCHITECT/ENGINEERS:</p> <p>ANDERSON ENGINEERING Anderson Engineering of Minnesota, LLC 13605 1st Avenue North Suite 100 Plymouth, MN 55441 763-412-4000 (o) 763-412-4090 (f) www.ae-mn.com</p>	<p>Drawing Title SITE PLAN</p> <p>Approved Project Director</p>	<p>Project Title WASH BAY / STORAGE BUILDING</p> <p>Location CAMP NELSON NATIONAL CEMETERY NICHOLASVILLE, KENTUCKY</p> <p>Date May 20, 2015</p> <p>Checked MBB</p> <p>Drawn DAJ</p>	<p>Project Number 833-CM3-026</p> <p>Building Number 3003</p> <p>Drawing Number L-101</p> <p>Dwg. 8 of 53</p>	<p>National Cemetery Administration</p> <p>Department of Veterans Affairs</p>
	No.	Description	Date																			
<p>VA FORM 08-6231</p>	<p>1 2 3 4 5 6 7 8 9</p>																					


three inches = one foot
 one and one half inches = one foot
 one inch = one foot
 one half inch = one foot
 three quarters inch = one foot
 one quarter inch = one foot
 three eighths inch = one foot
 one eighth inch = one foot
 one sixteenth inch = one foot

LEGEND


- BORING
- > CULVERT
- ⊕ CLEAN OUT
- ⊕ CATCH BASIN
- ⊕ CONTROL POINT
- ⊕ HYDRANT
- ⊕ LIGHT POLE
- MANHOLE
- POWER POLE
- ⊕ WATER VALVE
- * CONIFEROUS TREE
- DECIDUOUS TREE
- ⊕ INLET PROTECTION
- X-X- FENCE
- - - GAS MAIN
- - - OHW OVERHEAD WIRES
- - - STORM SEWER
- - - STORM SEWER PER PLANS
- - - EXPANSION JOINT
- - - UNDERGROUND ELECTRIC
- - - WATER MAIN
- - - SANITARY SEWER
- - - SILT FENCE
- - - 940 PROPOSED CONTOUR
- ▨ ROCK CONSTRUCTION ENTRANCE

GENERAL NOTES:

1. SILT FENCE TO BE INSTALLED PRIOR TO CONSTRUCTION AND REMOVED AFTER CONSTRUCTION.
2. CONTRACTOR TO INSTALL INLET PROTECTION ON ALL EXISTING AND NEW CATCH BASINS DOWN GRADIENT FROM CONTINUED CONSTRUCTION. REMOVE INLET PROTECTION FOR EACH PHASE OF CONSTRUCTION WHEN COMPLETE.
3. SEE SHEET L-2.02 FOR EROSION CONTROL DETAILS.
4. SEE DEMOLITION PLAN D-1.03 FOR LIMITS OF CONSTRUCTION AND LOCATION OF TEMPORARY PERIMETER FENCE.

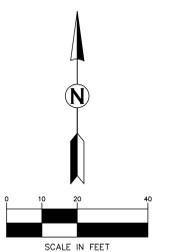

KEY PLAN

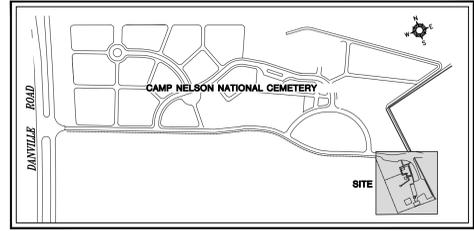

CALL 48 HOURS BEFORE DIGGING
 Utilities Underground Location Center
DIAL 811

 Know what's below,
 Call before you dig.

100% CONSTRUCTION DOCUMENTS

Revisions	Date

CONSULTANTS:

AEI AMERICAN ENGINEERS, INC.
 65 ABERDEEN DR.
 GLASGOW, KY 42414
 (270) 651-7220 TEL. (270) 651-3246 FAX
 WWW.AEI.CC

A&T ADVANCED STRUCTURAL TECHNOLOGIES
 7212 METRO BLVD
 EDINA, MN 55439
 (952) 854-9302 TEL. (952) 854-9890 FAX
 WWW.ASTMN.COM

KJW ENGINEERING CONSULTANTS
 Experience you can build on.SM
 STRUCTURAL • MECHANICAL • ELECTRICAL
 TECHNOLOGY | MEDICAL EQUIPMENT SOLUTIONS
 (309) 786-8672 TEL. (309) 786-5967 FAX
 QUAD CITIES, IL WWW.KJWW.COM

I HEREBY CERTIFY THAT THIS PLAN, SPECIFICATION, OR REPORT WAS PREPARED BY ME OR UNDER MY DIRECT SUPERVISION AND THAT I AM A DULY LICENSED PROFESSIONAL ENGINEER UNDER THE LAWS OF THE STATE OF MINNESOTA.
 PRINT NAME: MICHAEL B. BRANDIVOLD
 SIGNATURE: *Michael B. Brandivold*
 DATE: 05/20/2015
 LICENSE # 41258

ARCHITECT/ENGINEERS:

ANDERSON ENGINEERING
 Anderson Engineering of Minnesota, LLC
 13605 1st Avenue North
 Suite 100
 Plymouth, MN 55441
 763-412-4000 (o) 763-412-4090 (f)
 www.ae-mn.com

Drawing Title	SEDIMENT + EROSION CONTROL PLAN
Approved Project Director	


Project Title	WASH BAY / STORAGE BUILDING
Location	CAMP NELSON NATIONAL CEMETERY NICHOLASVILLE, KENTUCKY
Date	May 20, 2015
Checked	MBB
Drawn	DAJ

Project Number	833-CM3-026
Building Number	3003
Drawing Number	L-2.01
Dwg	9 of 53

National Cemetery Administration

 Department of Veterans Affairs

three inches = one foot
one and one half inches = one foot
one inch = one foot
three quarters inch = one foot
one half inch = one foot
three eighths inch = one foot
one quarter inch = one foot
one eighth inch = one foot
one sixteenth inch = one foot

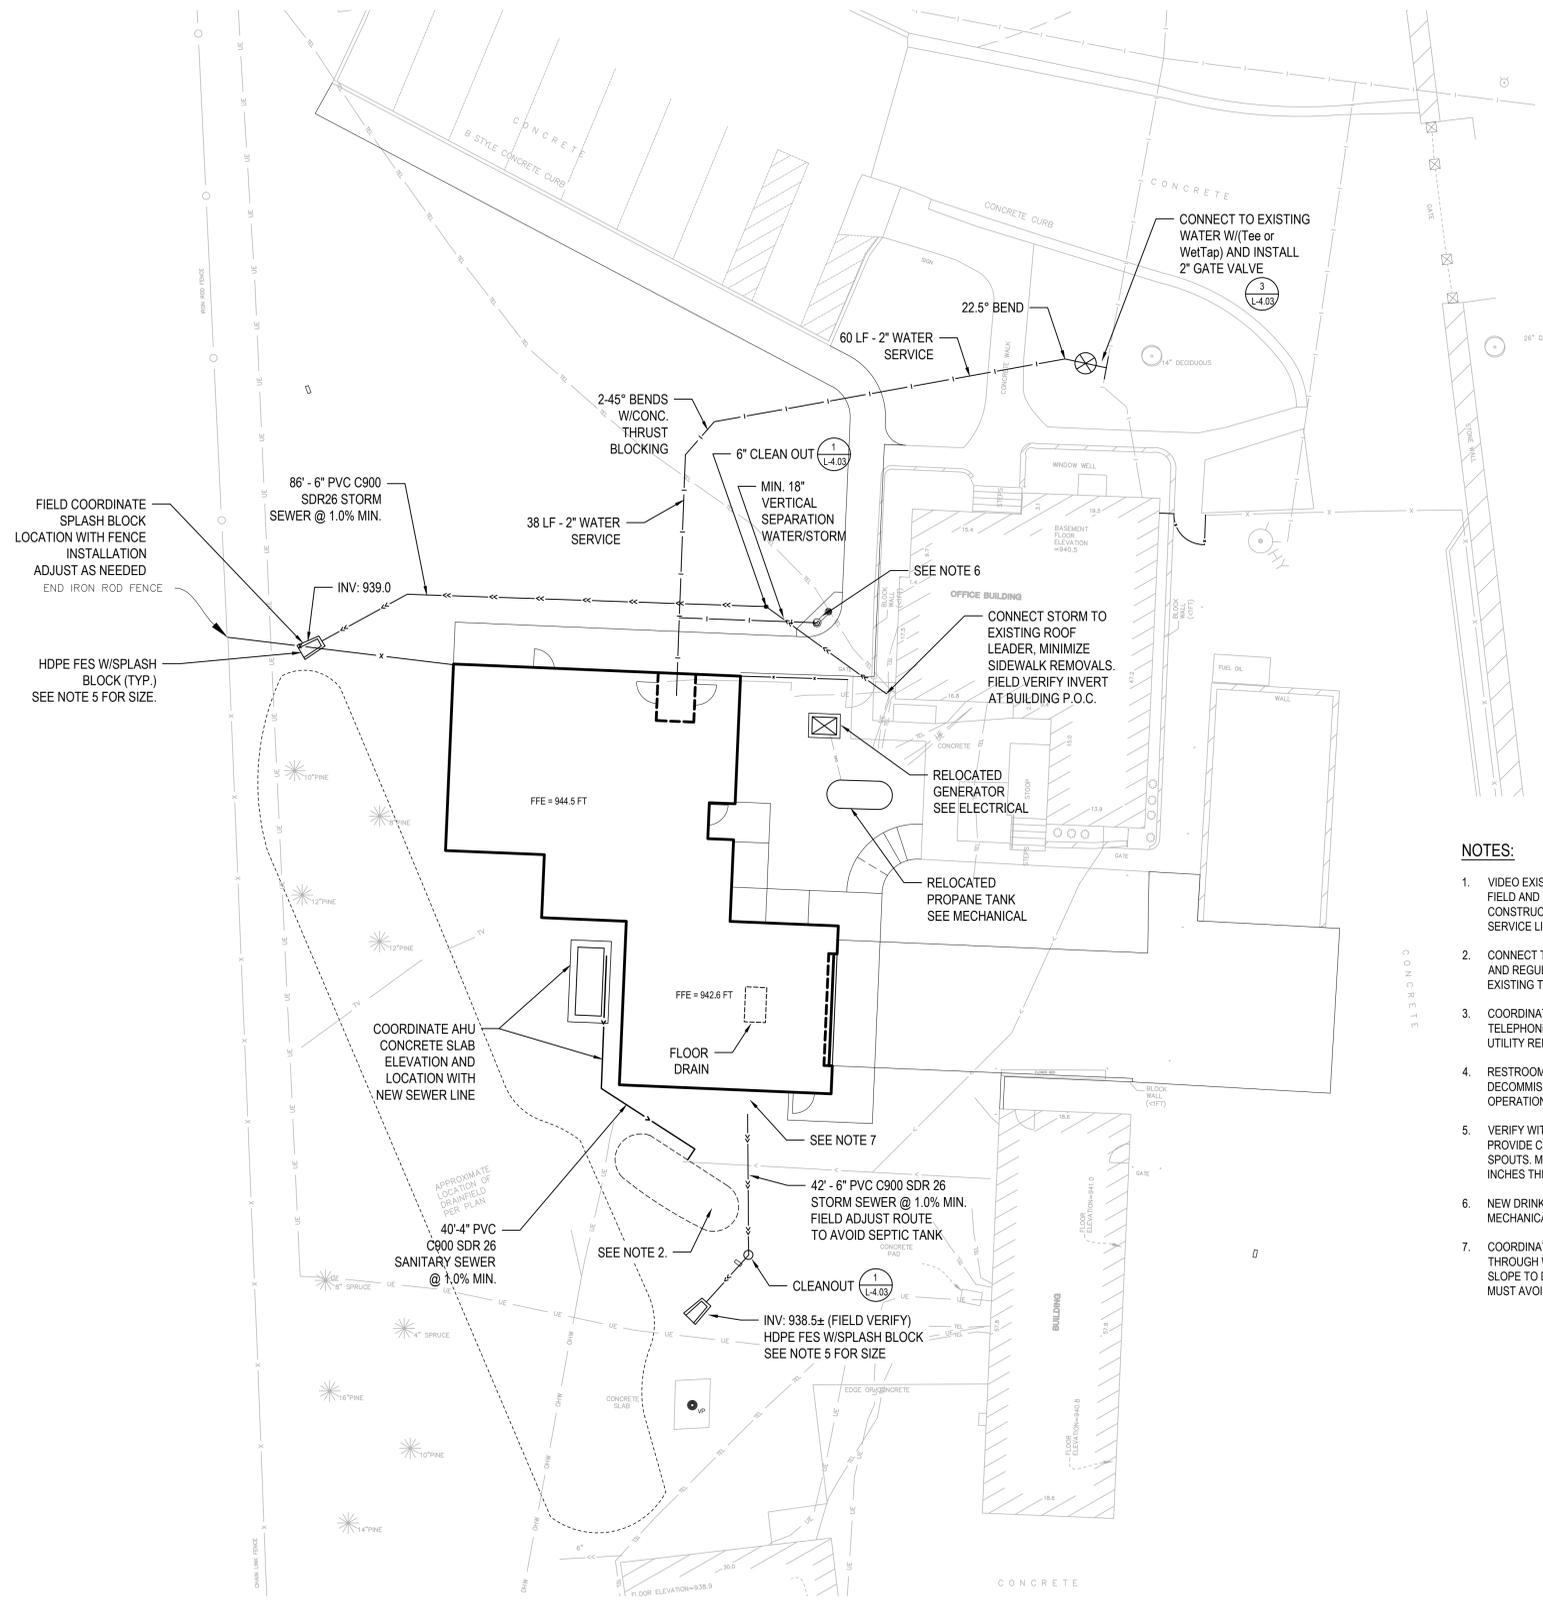


LEGEND


- AIR CONDITIONER
- CULVERT
- CLEAN OUT
- CATCH BASIN
- CONTROL POINT
- COMMUNICATION JUNCTION BOX
- ELECTRIC BOX
- ELECTRIC METER
- ELECTRIC MANHOLE
- GUARD POST
- HYDRANT
- HANDICAPPED PARKING
- MANHOLE
- POWER POLE
- SIGN
- SOIL BORING
- WATER VALVE
- ROOF DRAIN
- VENT PIPE
- SATELLITE DISH
- CLEAN OUT
- CONIFEROUS TREE
- DECIDUOUS TREE
- SHRUB
- POWER POLE ANCHOR
- CHAIN LINK FENCE
- ROD IRON FENCE
- GAS MAIN
- OVERHEAD WIRES
- SANITARY SEWER
- STORM SEWER
- TELEPHONE
- UNDERGROUND ELECTRIC
- WATER MAIN
- TV
- DRAINFIELD LIMITS (PER PLAN)
- NEW SANITARY SEWER
- NEW STORM SEWER
- NEW WATER SERVICE
- CLEANOUT

NOTES:

1. VIDEO EXISTING SEWER SERVICE FROM SEPTIC TANK TO DRAIN FIELD AND PROVIDE REPORT ON CONDITIONS OF PIPE PRIOR TO CONSTRUCTION TO COR. VERIFY INVERT ELEVATIONS OF ALL SERVICE LINES AT LODGE BUILDING AND AT TANK.
2. CONNECT TO EXISTING SANITARY SEPTIC TANK PER LOCAL CODES AND REGULATIONS. FIELD VERIFY EXACT CONNECTION POINT INTO EXISTING TANK.
3. COORDINATE WITH PRIVATE SMALL UTILITIES (ELECTRIC, TELEPHONE, ETC.) FOR LOCATION PRIOR TO EXCAVATION AND UTILITY REMOVALS PER DEMOLITION PLAN.
4. RESTROOM FACILITY IN EXISTING MAINTENANCE BUILDING TO BE DECOMMISSIONED AFTER NEW BUILDING IS COMPLETE AND OPERATIONAL, BY OTHERS.
5. VERIFY WITH ARCHITECTURAL FOR LOCATIONS OF DOWN SPOUTS. PROVIDE CONCRETE SPLASH BLOCK AT ALL BUILDING DOWN SPOUTS. MINIMUM SIZE 24 INCHES WIDE BY 48 INCHES LONG BY 5 INCHES THICK.
6. NEW DRINKING FOUNTAIN. CONFIRM SERVICE SUPPLY WITH MECHANICAL.
7. COORDINATE FLOOR DRAIN DISCHARGE VERTICAL PIPE ELEVATION THROUGH WALL/FOOTING TO ENSURE POSITIVE DISCHARGE SLOPE TO DOWNSTREAM OUTLET. DISCHARGE INVERT LOCATION MUST AVOID SEPTIC FIELD.

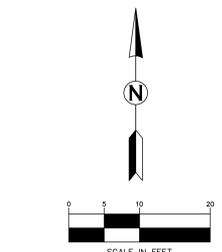

KEY PLAN

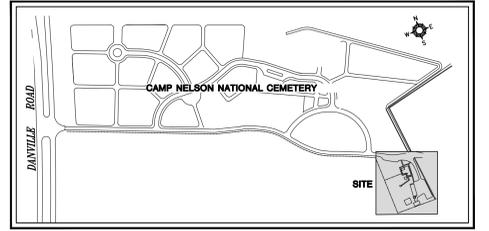

CALL 48 HOURS BEFORE DIGGING
Utilities Underground Location Center
DIAL 811

Know what's below. Call before you dig.

Revisions	Date

CONSULTANTS:

AMERICAN ENGINEERS, INC.
PROFESSIONAL ENGINEERS
 65 ABERDEEN DR.
 GLASGOW, KY 42414
 (270) 651-7220 TEL. (270) 651-3246 FAX
 WWW.AEI.CC

ADVANCED STRUCTURAL TECHNOLOGIES
 7212 METRO BLVD
 EDINA, MN 55439
 (952) 854-9302 TEL. (952) 854-9890 FAX
 WWW.ASTMN.COM

ENGINEERING CONSULTANTS
Experience you can build on™
 STRUCTURAL • MECHANICAL • ELECTRICAL
 TECHNOLOGY • MEDICAL EQUIPMENT SOLUTIONS
 (309) 788-8672 TEL. (309) 786-5967 FAX
 QUAD CITIES, IL WWW.KJW.COM

I HEREBY CERTIFY THAT THIS PLAN, SPECIFICATION, OR REPORT WAS PREPARED BY ME OR UNDER MY DIRECT SUPERVISION AND THAT I AM A DULY LICENSED PROFESSIONAL ENGINEER UNDER THE LAWS OF THE STATE OF MINNESOTA.
 PRINT NAME: MICHAEL B. BRANDVOLD
 SIGNATURE:
 DATE: 05/20/2015
 LICENSE # 41258

ARCHITECT/ENGINEERS:

ANDERSON ENGINEERING

Anderson Engineering of Minnesota, LLC
 13605 1st Avenue North
 Suite 100
 Plymouth, MN 55441
 763-412-4000 (o) 763-412-4090 (f)
 www.ae-mn.com

Drawing Title	UTILITY PLAN
Approved Project Director	

Project Title	WASH BAY / STORAGE BUILDING		
Location	CAMP NELSON NATIONAL CEMETERY NICHOLASVILLE, KENTUCKY		
Date	Checked	Drawn	Dwg. No.
May 20, 2015	MBB	DAJ	L-4.01
			Dwg. 12 of 53


National Cemetery Administration

Department of Veterans Affairs


100% CONSTRUCTION DOCUMENTS

three inches = one foot
 one and one half inches = one foot
 one inch = one foot
 three quarters inch = one foot
 one half inch = one foot
 three eighths inch = one foot
 one quarter inch = one foot
 one eighth inch = one foot
 one sixteenth inch = one foot


A
 B
 C
 D
 E
 F

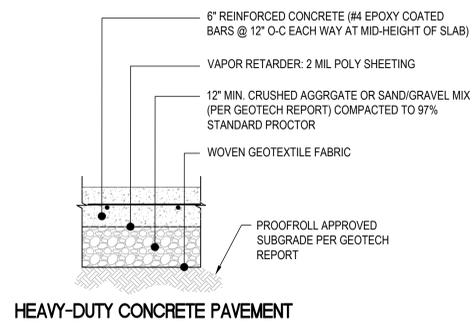


HEAVY-DUTY CONCRETE PAVEMENT

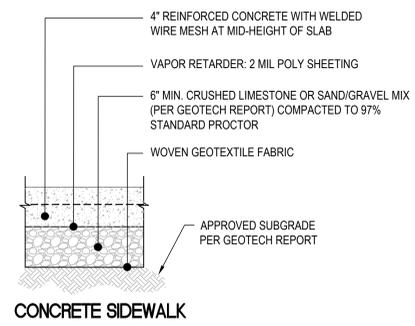


CONCRETE SIDEWALK

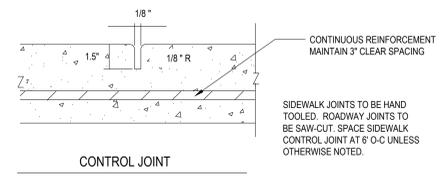


CONTROL JOINT

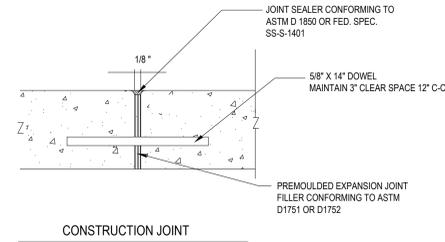


CONSTRUCTION JOINT

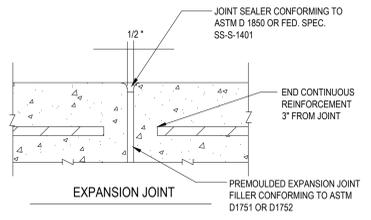

EXPANSION JOINT

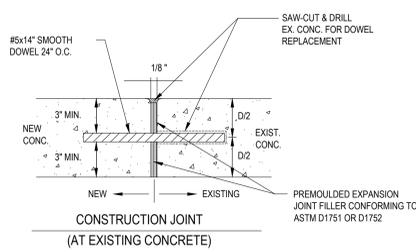


CONSTRUCTION JOINT (AT EXISTING CONCRETE)

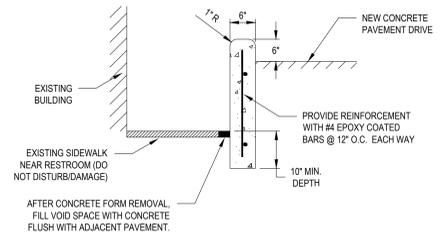


3 CONCRETE BARRIER CURB
 L-402 NOT TO SCALE

1 CONCRETE PAVEMENTS
 L-402 N.T.S.


2 CONCRETE JOINTING TYPES
 L-402 NOT TO SCALE

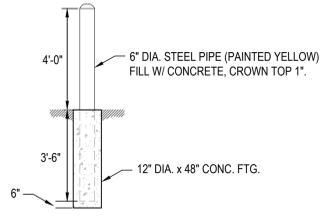


4 BOLLARD
 L-402 N.T.S.

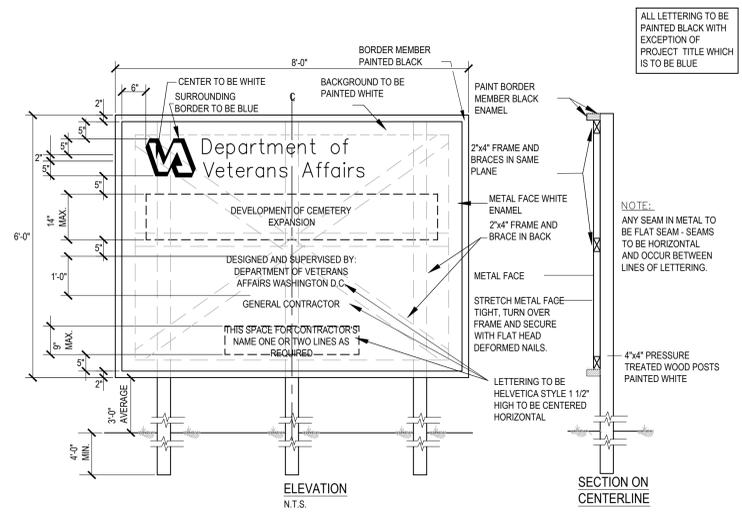

5 PROJECT CONSTRUCTION SIGN
 L-402 N.T.S.

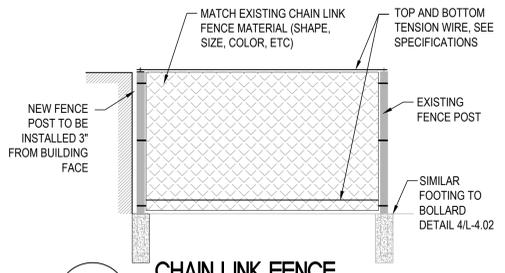

6 CHAIN LINK FENCE
 L-402 N.T.S.

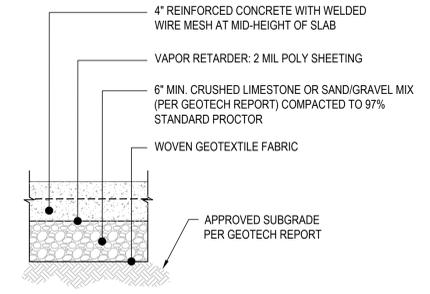

7 CONCRETE UTILITY PAD
 L-402 N.T.S.

VA FORM 08-6231

Revisions	Date

CONSULTANTS:

AMERICAN ENGINEERS, INC.
 65 ABERDEEN DR.
 GLASGOW, KY 42414
 (270) 651-7220 TEL. (270) 651-3246 FAX
 WWW.AEI.CC

ADVANCED STRUCTURAL TECHNOLOGIES
 7212 METRO BLVD
 EDINA, MN 55439
 (952) 854-9332 TEL. (952) 854-9890 FAX
 WWW.ASTM.COM

KJWW ENGINEERING CONSULTANTS
 Experience you can build on.SM
 STRUCTURAL • MECHANICAL • ELECTRICAL
 TECHNOLOGY • MEDICAL EQUIPMENT SOLUTIONS
 (309) 788-8973 TEL. (309) 788-5967 FAX
 QUAD CITIES, IL WWW.KJWW.COM

I HEREBY CERTIFY THAT THIS PLAN, SPECIFICATION, OR REPORT WAS PREPARED BY ME OR UNDER MY DIRECT SUPERVISION AND THAT I AM A DULY LICENSED PROFESSIONAL ENGINEER UNDER THE LAWS OF THE STATE OF MINNESOTA.
 PRINT NAME: MICHAEL B. BRANDVOLD
 SIGNATURE: *Michael B. Brandvold*
 DATE: 05/20/2015
 LICENSE # 41258

ARCHITECT/ENGINEERS:

Anderson Engineering of Minnesota, LLC
 13605 1st Avenue North
 Suite 100
 Plymouth, MN 55441
 763-412-4000 (o) 763-412-4090 (f)
 www.ae-mn.com


Drawing Title	CIVIL DETAILS
Approved Project Director	

Project Title	WASH BAY / STORAGE BUILDING
Location	CAMP NELSON NATIONAL CEMETERY NICHOLASVILLE, KENTUCKY
Date	May 20, 2015
Checked	MBB
Drawn	DAJ
Project Number	833-CM3-026
Building Number	3003
Drawing Number	L-402
Dwg. 13 of 53	


100% CONSTRUCTION DOCUMENTS

National Cemetery Administration


three inches = one foot
 one and one half inches = one foot
 one inch = one foot
 three quarters inch = one foot
 one half inch = one foot
 three eighths inch = one foot
 one quarter inch = one foot
 one eighth inch = one foot
 one sixteenth inch = one foot

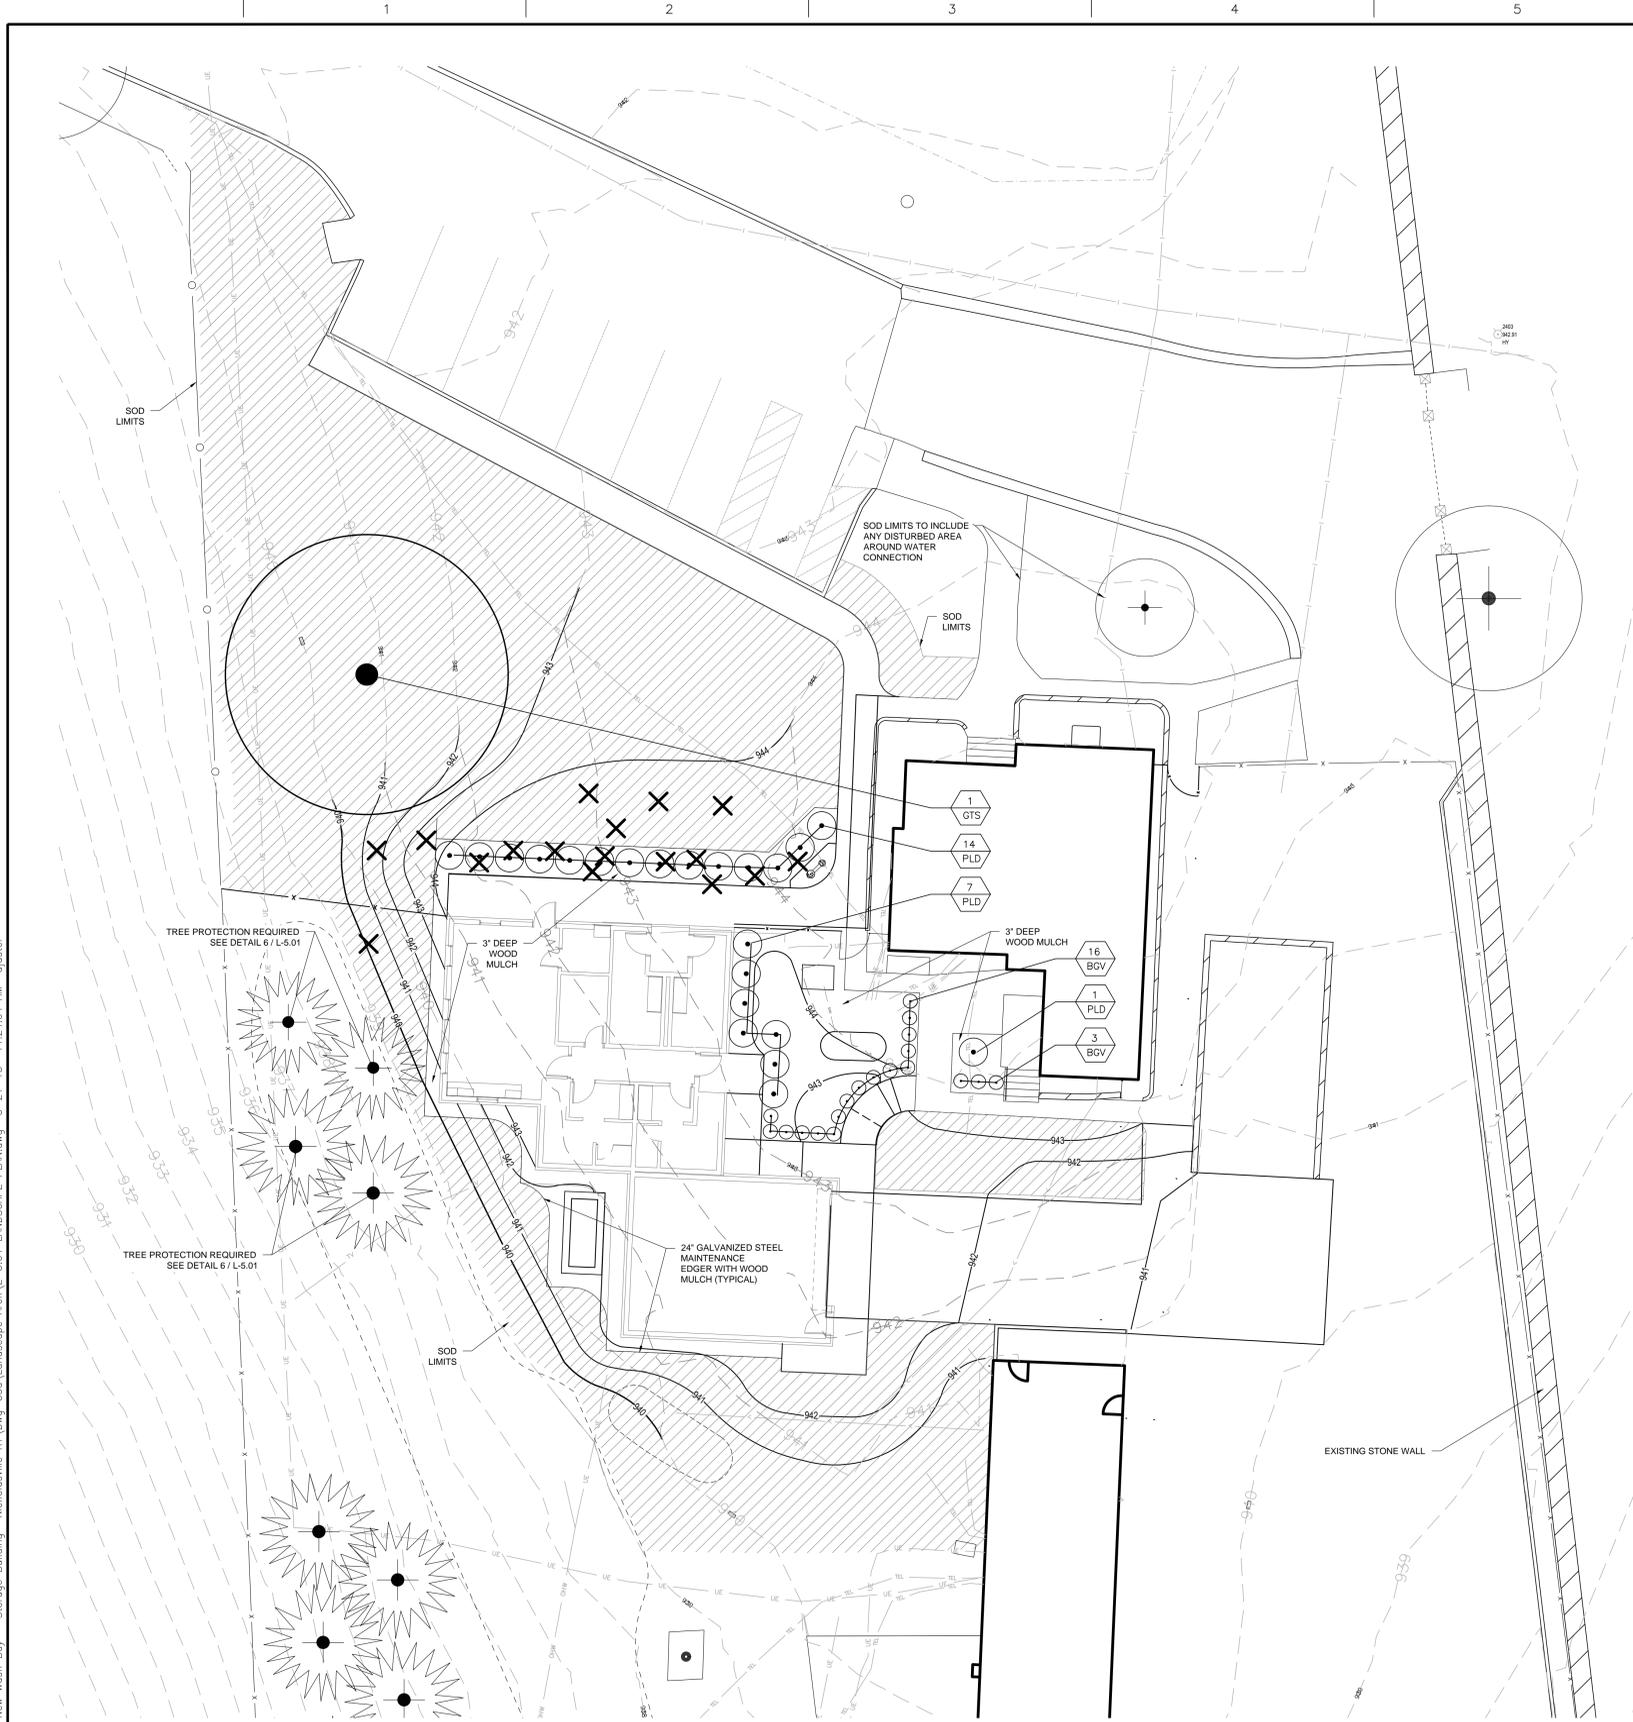


1 PLANTING PLAN OVERALL
 SCALE: 1"=10'

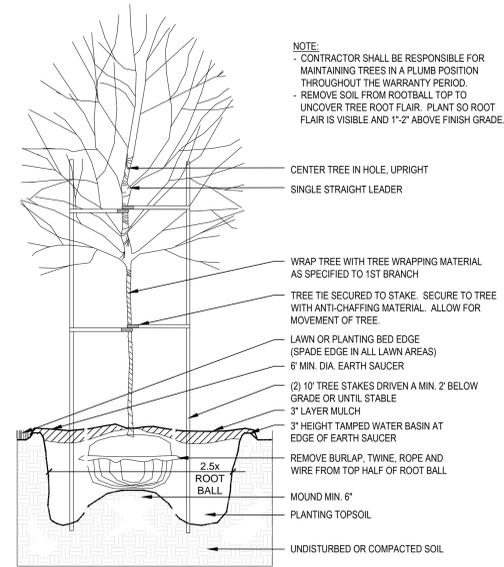

2 DECIDUOUS TREE PLANTING (TYP)
 SCALE: N.T.S.

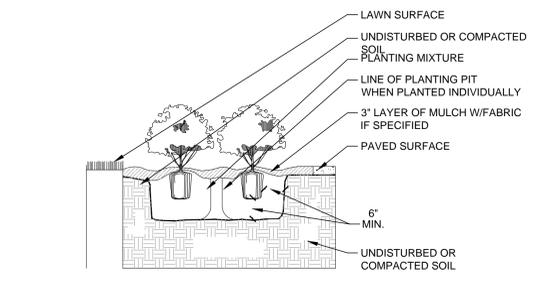

3 DECIDUOUS SHRUB PLANTING (TYP)
 SCALE: N.T.S.

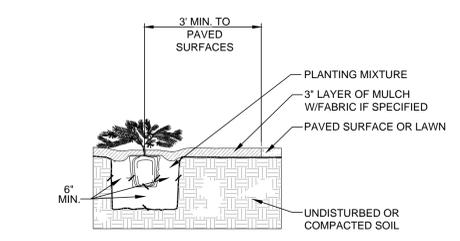


4 EVERGREEN SHRUB PLANTING (TYP)
 SCALE: N.T.S.


PLANT LIST:

Qty.	Key	Common & Botanical Names	Size	Cont.	Remarks
SHADE TREES					
1	GTS	Honeylocust, 'Shademaster'	4" Cal.	BB	
DECIDUOUS SHRUBS					
22	PLD	Ninebark, 'Little Devil'	5 Gal.	Cont.	Min. 5 canes @ 18" ht.
		<i>Physocarpus opulifolius</i> 'Little Devil'			
EVERGREEN SHRUBS					
19	BGV	Boxwood, 'Green Velvet'	5 Gal.	Cont.	Min. 5 canes @ 12" ht.
		<i>Buxus</i> 'Green Velvet'			

NOTE:
 1. IF THERE IS A DISCREPANCY BETWEEN THE NUMBER OF PLANTS SHOWN ON THE PLAN AND THE NUMBER OF PLANTS SHOWN IN THE PLANT LIST, THE NUMBER OF PLANTS SHOWN ON THE PLAN WILL TAKE PRECEDENCE.
 2. SEE SPECIFICATIONS FOR ADDITIONAL INFORMATION

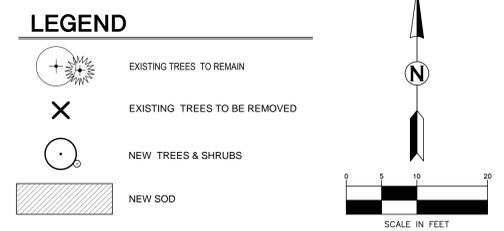

5 GROUNDCOVER SPACING
 SCALE: N.T.S.


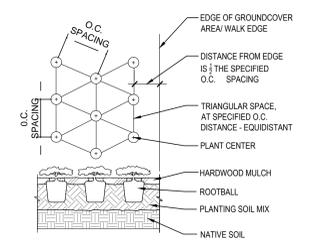


FENCING/ROOT PROTECTION
 4' HIGH ORANGE POLY CONSTRUCTION FENCING SHALL BE PROVIDED AND MAINTAINED AT THE DRIPLINE OF EACH TREE OR AROUND A GROUP OF TREES AT THE DRIPLINE OF OUTSIDE TREES.

THE ENGINEER'S APPROVAL IS REQUIRED FOR USE/ACCESS WITHIN ZONE B. PERMISSION FOR USE/ACCESS REQUIRES SURFACE PROTECTION FOR ALL UNFENCED, UNPAVED SURFACES WITHIN ZONE B AT ALL TIMES.

* SURFACE PROTECTION MEASURES
 1. MULCH LAYER: @ 6"-8" DEPTH
 2. 3/4" PLYWOOD
 3. STEEL PLATES

6 EXISTING TREE PROTECTION
 SCALE: N.T.S.

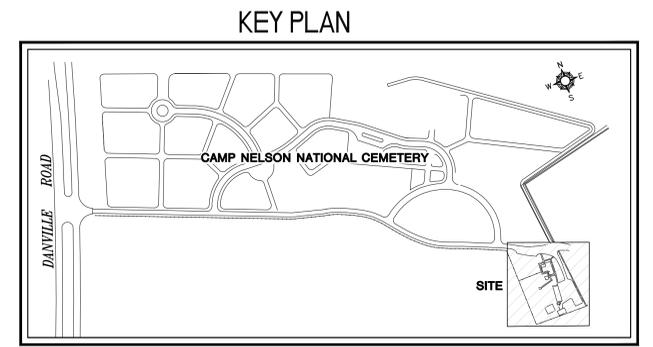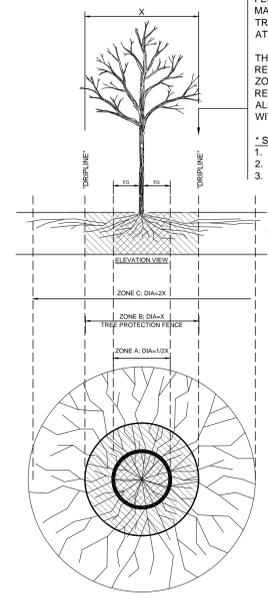

100% CONSTRUCTION DOCUMENTS

Revisions	Date

CONSULTANTS:

AEI AMERICAN ENGINEERS, INC.
 65 ABERDEEN DR.
 GLASGOW, KY 42411
 (270) 651-7220 TEL. (270) 651-3246 FAX
 WWW.AEI.CC

A+T ADVANCED STRUCTURAL TECHNOLOGIES
 7212 METRO BLVD
 EDINA, MN 55439
 (952) 854-9332 TEL. (952) 854-9890 FAX
 WWW.ASTMN.COM

KJW ENGINEERING CONSULTANTS
 Experience you can build on.SM
 STRUCTURAL / MECHANICAL / ELECTRICAL
 TECHNOLOGY / MEDICAL EQUIPMENT SOLUTIONS
 (309) 788-8072 TEL. (309) 788-5987 FAX
 QUAD CITIES, IL WWW.KJW.COM

I HEREBY CERTIFY THAT THIS PLAN, SPECIFICATION, OR REPORT WAS PREPARED BY ME OR UNDER MY DIRECT SUPERVISION AND THAT I AM A DULY LICENSED LANDSCAPE ARCHITECT UNDER THE LAWS OF THE STATE OF MINNESOTA.

PRINT NAME: CURT H. CLAEYS
 SIGNATURE: *[Signature]*
 DATE: 05/20/2015
 LICENSE # 45613

ARCHITECT/ENGINEERS:

ANDERSON ENGINEERING
 Anderson Engineering of Minnesota, LLC
 13605 1st Avenue North
 Suite 100
 Plymouth, MN 55441
 763-412-4000 (o) 763-412-4090 (f)
 www.ae-mn.com

ENGINEERING • ARCHITECTURE • LAND SURVEYING
 ENVIRONMENTAL SERVICES • LANDSCAPE ARCHITECTURE

Drawing Title
LANDSCAPE PLAN

Approved Project Director

Project Title
WASH BAY / STORAGE BUILDING

Project Number
833-CM3-026

Building Number
3003

Location
**CAMP NELSON NATIONAL CEMETERY
 NICHOLASVILLE, KENTUCKY**

Date
May 20, 2015

Checked
CHC

Drawn
JAF

Drawing Number
L-5.01

Dwg. 15 of 53

National Cemetery Administration
 Department of Veterans Affairs