


Mixing Valve/Room Schedule		
Room No.	Sinks	Mixing Valves
5A-101	1	1
5A-106	3	1
5A-107	1	1
5A-111	1	1
5A-118	1	1
5A-120	3	1
5A-128	1	1
5AB-101	2	1
5AB-102	1	1
5AB-111	1	1
5B-103	1	1
5B-105	1	1
5B-107	1	1
5B-111	1	1
5B-112A	1	1
5B-113	1	1
5B-115	1	1
5B-120	1	1
5B-121	1	1

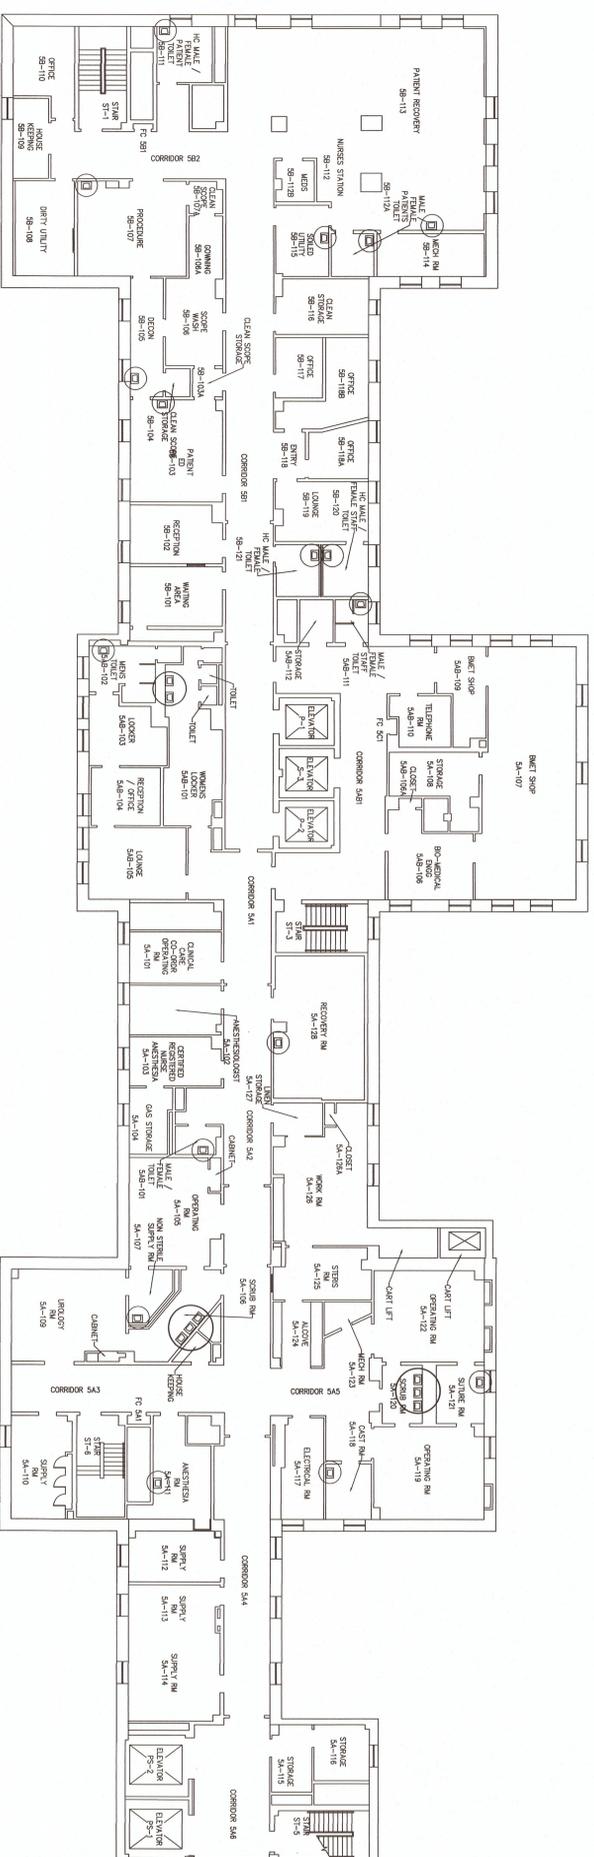

FIFTH FLOOR PLAN
Building 1

(Alt. Deduct #1)

General Notes :

- All water outages must be schedules in advance with COR.
- It is the contractors responsibility to repair or replace any property damaged by the contractor during construction.
- Contractor shall supply VA with a schedule.
- It is the Contractors responsibility to verify all Faucet types to determined which type of mixing valve is required.
- Contractor is to conduct water flushing after each water outage. Contractor to conduct chlorine test following each flushing and supply test results to COR.

Demolition Notes :

- Any piping, valves, etc demoed shall be recycled in a VA provided container. See COR for location of recycling container.


New Work Notes :

- Contractor to repair any damage to finishes after valves have been installed. Finishes to match existing.
- Contractor to clean room and advise COR before proceeding to next room.
- Contractor to install 1 mixing valve and 2 stops to all sinks indicated in mixing valve/room schedule on this sheet.

Legend:

- Sink with new mixing valve and 2 - stops.

NOT TO SCALE

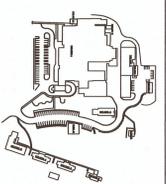

APPROVED:	APPROVED: SAFETY MANAGER	APPROVED: CHIEF, FACILITIES MANAGEMENT SERVICE LINE	APPROVED: MEDICAL CENTER DIRECTOR
APPROVED:	JUSTIN GREENE	JOHN MONTGOMERY	KARIN MCGRAW, MSN, FACHE
APPROVED:	APPROVED: INFECTION CONTROL	APPROVED: ASSOCIATE DIRECTOR for PATIENT CARE SERVICES/EXECUTIVE NURSE	APPROVED: ASSOCIATE DIRECTOR
APPROVED:	CARLA RAYNES	DEBRA LEGG, RN, MSN	ALLEN MOYE
APPROVED:		APPROVED: SERVICE LINE CHIEF	APPROVED: CHIEF OF STAFF
			JOHN D. BERRYMAN, M. D.

DRAWING TITLE:	Fifth Floor - Mixing Valve Installation Locations	DRAWING No.:	PL-103
PROJECT TITLE:	Legionella Prevention Corrections	PROJECT No.:	517-16-112
DATE:	11/10/15	DRAWN BY:	JPP
REV.		CHECKED BY:	KB, JH
SCALE:			

Medical Center
200 Veterans Av
Beckley, WV.
25801

