



Three inches = one foot
 one and one half inches = one foot
 one inch = one foot
 three quarters inch = one foot
 one half inch = one foot
 three eighths inch = one foot
 one quarter inch = one foot
 one eighth inch = one foot
 one sixteenth inch = one foot

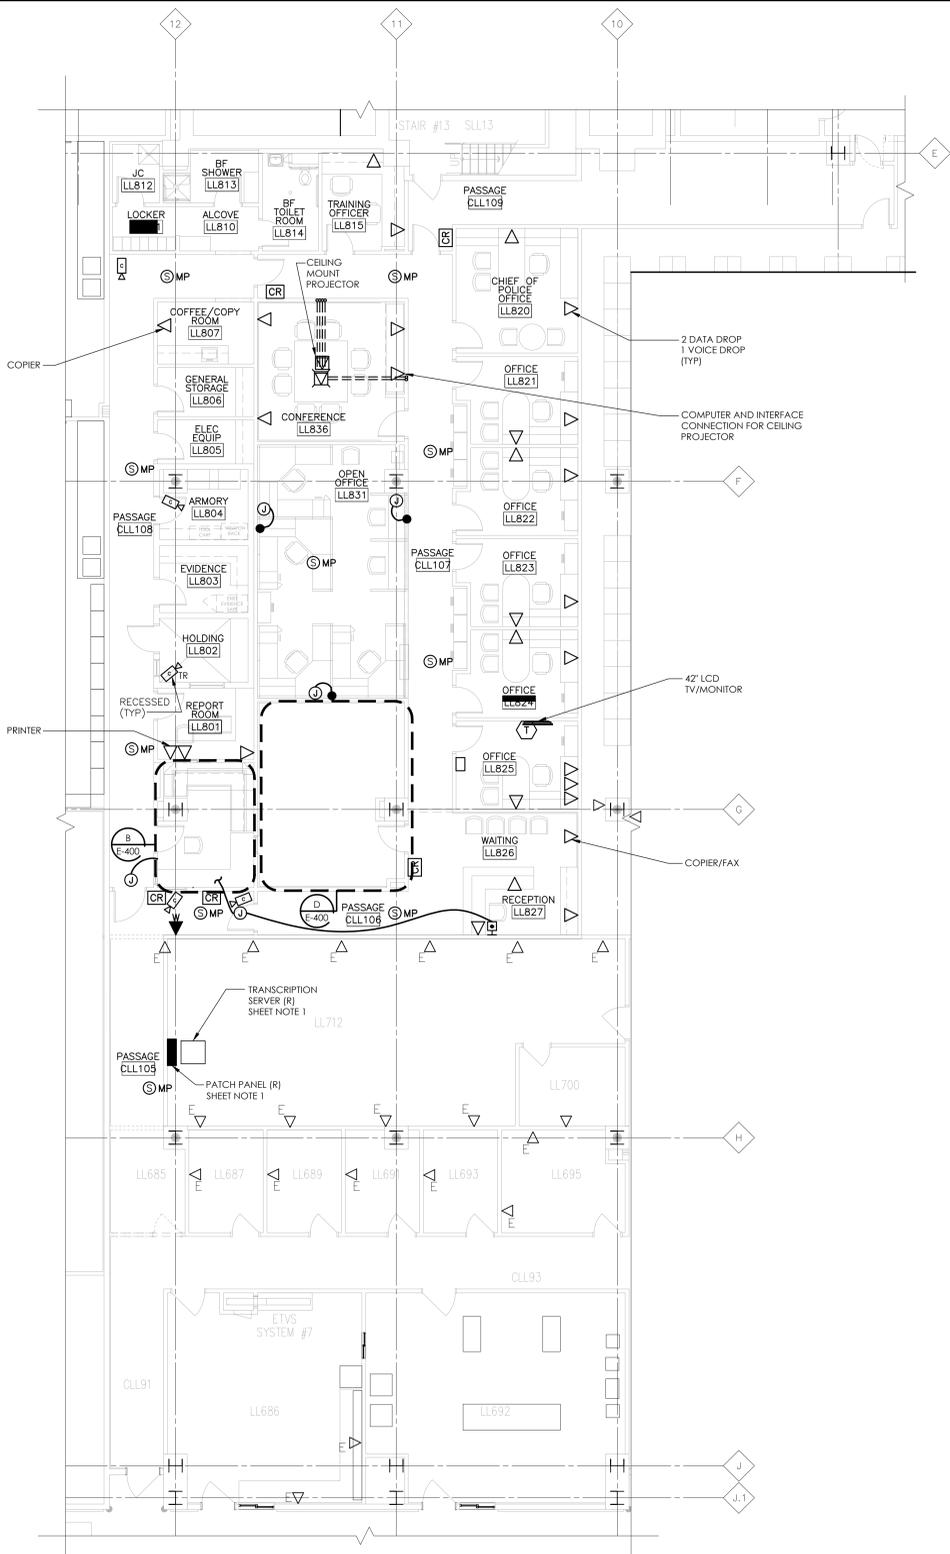

POLICE SERVICES - COMMUNICATION PLAN
 1/8" = 1'-0"

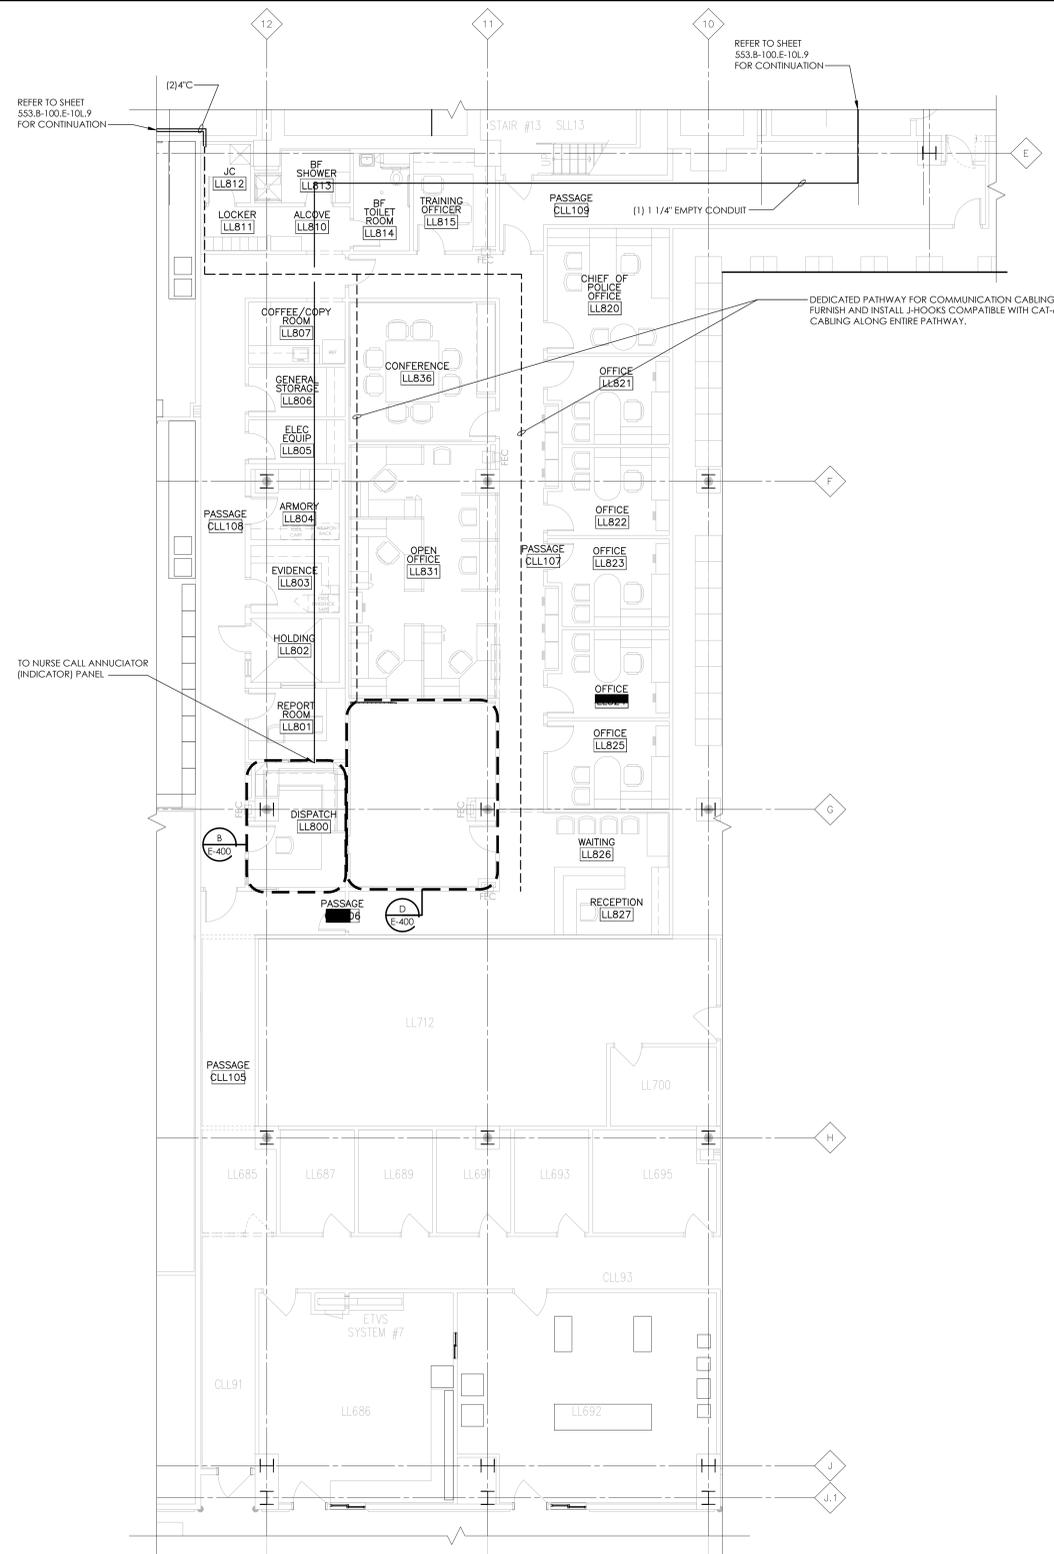

POLICE SERVICES - COMMUNICATION PLAN
 1/8" = 1'-0"


GENERAL NOTES

- REFER TO SYMBOLS AND ABBREVIATIONS LISTS ON SHEET NO. E-001.
- REFER TO MOUNTING HEIGHTS AND ELECTRICAL NOTES ON SHEET NO. E-001.
- REFER TO SPECIFICATIONS FOR ADDITIONAL ELECTRICAL REQUIREMENTS.

SHEET NOTES

- REFER TO SPECIFICATION SECTION 01 00 00 FOR CUT OVER INSTRUCTIONS FOR THE TRANSCRIPTION SERVER AND ASSOCIATED EQUIPMENT.

Revisions	Date
ISSUE 005 - CD OWNER REVIEW	12.17.10
ISSUE 004 - DESIGN DEVELOPMENT RECORD	11.12.10
ISSUE 003 - DESIGN DEVELOPMENT REVIEW	09.08.10

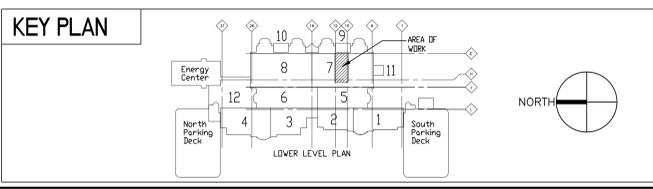

US DEPARTMENT OF VETERANS AFFAIRS
 JOHN D. DINGELL
 VA MEDICAL CENTER
 4646 JOHN R. STREET
 DETROIT, MI 48202

ARCHITECT/ENGINEERS:

Albert Kahn Associates, Inc.
 Albert Kahn Building
 7430 Second Ave.
 Detroit, Michigan 48202-2798
 Albert Kahn Associates, Inc. is a member of the Albert Kahn Family of Companies. © 2007
 ALBERT KAHN JOB # 0398-00.000

Drawing Title
ENLARGED LOWER LEVEL COMMUNICATIONS PLAN

Approved Project Director

Project Title POLICE SERVICES RELOCATION			Project Number 553-11-108
Location DETROIT, MICHIGAN			Building Number 100
Date 01-20-2011	Checked -	Drawn -	Drawing Number ET-400 Dwg. 48 of 50

FULLY SPRINKLERED

Office of Construction and Facilities Management

Department of Veterans Affairs