


 CABLE RUN LOCATION BETWEEN FLOORS

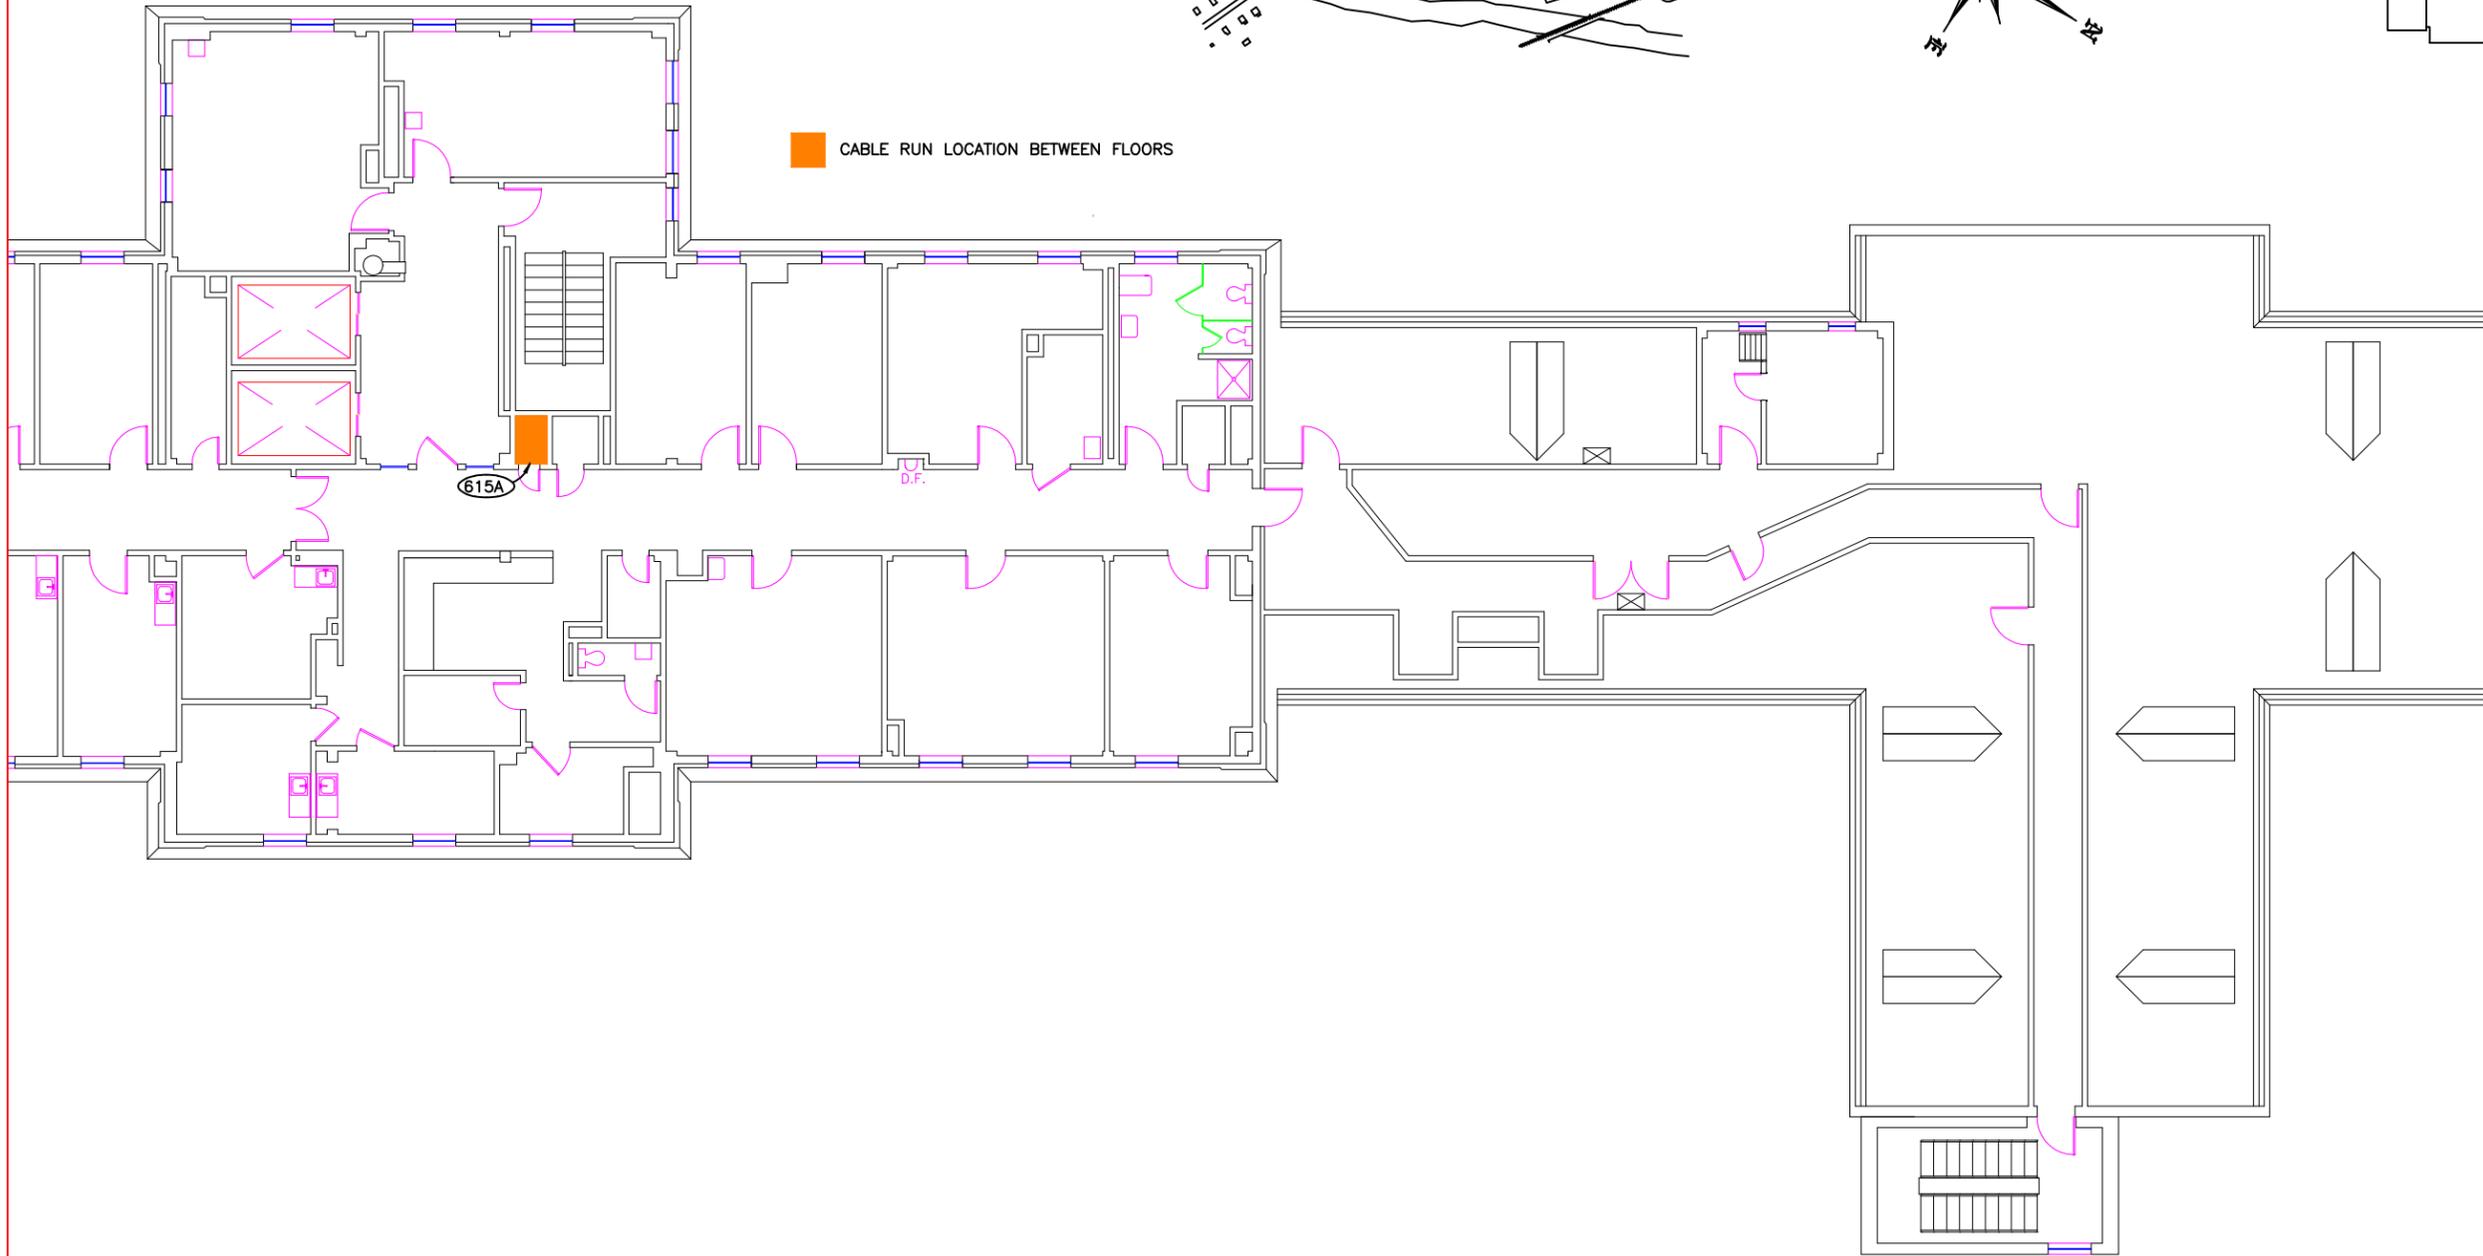

Revisions	Date

NOTE: USERS OF THESE AS-BUILT DRAWINGS ARE RESPONSIBLE FOR VERIFYING EXISTING DIMENSIONS AND CONDITIONS IN THE FIELD	Drawing Title FLOOR PLAN SIXTH FLOOR - NORTH	Project Title TV SIGNAL CONTRACT	Date 05-09-16
	Drawing File Number: 	Project No. 	Building No. 76
Approved: Project Section Manager 	Drawn SMW	Location BATH, NEW YORK	DRAWING NO.
Approved: Medical Center Director 	Dwg. 1 Of 1	V.A.	V.A.

SCALE: 1/16" = 1'