


 CABLE RUN LOCATION BETWEEN FLOORS

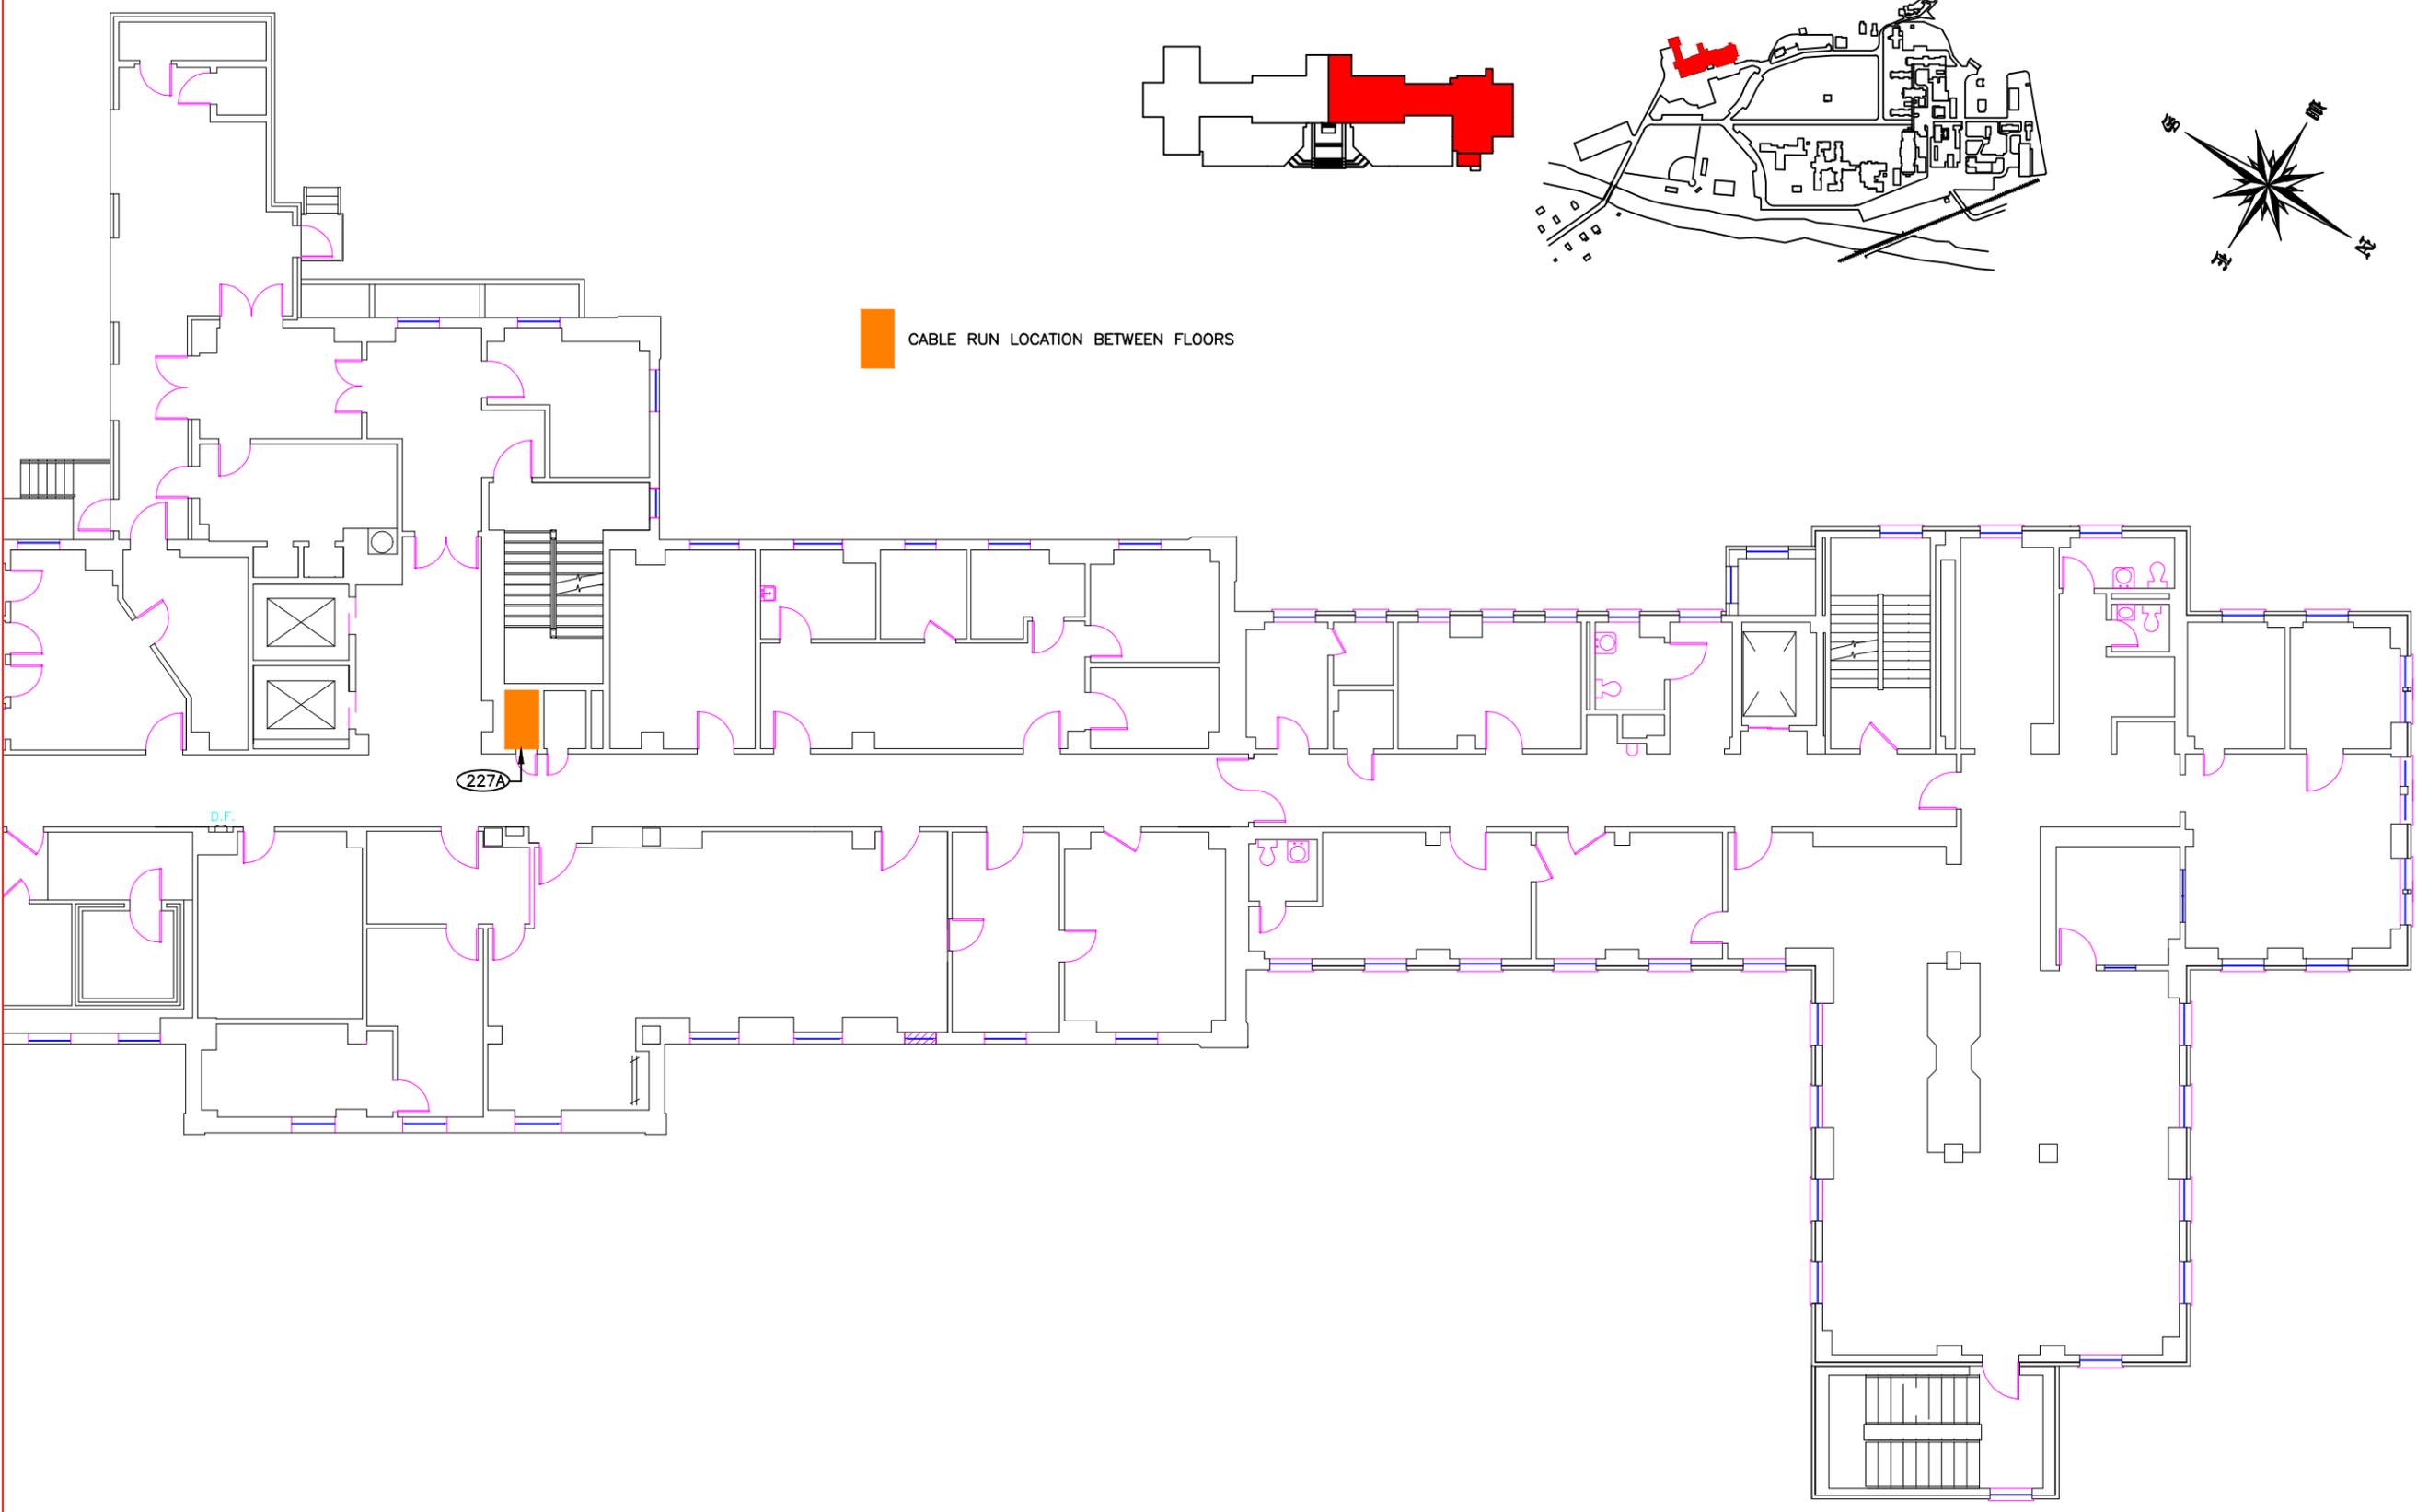

Revisions	Date

NOTE:
 USERS OF THESE AS-BUILT DRAWINGS ARE RESPONSIBLE FOR VERIFYING EXISTING DIMENSIONS AND CONDITIONS IN THE FIELD

SCALE: 1/16" = 1'

Drawing Title
**FLOOR PLAN
 SECOND FLOOR -- NORTH**

Drawing File Number:

Approved: Project Section Manager

Approved: Medical Center Director

Project Title
TV SIGNAL CONTRACT

Building No.
76

Location
BATH, NEW YORK

Checked
MH

Drawn
SMW

Date
05-09-16

Project No.

DRAWING NO.

Dwg. 1 Of 1

