



- KEYED NOTES:**
- 1 - REMOVE EXISTING LAY-IN CEILING AND GRID THIS AREA.
  - 2 - INSTALL NEW LAY-IN CEILING AND GRID AS INDICATED ONCE ALL ABOVE CEILING MODIFICATIONS HAVE BEEN MADE. NEW CEILING GRID SHALL MATCH EXISTING STYLE.
  - 3 - SEE SHEET 90R2.2 FOR LIGHTING WORK THIS AREA.
  - 4 - PATCH EXISTING CEILING THIS AREA FOR MECHANICAL AND ELECTRICAL WORK AS INDICATED ON MECHANICAL AND ELECTRICAL DRAWINGS.

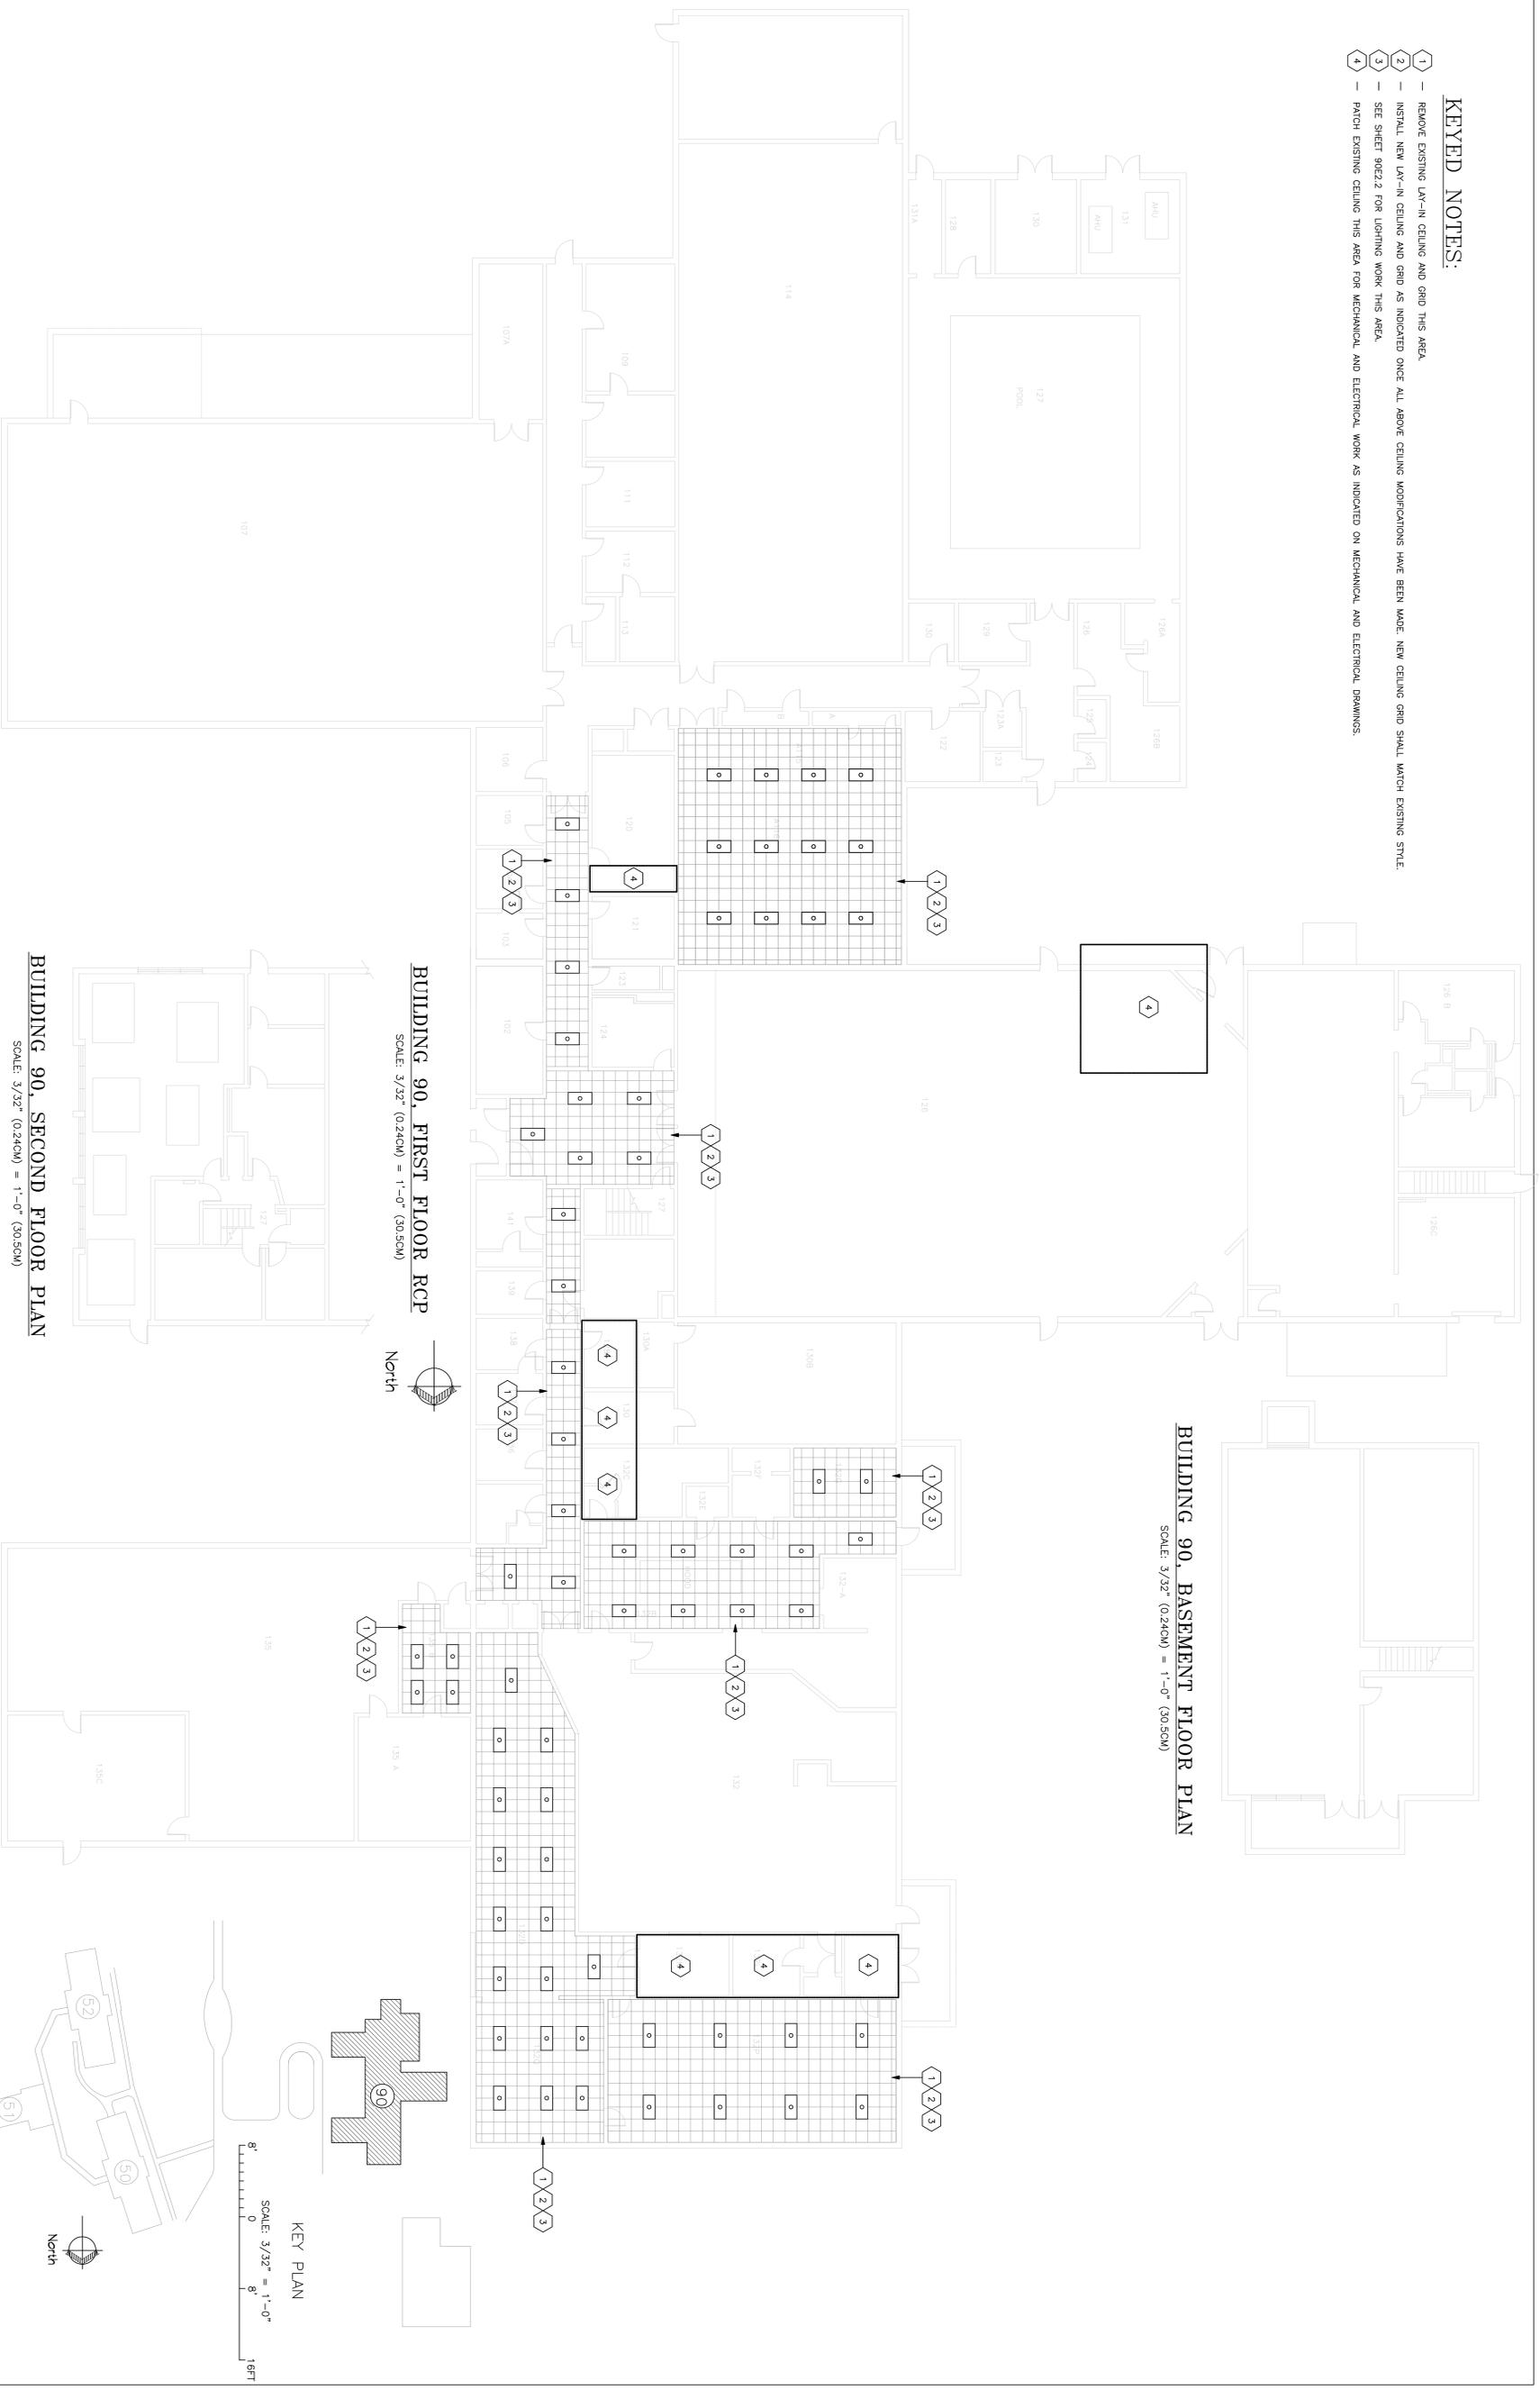

**BUILDING 90, SECOND FLOOR PLAN**  
SCALE: 3/32" (0.24CM) = 1'-0" (30.5CM)

**BUILDING 90, BASEMENT FLOOR PLAN**  
SCALE: 3/32" (0.24CM) = 1'-0" (30.5CM)

**BUILDING 90, FIRST FLOOR RCP**  
SCALE: 3/32" (0.24CM) = 1'-0" (30.5CM)

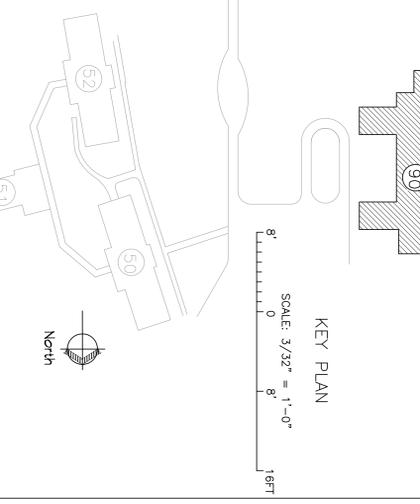

Scale	1/2" = 1'-0"
Grid	A through F

**MCE MILLS-CONOLY ENGINEERING, P.C.**  
8218 Old Federal Road  
Montgomery, AL 36117  
TELEPHONE: (334) 270-0010  
FAX: (334) 270-0040

**GVHCS**  
Central Alabama Veterans Health Care System

Author	Author
Checker	Checker
Reviewer	Reviewer
Approver	Approver

Author	Author
Checker	Checker
Reviewer	Reviewer
Approver	Approver

Project Title	BUILDING 90, FIRST FLOOR RCP
Author	Author
Checker	Checker
Reviewer	Reviewer
Approver	Approver

Project Title	HVAC MODIFICATIONS TO BUILDINGS 83, 90, & 93 TUSKEGEE, ALABAMA
Building Number	93
Location	East Campus, Tuskegee, AL
Author	Author
Checker	Checker
Reviewer	Reviewer
Approver	Approver

**Veterans Administration**  
12/21/10  
Project No. 619-10-445  
Drawing No. 90R2.1  
Date 5/7/09