


three inches = one foot
 one and one half inches = one foot
 one inch = one foot
 three quarters inch = one foot
 one half inch = one foot
 three quarters inch = one foot
 one half inch = one foot
 one quarter inch = one foot
 one eighth inch = one foot
 one quarter inch = one foot
 one eighth inch = one foot
 one eighth inch = one foot

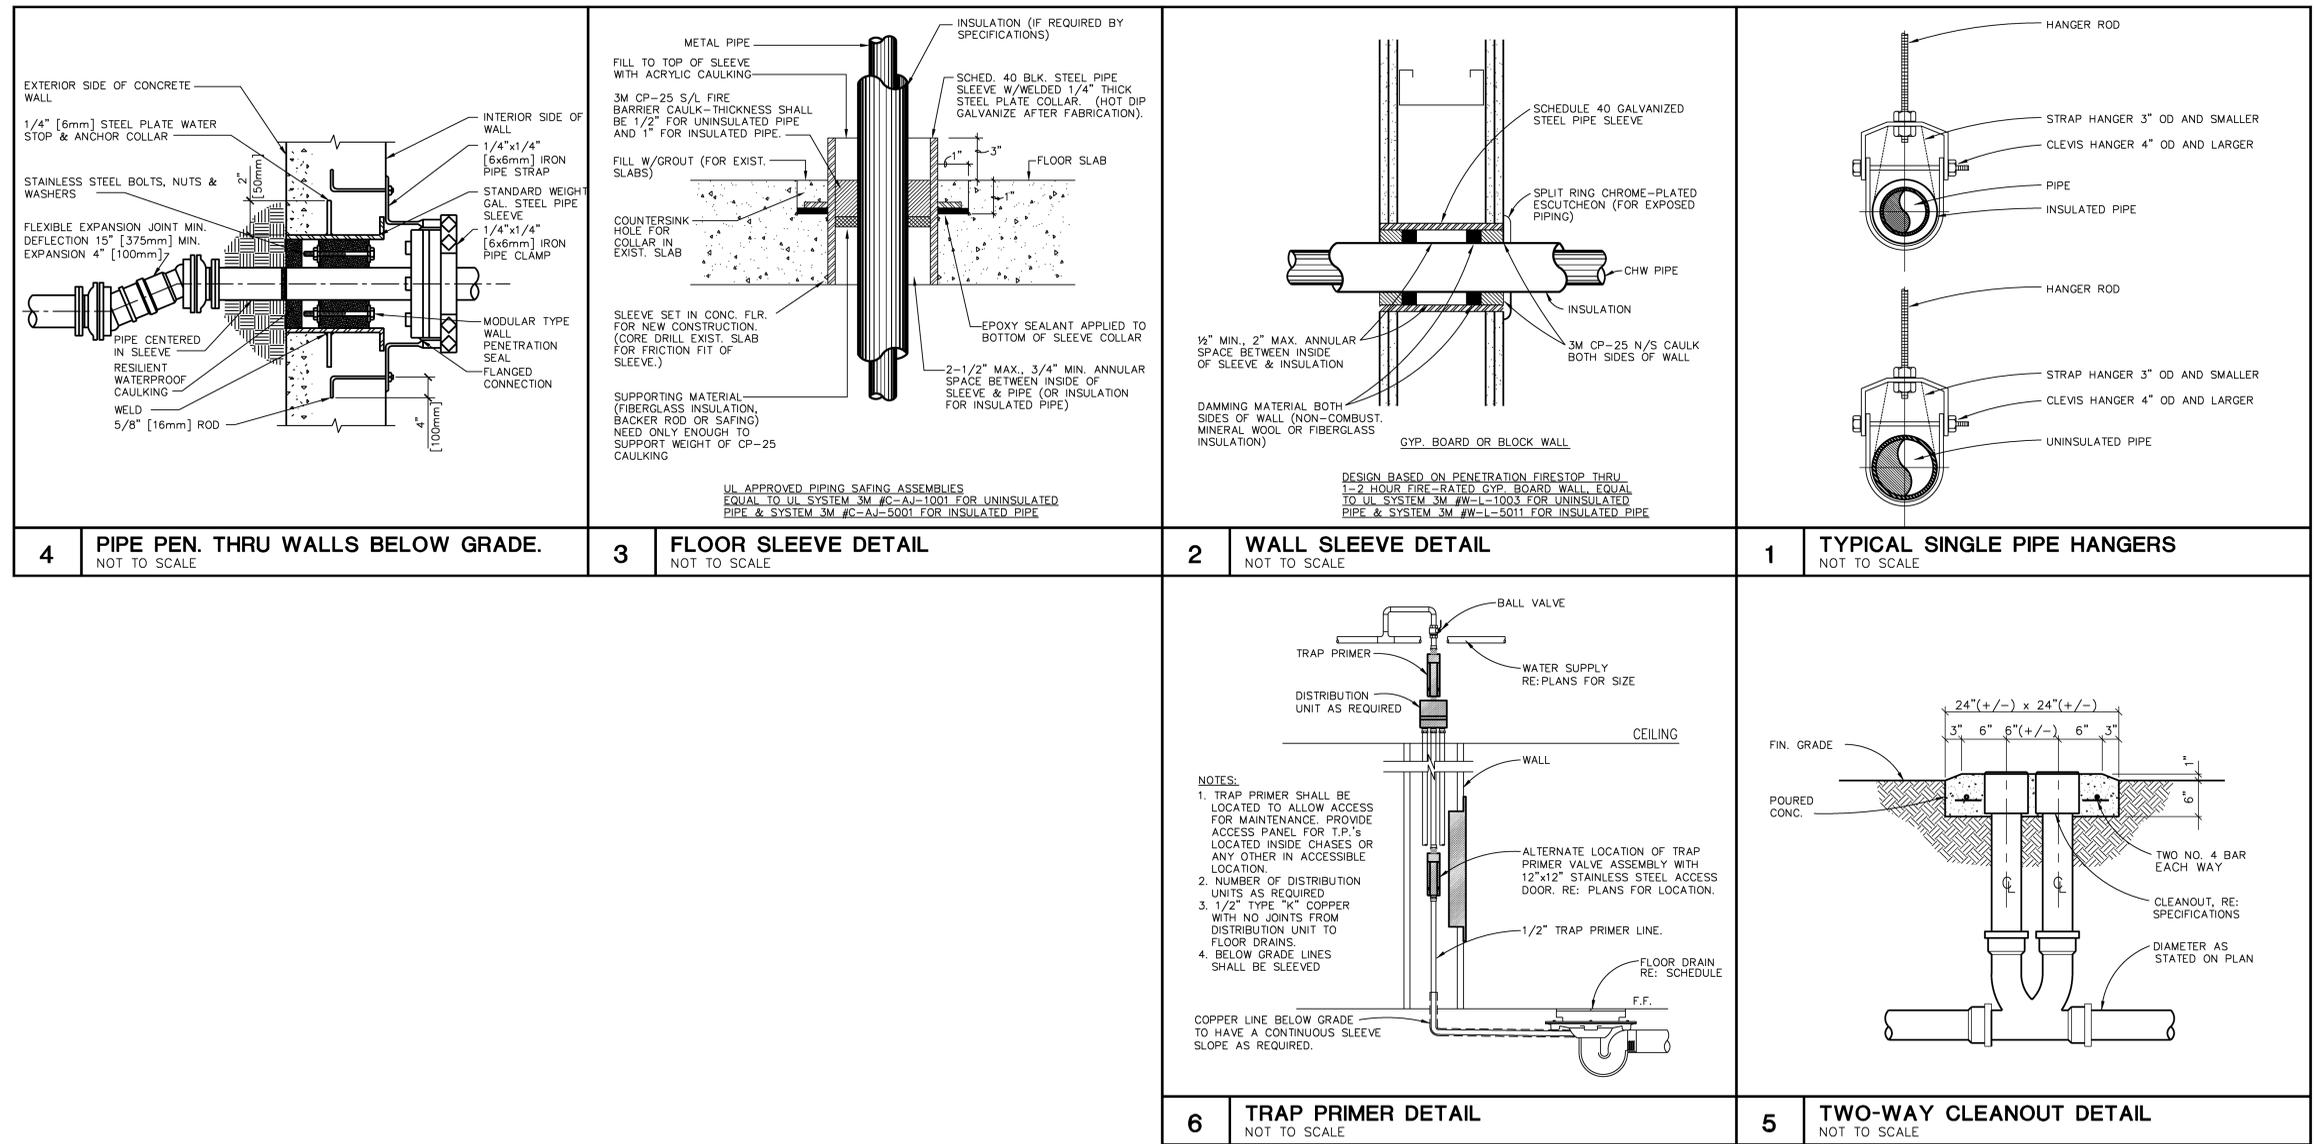

1 PLUMBING DETAILS
SCALE: N.T.S.

SCHEMATIC DESIGN SUBMISSION	08/02/10
DESIGN DEVELOPMENT SUBMISSION	09/03/10
CONSTRUCTION DOCUMENT SUBMISSION	11/22/10
ISSUE FOR BIDS	12/19/11
Revisions	Date

CONSULTANTS:

David McCoy
 J. DAVID MCCOY
 38850
 REGISTERED PROFESSIONAL ENGINEER
 12.16.2011
 Burns, DeLotte & McCoy, Inc.
 Texas Registered Engineering Firm
 F-885

ARCHITECT/ENGINEERS:

WILSON ARCHITECTURAL GROUP
 5001 WESTHEIMER SUITE 800 HOUSTON, TEXAS 77056 TELEPHONE (713) 423-8774

MEP ENGINEERS
 STRUCTURAL ENGINEERS
 FIRE PROTECTION ENGINEERS
 CIVIL ENGINEERS

BURNS DeLATTE AND MCCOY, INC.
 PINNACLE STRUCTURAL
 PROTECTION DEVELOPMENT INC.
 BREWER AND ESCALANTE

Drawing Title
PLUMBING DETAILS

Approved Project Director

Project Title
BUILDING 11 ADDITION AND INTERIOR RENOVATIONS

Project Number
 674A4-CS-516

Building Number
 11

Location
 WACO, TEXAS

Date
 19 DEC 2011

Checked
 WS

Drawn
 PJ

Drawing Number
 11

PL501

Dwg. 08 of 09

Office of Construction and Facilities Management

Department of Veterans Affairs