



ISSUE FOR BID	02/10/12
REVISIONS:	DATE

CONSULTANTS:

ARCHITECT/ENGINEERS:



1.312.448.2300
www.baileyedward.com
31 East Wacker Dr
Chicago, IL
60601-2309

62011 Bailey Edward Design
Dempy Farm, Lincoln Park, IL 60462

BE # 1115-11-01

Drawing Title
DEMO ROOF PLAN - OVERALL
BLDG 135

Approved Project Director

Project Title
**VAMC Repair / Replace Flat
Roofs - Bldgs. 134, 135, 187
and Tramway**

Location
3001 Green Bay Road, North Chicago, IL 60064

Date
02/10/2012

Checked:
MLP

Drawn:
DLW

Dwg
AD-104

2 of 23

Project Number
VA# 556-12-11

Building Number
135

Drawing Number
AD-104

**Office of
Facilities
Management**

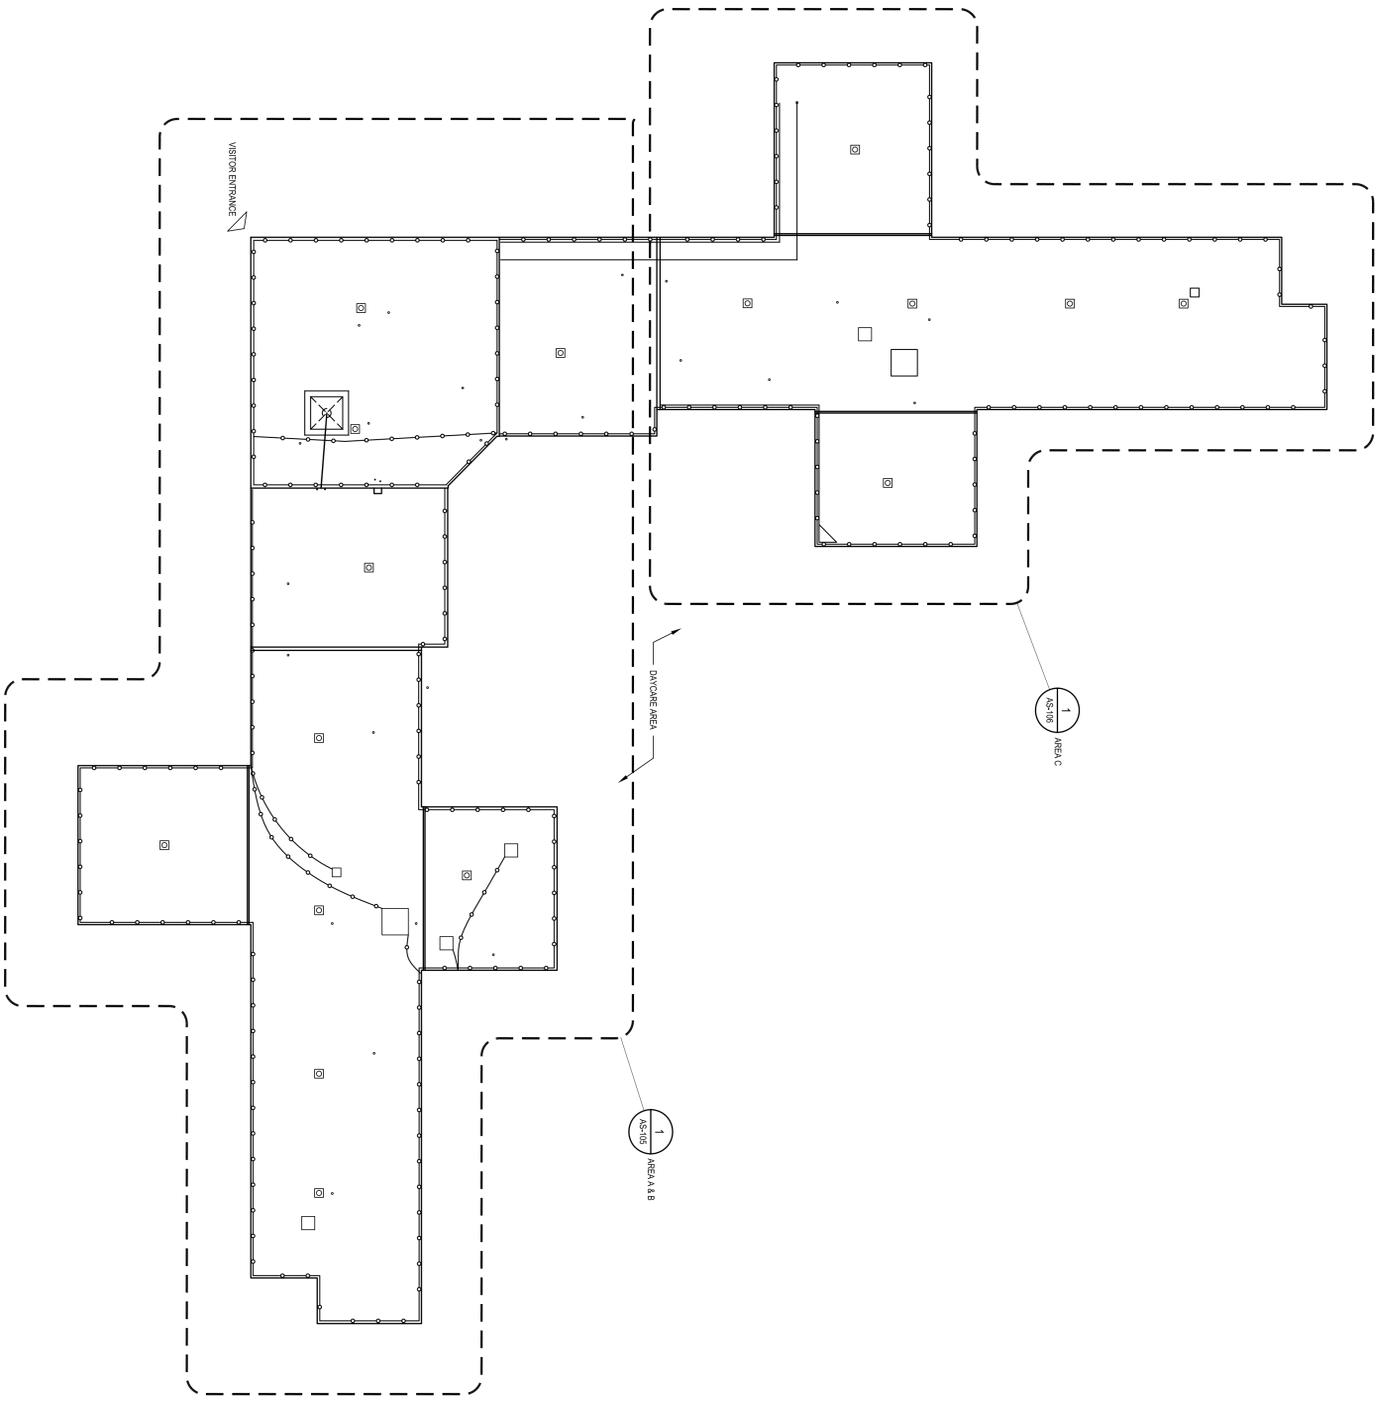
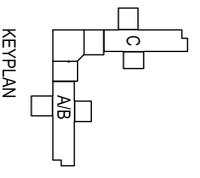
Department of
Veterans Affairs

1 DEMO ROOF PLAN - OVERALL - BLDG 135

SCALE: 1/8" = 1'-0"



0 8 16 32

NOTES:
 1. REF PLAN ONLY. SEE REFERENCED DRAWINGS FOR DETAILS AND WORK NOTES. CONTACT ARCHITECT FOR ANY QUESTIONS REGARDING WORK NEAR DOME AREA EXIST. ROOF IS CON. 3. CONTRACTOR TO GAIN ACCESS THROUGH LOADING DOCK. VERIFY W/ OWNER.