


LABORATORY TRACK SYSTEM SITE PREPARATION

FORT HARRISON, MONTANA

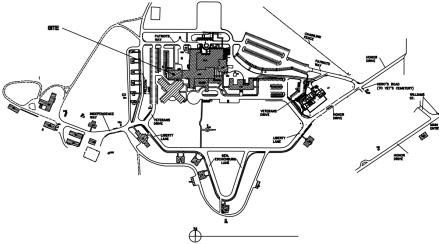


**VA MONTANA HEALTHCARE SYSTEM
FT HARRISON, MT**

SHEET INDEX	
SHEET NUMBER	DESCRIPTION
D-00	COVER SHEET
A-01	EQUIPMENT ROOM PLAN
A-02	RECEPTION LABORATORY
A-03	LABORATORY
A-04	LABORATORY
B-01	ELECTRICAL SINGLE LINE PLAN
B-02	LAB ELECTRICAL POWER PLAN
B-03	LAB ELECTRICAL PANELS
B-04	PLUMBING SANITARY AND GAS
B-05	CONSTRUCTION PLAN

APPROVED FOR CONSTRUCTION	
DATE	DATE
BY	DATE
BY	DATE

LABORATORY TRACK SYSTEM SITE PREPARATION


FORT HARRISON, MONTANA

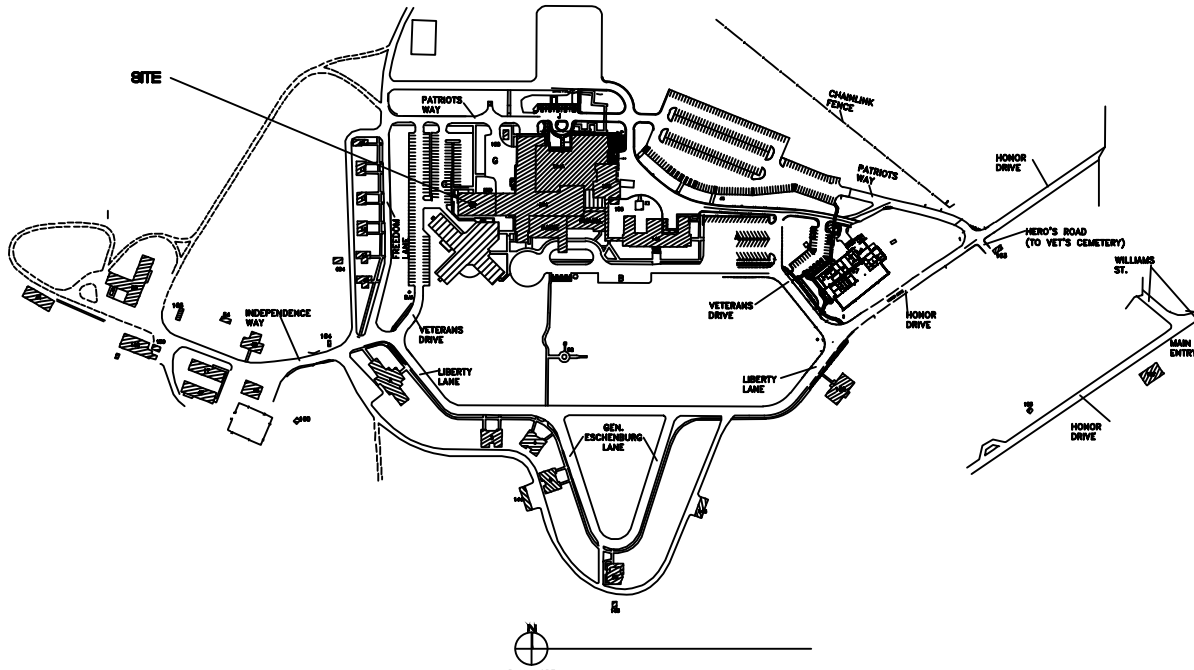

**VA MONTANA HEALTHCARE SYSTEM
FT HARRISON, MT**


SHEET INDEX	
SHEET NUMBER	DESCRIPTION
D-00	COVER SHEET
A-01	EQUIPMENT ROOM PLAN
A-02	RECEPTION LABORATORY
A-03	LABORATORY
A-04	LABORATORY
B-01	ELECTRICAL SINGLE LINE PLAN
B-02	LAB ELECTRICAL POWER PLAN
B-03	LAB ELECTRICAL PANELS
B-04	PLUMBING SANITARY AND GAS
B-05	CONSTRUCTION PLAN

APPROVED FOR CONSTRUCTION	
DATE	DATE
BY	DATE
BY	DATE

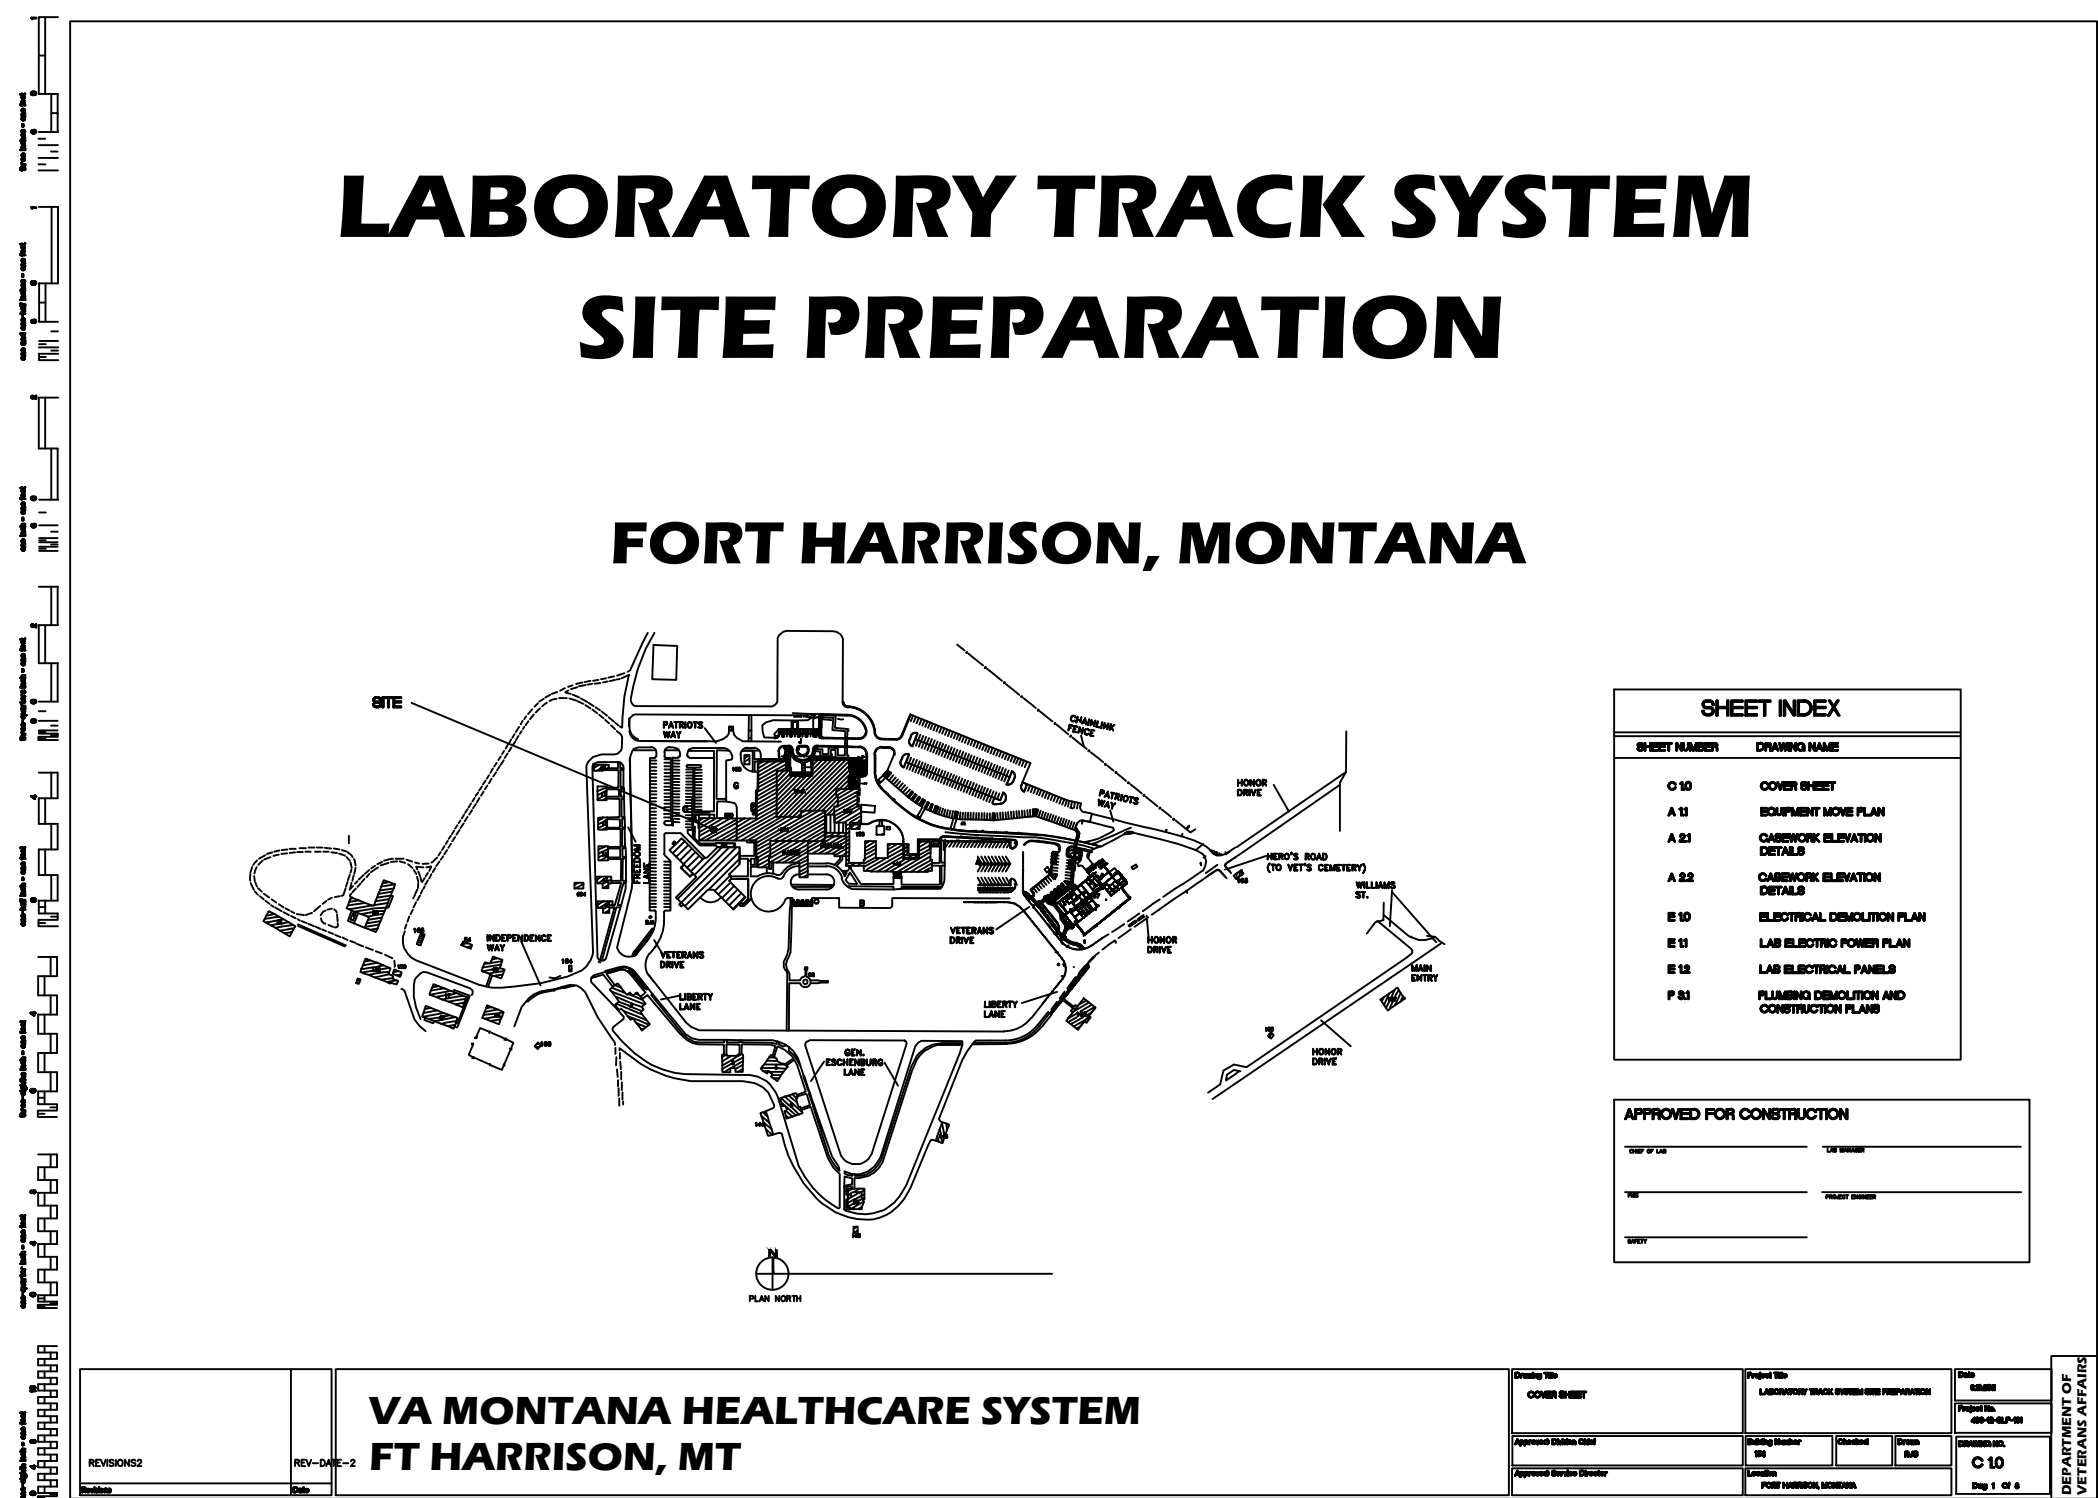

LABORATORY TRACK SYSTEM SITE PREPARATION

FORT HARRISON, MONTANA

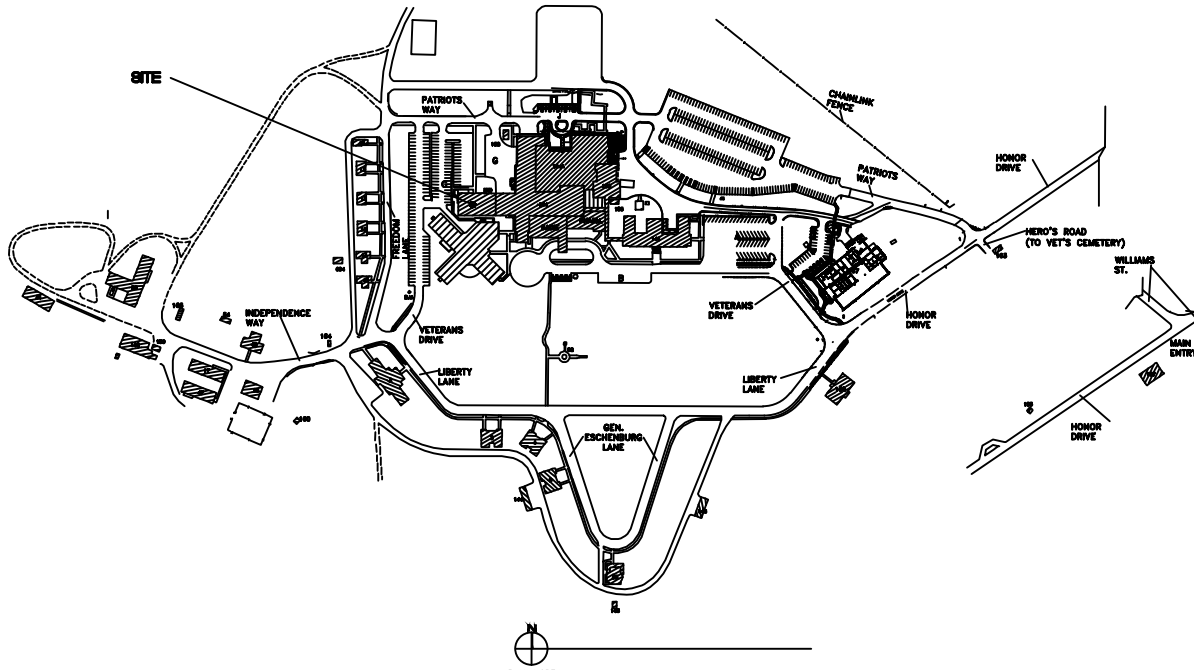


**VA MONTANA HEALTHCARE SYSTEM
FT HARRISON, MT**

SHEET INDEX	
SHEET NUMBER	DESCRIPTION
D-00	COVER SHEET
A-01	EQUIPMENT ROOM PLAN
A-02	RECEPTION LABORATORY
A-03	LABORATORY
A-04	LABORATORY
B-01	ELECTRICAL SINGLE LINE PLAN
B-02	LAB ELECTRICAL POWER PLAN
B-03	LAB ELECTRICAL PANELS
B-04	PLUMBING SANITARY AND GAS
B-05	CONSTRUCTION PLAN

APPROVED FOR CONSTRUCTION	
DATE	DATE
BY	DATE
BY	DATE

LABORATORY TRACK SYSTEM SITE PREPARATION

FORT HARRISON, MONTANA

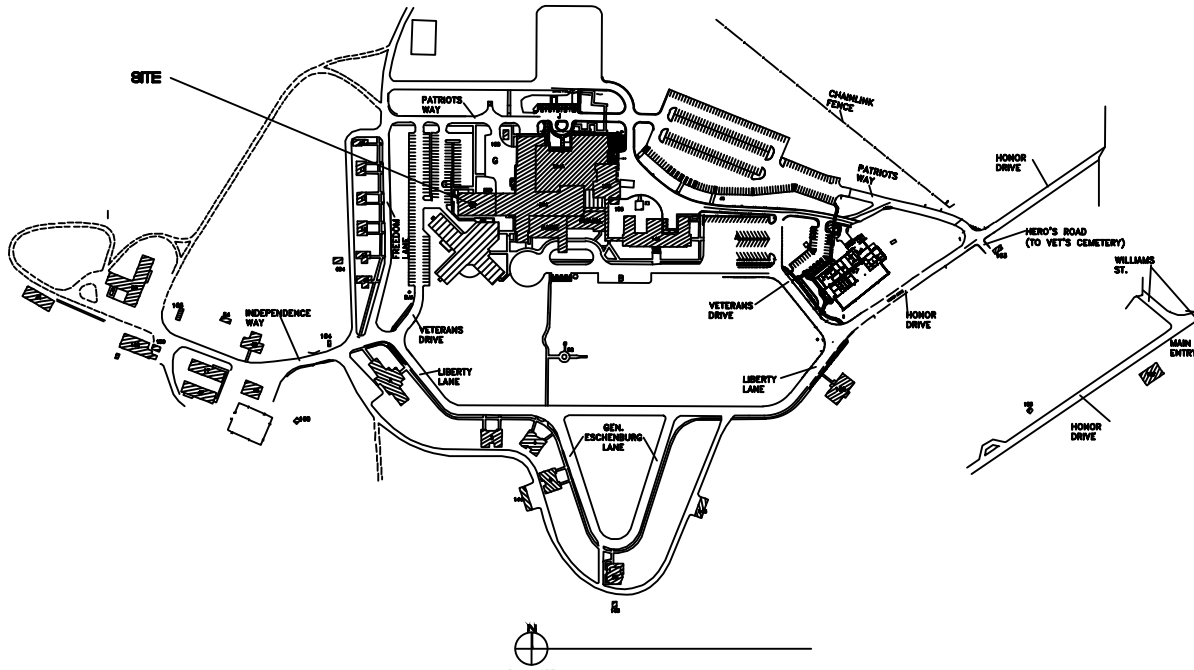


**VA MONTANA HEALTHCARE SYSTEM
FT HARRISON, MT**

SHEET INDEX	
SHEET NUMBER	DESCRIPTION
D-00	COVER SHEET
A-01	EQUIPMENT ROOM PLAN
A-02	RECEPTION LABORATORY
A-03	LABORATORY
A-04	LABORATORY
B-01	ELECTRICAL SINGLE LINE PLAN
B-02	LAB ELECTRICAL POWER PLAN
B-03	LAB ELECTRICAL PANELS
B-04	PLUMBING SANITARY AND GAS
B-05	CONSTRUCTION PLAN

APPROVED FOR CONSTRUCTION	
DATE	DATE
BY	DATE
BY	DATE

LABORATORY TRACK SYSTEM SITE PREPARATION

FORT HARRISON, MONTANA

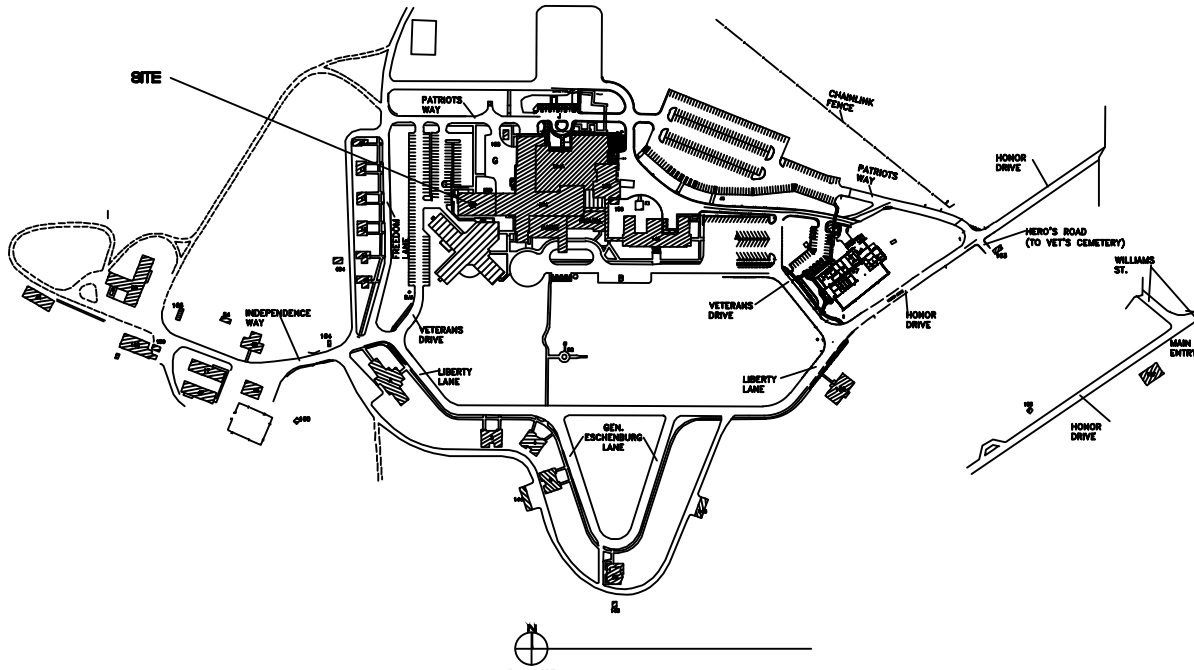


**VA MONTANA HEALTHCARE SYSTEM
FT HARRISON, MT**

SHEET INDEX	
SHEET NUMBER	DESCRIPTION
D-00	COVER SHEET
A-01	EQUIPMENT ROOM PLAN
A-02	RECEPTION LABORATORY
A-03	LABORATORY
A-04	LABORATORY
B-01	ELECTRICAL SINGLE LINE PLAN
B-02	LAB ELECTRICAL POWER PLAN
B-03	LAB ELECTRICAL PANELS
B-04	PLUMBING SANITARY AND GAS
B-05	CONSTRUCTION PLAN

APPROVED FOR CONSTRUCTION	
DATE	DATE
BY	DATE
BY	DATE

LABORATORY TRACK SYSTEM SITE PREPARATION

FORT HARRISON, MONTANA

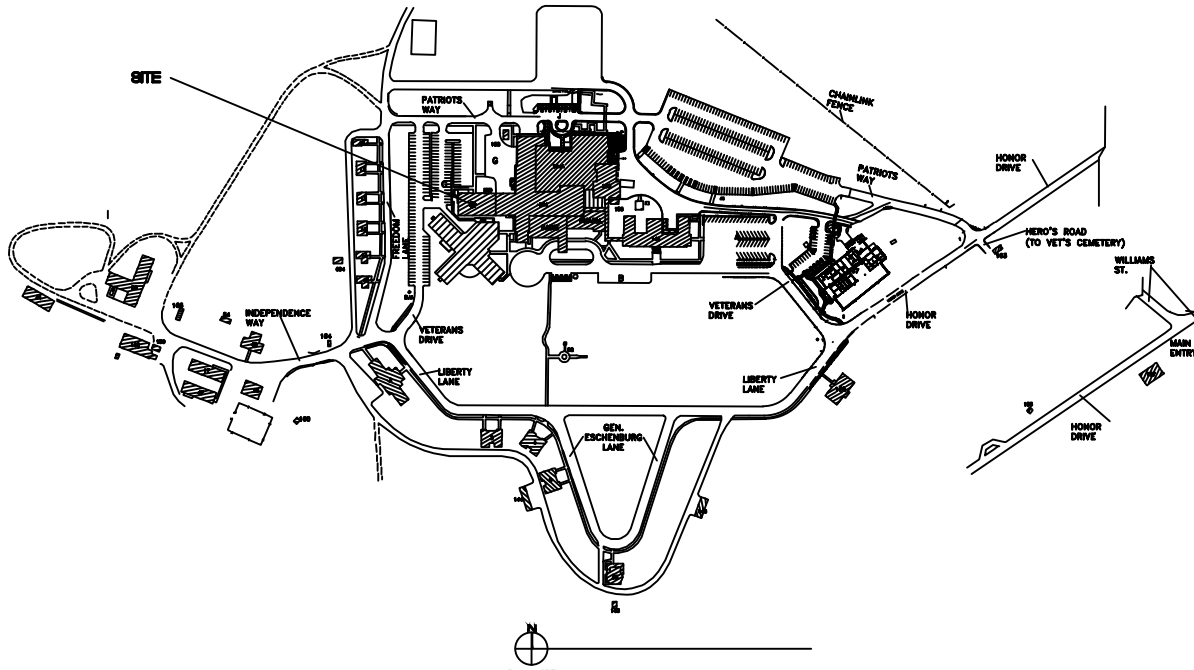

**VA MONTANA HEALTHCARE SYSTEM
FT HARRISON, MT**

SHEET INDEX	
SHEET NUMBER	DESCRIPTION
D-00	COVER SHEET
A-01	EQUIPMENT ROOM PLAN
A-02	RECEPTION LABORATORY
A-03	LABORATORY
A-04	LABORATORY
B-01	ELECTRICAL SINGLE LINE PLAN
B-02	LAB ELECTRICAL POWER PLAN
B-03	LAB ELECTRICAL PANELS
B-04	PLUMBING SANITARY AND GAS
B-05	CONSTRUCTION PLAN

APPROVED FOR CONSTRUCTION	
DATE	DATE
BY	DATE
BY	DATE