
 


three inches = one foot
 one and one-half inches = one foot
 one inch = one foot
 three-quarters inch = one foot
 one-half inch = one foot
 three-eighths inch = one foot
 one-quarter inch = one foot
 one-eighth inch = one foot

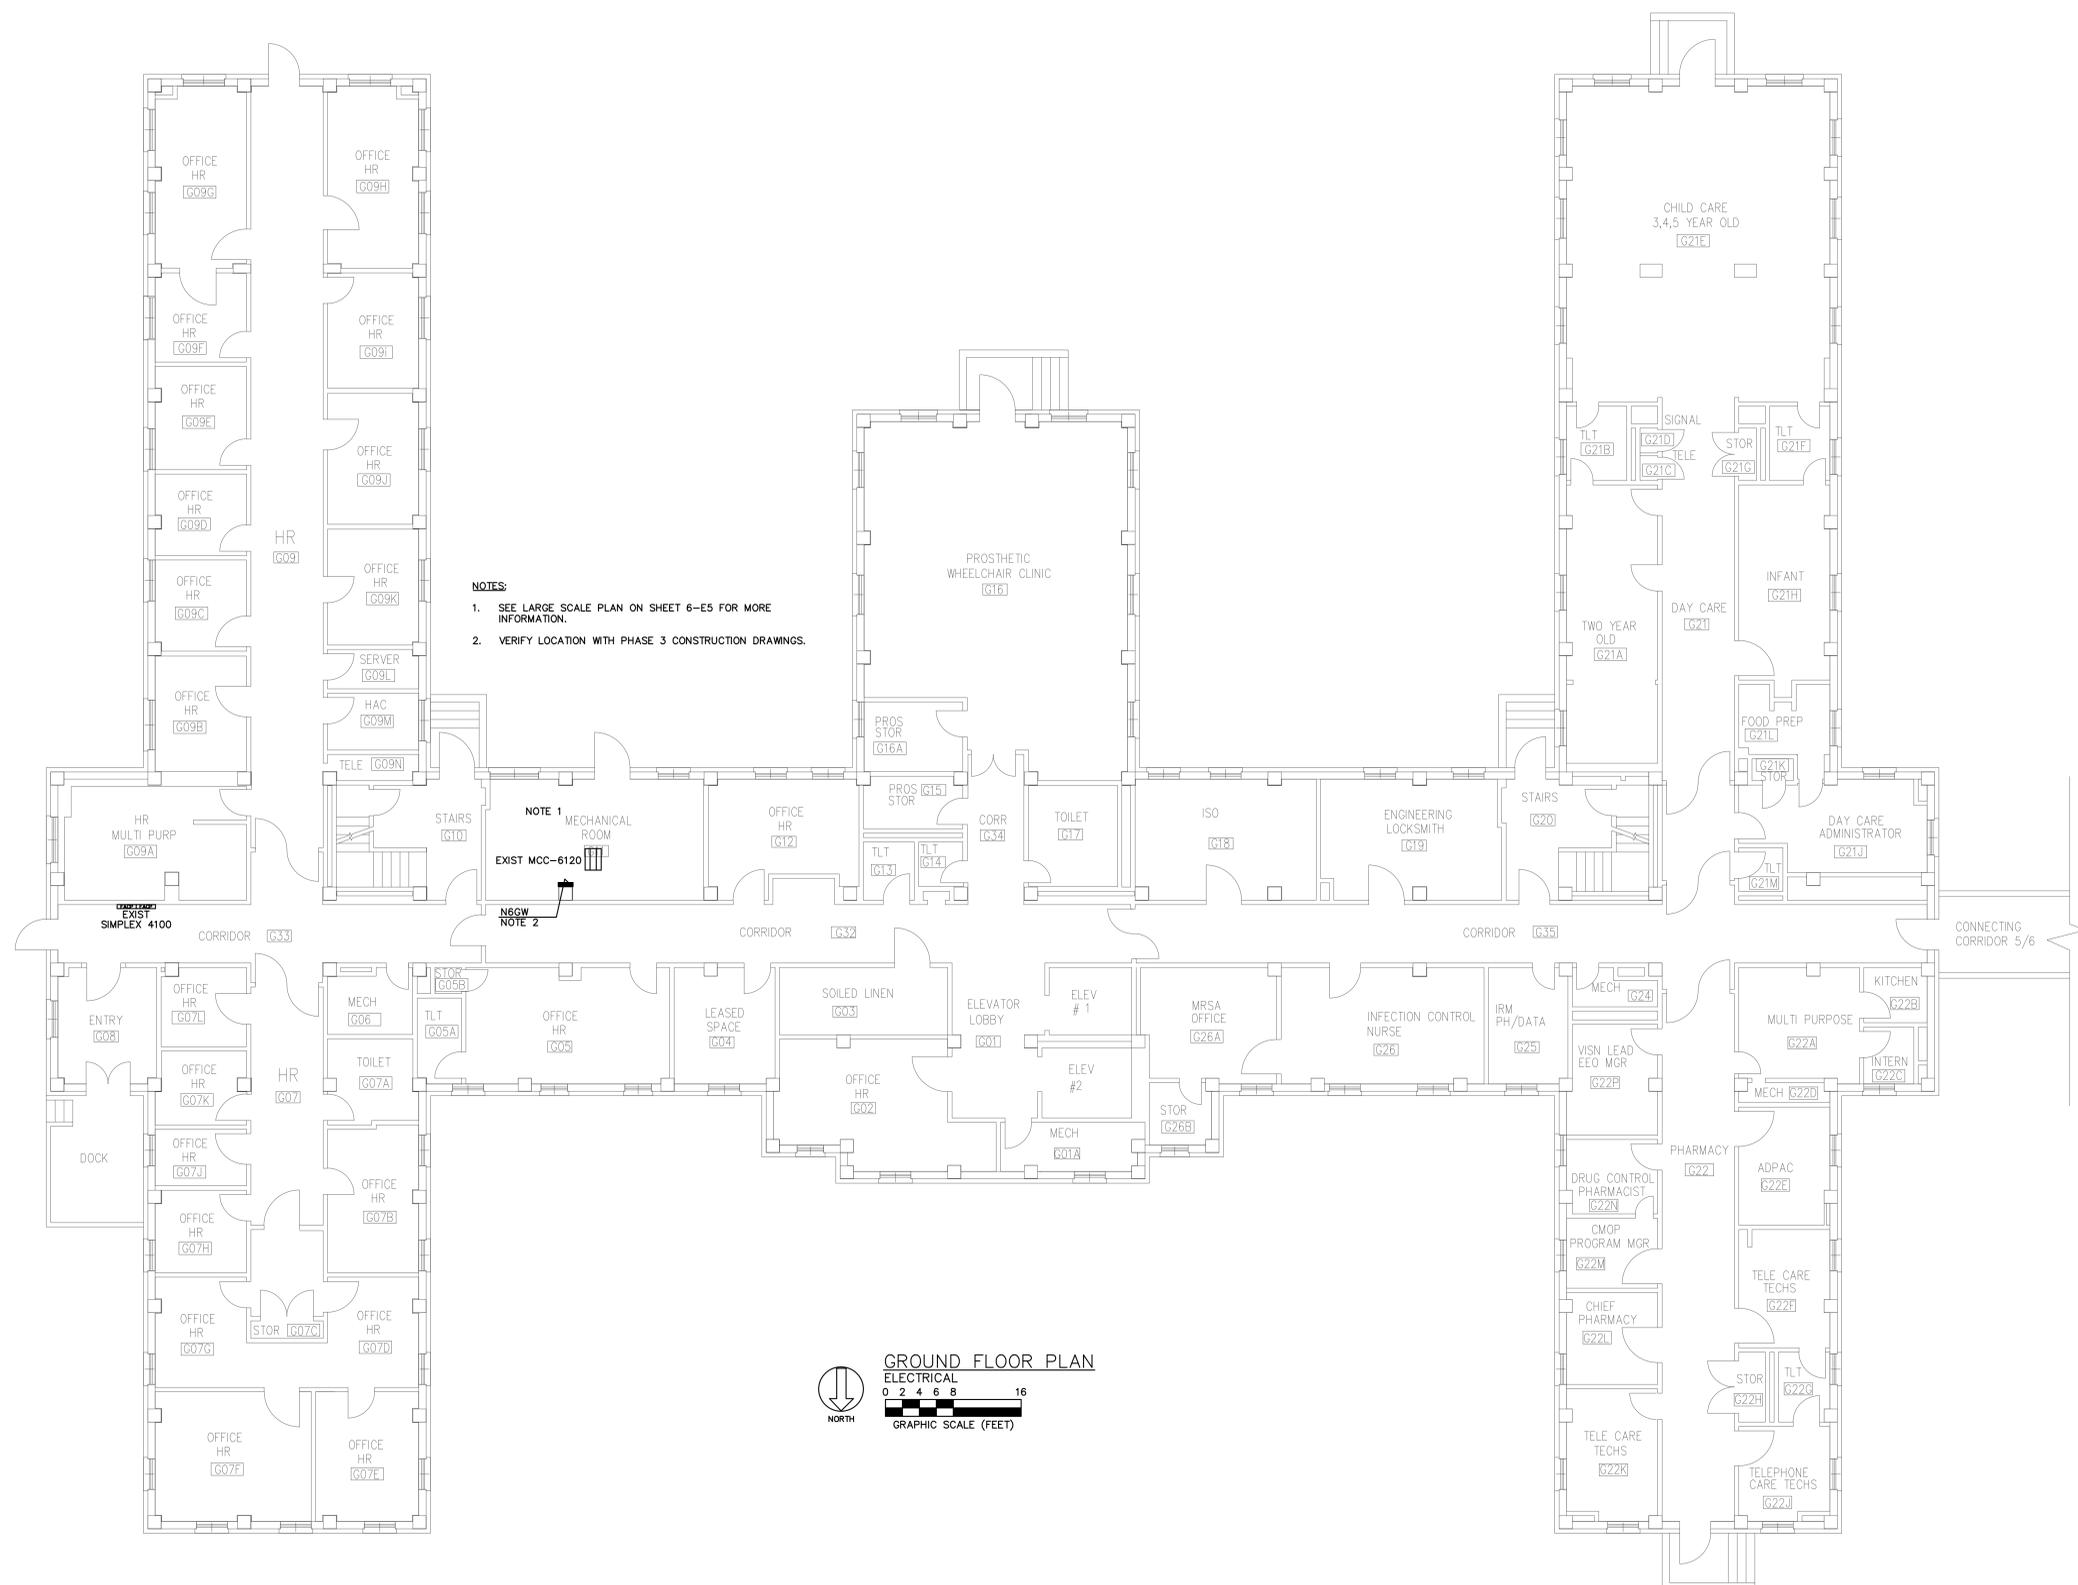

NOTES:
 1. SEE LARGE SCALE PLAN ON SHEET 6-E5 FOR MORE INFORMATION.
 2. VERIFY LOCATION WITH PHASE 3 CONSTRUCTION DRAWINGS.

NOTE 1
 MECHANICAL ROOM
 EXIST MCC-6120
NOTE 2
 NEW



CONSTRUCTION DOCUMENTS

REV. A -- ADDENDUM #1 Date: 3/21/12	 <p style="text-align: center;">Tennessee Valley Healthcare System</p> 	 <p> Approved: -- Approved: -- </p>	Drawing Title GROUND FLOOR PLAN- ELECTRICAL Approved: Facility Manager Approved: Director	Project Title REPLACE ATTIC AHU'S- BLDG 6 Building Number: 6 Location: VAMC - MURFREESBORO	Date: 03/21/2012 Project No.: 626A4-11-204 Drawing No.: 6-E4 File Name: --
--	---	---	---	---	--

Veterans Administration