


three inches = one foot
 one and one half inches = one foot
 one inch = one foot
 three quarters inch = one foot
 one half inch = one foot
 three eighths inch = one foot
 one quarter inch = one foot
 one eighth inch = one foot
 one eighth inch = one foot

1 ROOF PLAN-POWER
SCALE: 1/8" = 1'-0"

BLD: 11

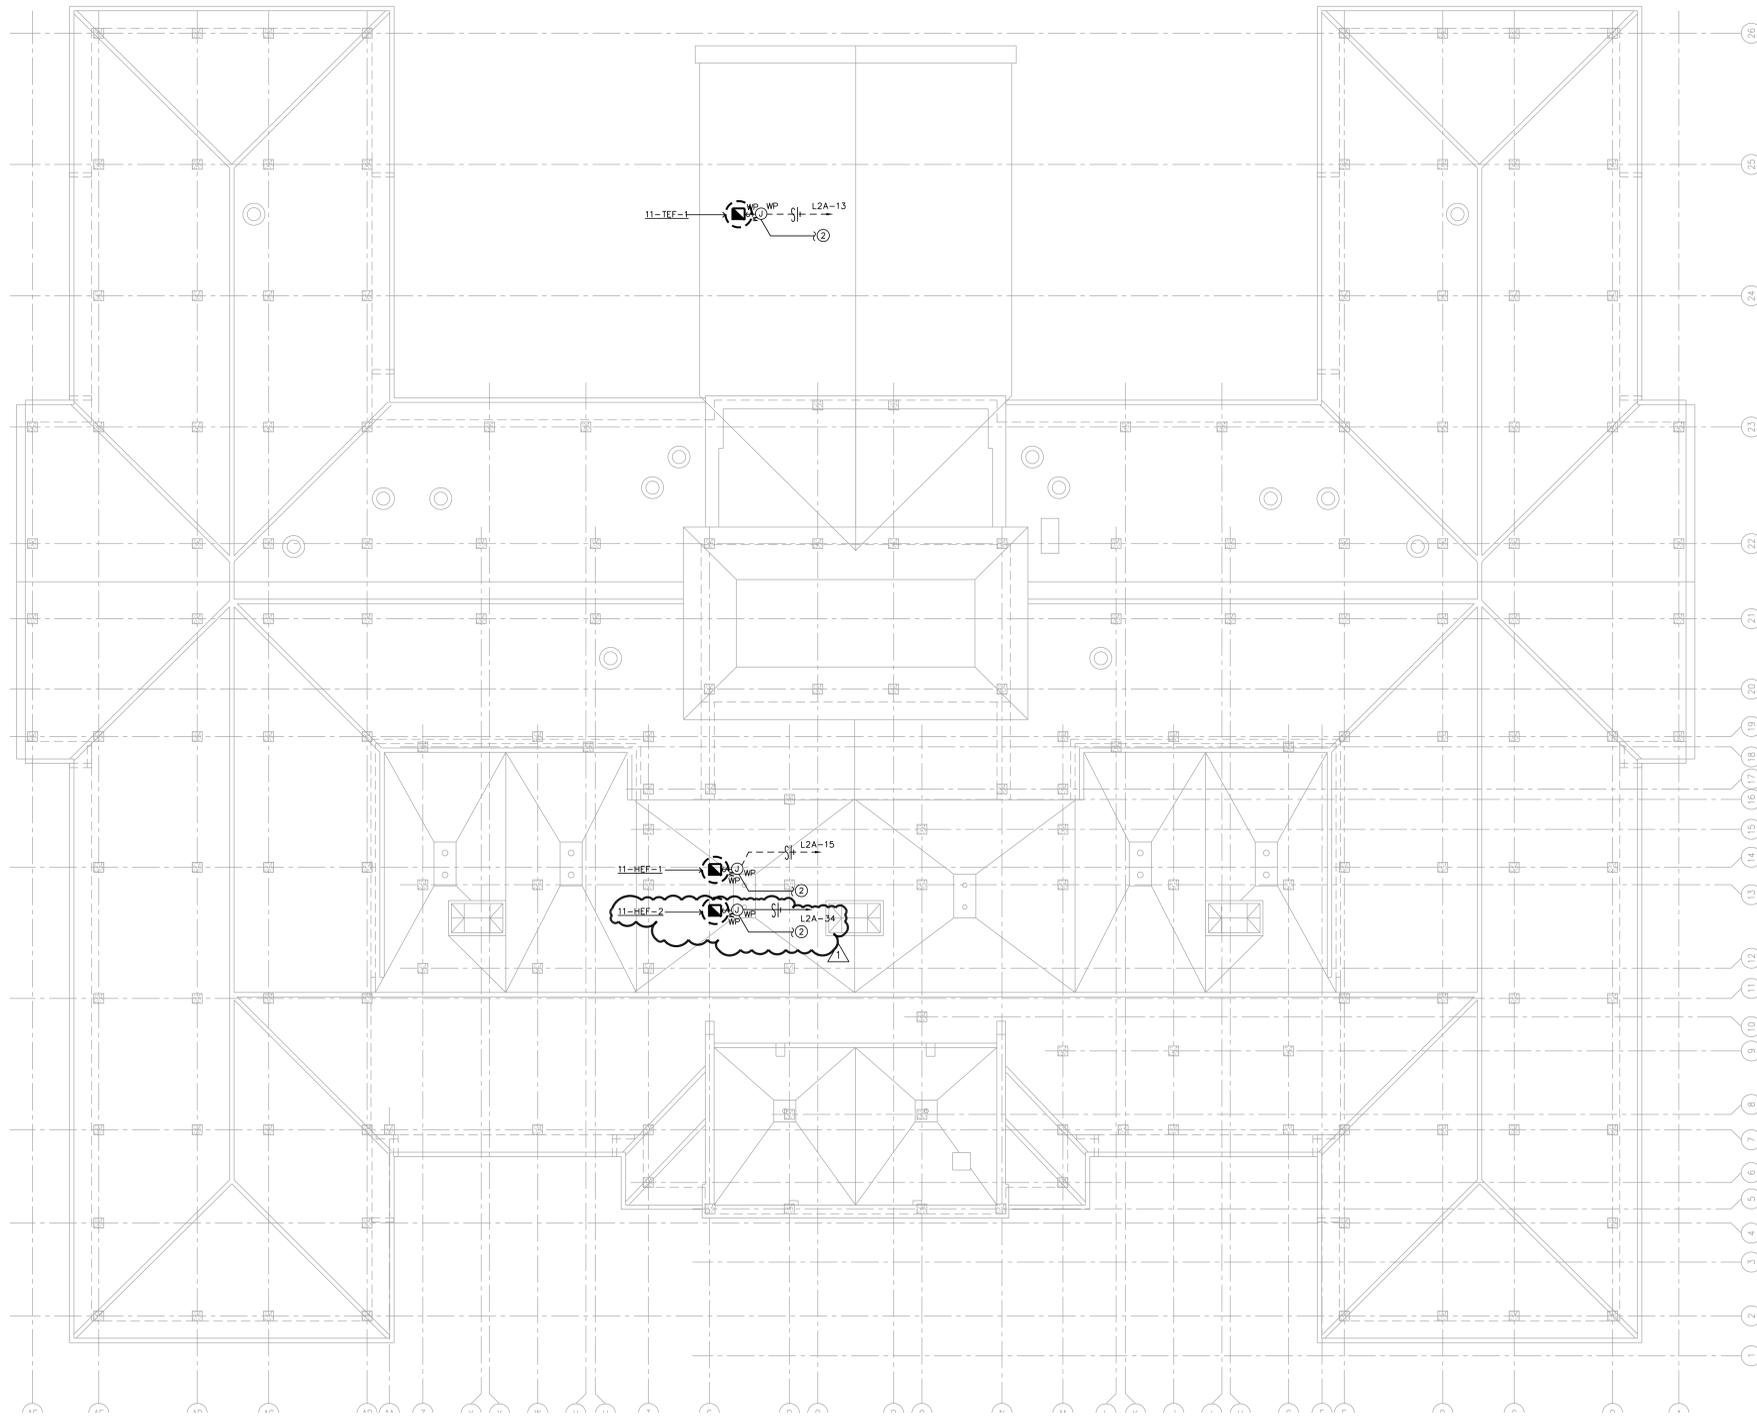

GENERAL NOTES

- 1. COORDINATE ALL NEW WORK WITH EXISTING CONDITIONS.

KEYED NOTES

- ① THIS CONTRACTOR SHALL EXTEND EXISTING LIGHTNING PROTECTION SYSTEM TO NEW ROOF.
- ② PROVIDE CONTROL WIRE AND CONDUIT TO LOCATE SWITCH BY THE HOOD.

SCHEMATIC DESIGN SUBMISSION	08/02/10
DESIGN DEVELOPMENT SUBMISSION	09/03/10
CONSTRUCTION DOCUMENT SUBMISSION	11/22/10
ISSUE FOR BIDS	12/19/11
ADDENDUM No 04	04/05/12
Revisions	Date

CONSULTANTS:



ARCHITECT/ENGINEERS:
WILSON ARCHITECTURAL GROUP
 5051 WESTHEMER SUITE 800 HOUSTON, TEXAS 77058 TELEPHONE (713) 621-8774
 MEP ENGINEERS
 STRUCTURAL ENGINEERS
 FIRE PROTECTION ENGINEERS
 CIVIL ENGINEERS

Drawing Title
ROOF PLAN ELECTRICAL
 SCALE: 1/8" = 1'-0"
 Approved Project Director

Project Title
BUILDING 11 ADDITION AND INTERIOR RENOVATIONS

Project Number
 674A4-CSI-516

Building Number
 11

Location
 WACO, TEXAS

Date
 19 DEC 2011

Checked
 FP

Drawn
 JL

Drawing Number
 11

ES103R
 Dwg. of

Office of Construction and Facilities Management
 Department of Veterans Affairs