



three inches = one foot
 one and one half inches = one foot
 one inch = one foot
 three quarters inch = one foot
 one half inch = one foot
 three quarters inch = one foot
 one half inch = one foot
 three eighths inch = one foot
 one quarter inch = one foot
 one eighth inch = one foot
 one eighth inch = one foot

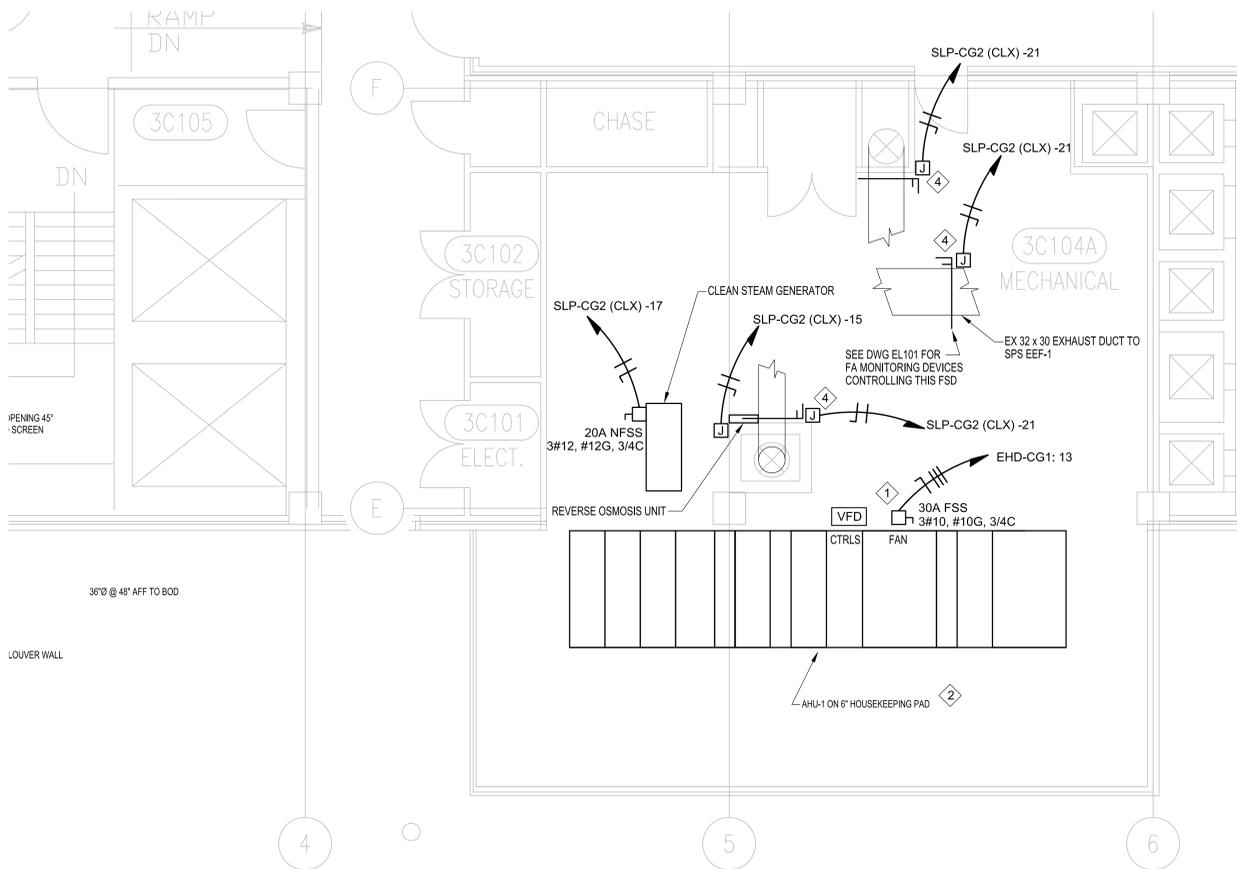

E1 THIRD LEVEL EQUIPMENT ROOM POWER & FIRE ALARM PART PLAN - NEW WORK
 1/4" = 1'-0"

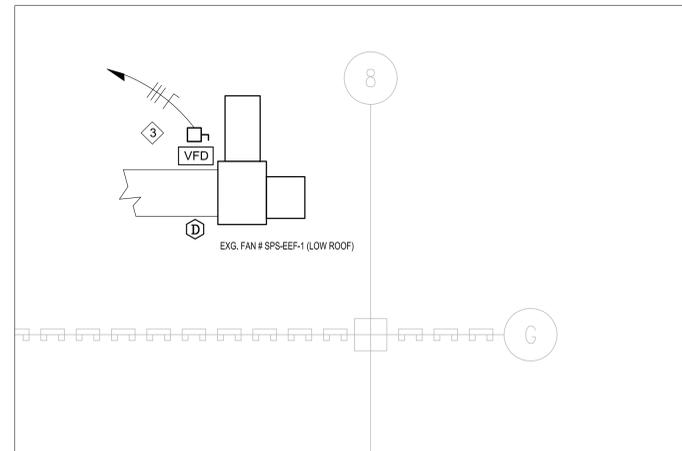

E2 THIRD LEVEL LOW ROOF POWER & FIRE ALARM PART PLAN - NEW WORK
 1/4" = 1'-0"

GENERAL NOTES:

- REFER TO DRAWING E601 FOR CONDUIT SIZES, WIRING SIZES, AND PANEL SCHEDULES.
- ALL CONDUIT RUNS ARE DIAGRAMATIC. CONTRACTOR SHALL VERIFY CONDUIT ROUTE IN FIELD.

SHEET NOTES:

- UNIT IS PROVIDED WITH FACTORY MOUNTED VFD/DISCONNECT WITH INTEGRAL CIRCUIT BREAKER. PROVIDE CIRCUITING TO POWER SOURCE AS NOTED.
- COORDINATE WITH HVAC CONTRACTOR FOR TEMPORARY RELOCATION OF OVERHEAD LIGHTING DURING EQUIPMENT INSTALLATION.
- REPLACE EXISTING STARTER AND DISCONNECT WITH NEW COMBINATION VFD/DISCONNECT FOR EXISTING 7.5 HP MOTOR.
- FIRE AND SMOKE DAMPER LOCATION.

LEGEND:

100% ISSUED FOR CONSTRUCTION
 COMPLETION ITEM NO. 3
 FULLY SPRINKLERED

Revisions	Date



Dept. of Veterans Affairs
 Medical Center
 1670 Clairmont Road
 Decatur, Georgia 30033

Professional Seal



ARCHITECT/ENGINEERS:

Smith Carter
 VETERAN ENGINEERING GROUP, INC.
 4411 Suwanee Dam, Ste. 230, Suwanee, GA 30024
 ARCHITECTURE ENGINEERING PLANNING
 1123 Zonolite Road, Suite 25, Atlanta, GA 30306

Drawing Title
 THIRD FLOOR PART PLAN
 NEW POWER AND FIRE ALARM WORK

Approved Project Director

Project Title
 RENOVATION OF EXISTING
 STERILE PROCESSING SERVICE (SPS)

Location
 VAMC, DECATUR, GA.

Date
 FEBRUARY 24, 2012

Checked
 RL

Drawn
 CM

Project Number
 508-10-113

Building Number
 1

Drawing Number
 EP102

Dwg. 25 of 27

Office of
 Facilities
 Management

