


three inches = one foot
 one and one half inches = one foot
 one inch = one foot
 one inch = one foot
 three quarters inch = one foot
 one half inch = one foot
 one half inch = one foot
 three eighths inch = one foot
 one quarter inch = one foot
 one eighth inch = one foot
 one eighth inch = one foot

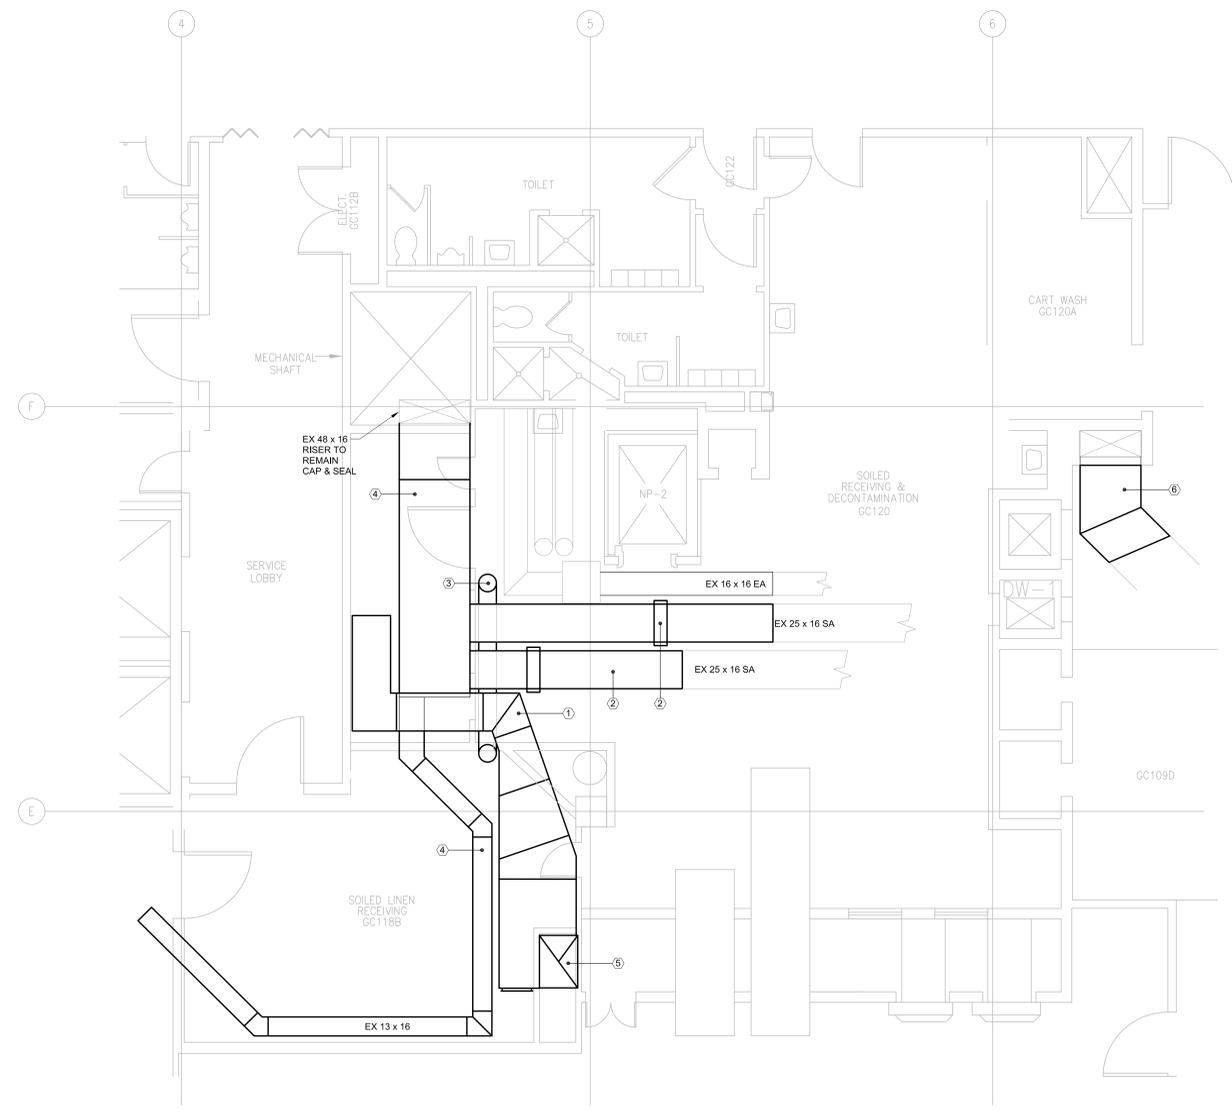

DEMOLITION NOTES:

1. REMOVE OBSOLETE RETURN DUCT.
2. REMOVE EXISTING SUPPLY AIR DUCT WITH STEAM COIL TO POINT BEYOND EXTENT OF NEW SCOPE CLEANING ROOM. REMOVE STEAM AND CONDENSATE LINES BACK TO SOURCE.
3. REMOVE OBSOLETE 12"Ø EXHAUST LINE BACK TO SOURCE.
4. REMOVE EXISTING SUPPLY DUCTWORK.
5. REMOVE EXISTING 26x36 EX RISER DOWN TO BSMT.
6. REMOVE SECTION OF SUPPLY DUCT TO FIT AND CONNECT NEW VAV BOXES.

E1 PART GROUND FLOOR PLAN - DEMOLITION
 1/4" = 1'-0"

GENERAL NOTES:


SHEET NOTES:

LEGEND:

100% ISSUED FOR CONSTRUCTION
 COMPLETION ITEM NO. 3
 FULLY SPRINKLERED

Revisions	Date

Dept. of Veterans Affairs
Medical Center
 1670 Clairmont Road
 Decatur, Georgia 30033

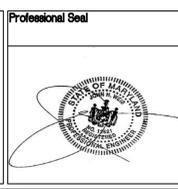

ARCHITECT/ENGINEERS:

VEG VETERAN ENGINEERING GROUP, INC.
 4411 Suwanee Dam, Ste. 230, Suwanee, GA 30024

Smith Carter ARCHITECTURE ENGINEERING PLANNING
 1123 Zonolite Road, Suite 25, Atlanta, GA 30306

Drawing Title
 PART GROUND FLOOR PLAN - HVAC DEMOLITION WORK

Approved Project Director

Project Title
 RENOVATION OF EXISTING STERILE PROCESSING SERVICE (SPS)

Project Number
 508-10-113

Building Number
 1

Location
 VAMC, DECATUR, GA.

Date
 FEBRUARY 24, 2012

Checked
 WK

Drawn
 JW

Drawing Number
 MD101

Dwg 13 of 27

Office of Facilities Management

Department of Veterans Affairs