


Revisions:	Date

© 2012 Calvin L. Hinz Architects P.C.  
 These plans are specifically prepared for the project indicated and are intended for use only for the project indicated. Any use of these plans for any other project without the written permission of Calvin L. Hinz Architects is prohibited.

**FARIS ENGINEERING**  
 CIVIL, MECHANICAL, ELECTRICAL, PLUMBING, AND CONSTRUCTION SERVICES  
 122017  
 This document and the information contained hereon are the property of Faris Engineering, Inc. and are not to be used, copied, or reproduced in any way without the written permission of Faris Engineering, Inc. Unauthorized use or reproduction is prohibited.

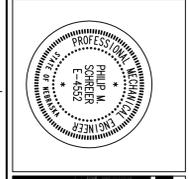


**CLH**  
 Calvin L. Hinz Architects, P.C.  
 3705 North 20th Street  
 Elkhorn, Nebraska 68022  
 Phone: (402) 291-0941 Fax: (402) 291-0188

**FARIS ENGINEERING**  
 CIVIL, MECHANICAL, ELECTRICAL, PLUMBING, AND CONSTRUCTION SERVICES  
 122017

Drawing Title	Project Title
<b>GROUND FLOOR - PLUMBING PLAN</b>	<b>CORRECT NMIHOS SPD DEFICIENCIES</b>
Approved Project Director KENNETH SELL	Location VAMC Grand Island, Nebraska
CONSTRUCTION DOCUMENTS (CD-3) FINAL SUBMITTAL (100%) APRIL 6, 2012	Date APRIL 6, 2012
Checked PMS	Drawn MIS
Project Number 636-12-105A	Building Number ONE
Drawing Number <b>P1.1</b>	Dwg 7 of 8

Office of Construction and Facilities Management  
 Department of Veterans Affairs

**GROUND FLOOR - PLUMBING PLAN**  
 FIN SCALE 1/8" = 1'-0"  
 NORTH

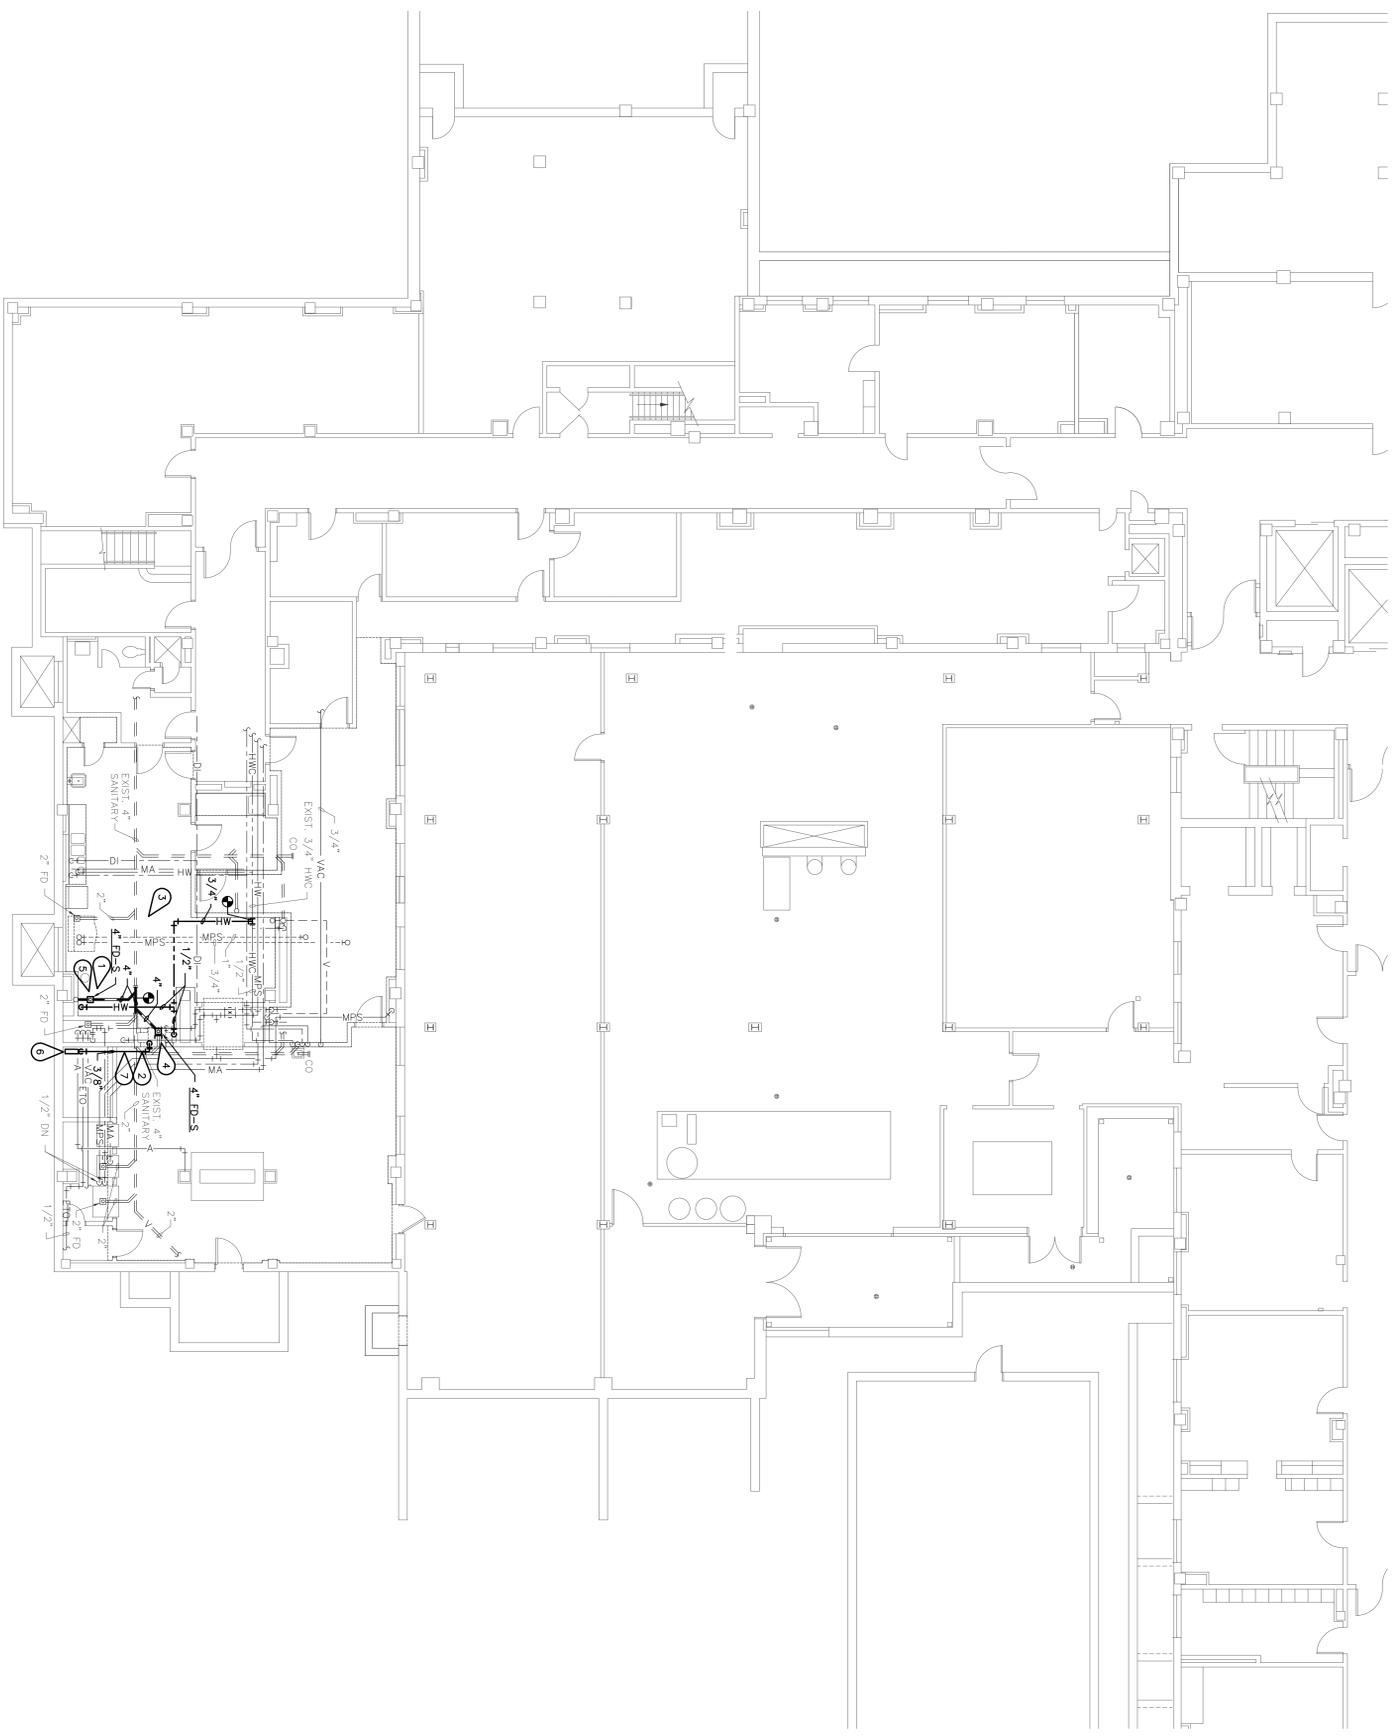

- PLUMBING KEYNOTES:**
- CONNECT 1/2" HOT WATER AND 1-1/2" DRAIN PIPING TO ULTRASONIC CLEANER FROM MAIN DRAIN PIPING. COORDINATE ALL SHUTOFF VALVES AND THREADED FLEXIBLE HOSE CONNECTIONS FOR SERVICE AND CLEANING. FIELD VERIFY LOCATIONS. COORDINATE ALL WITH EQUIPMENT SUPPLIER. - THIS IS ASSOCIATED WITH ALTERNATE BID.
  - CONNECT 1/2" HOT WATER, 1/2" COLD WATER, 1/2" AIR, 2-1/2" DRAIN, 1/2" STEAM AND 1/2" CONDENSATE RETURN TO WASHER/DISINFECTOR. PROVIDE TRAP FOR DRAIN PIPING. BACKFLOW PREVENTER, SHUTOFF VALVE, AND AIR COMPRESSOR TO BE PROVIDED BY EQUIPMENT SUPPLIER. COORDINATE ALL CONNECTIONS WITH EQUIPMENT SUPPLIER. - THIS IS ASSOCIATED WITH ALTERNATE BID.
  - CONTRACTOR SHALL DISCONNECT AND RECONNECT ALL EQUIPMENT THAT IS TO BE MOVED FOR INSTALLATION OF NEW FLOORING. COORDINATE WITH ALL TRADES.
  - REMOVE EXISTING FLOOR DRAIN AND REPLACE WITH NEW 4" FLOOR SINK. RECONNECT TO EXISTING SANITARY PIPING AS SHOWN. - THIS IS ASSOCIATED WITH ALTERNATE BID.
  - INSTALL NEW 4" FLOOR SINK FOR ULTRASONIC CLEANER. - THIS IS ASSOCIATED WITH ALTERNATE BID.
  - INSTALL AIR COMPRESSOR FURNISHED BY OWNER. THIS IS ASSOCIATED WITH ALTERNATE BID.
  - ROUTE 3/8" COMPRESSED AIR PIPE TO WASHER/DISINFECTOR. - THIS IS ASSOCIATED WITH ALTERNATE BID.