



VETERAN'S ADMINISTRATION MEDICAL CENTER OF THE OZARKS UPGRADE WATER SOFTENER



1100 N. COLLEGE AVENUE
FAYETTEVILLE, AR 72703

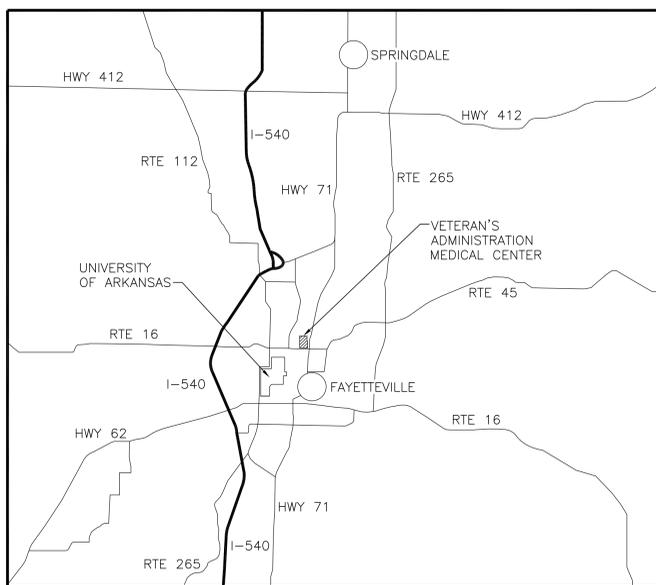

1 PROJECT LOCATION MAP
G-001 | G-001 SCALE: NOT TO SCALE

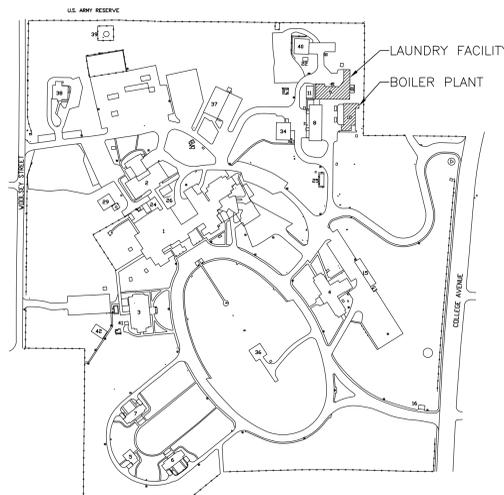

2 PROJECT SITE LOCATION MAP
G-001 | G-001 SCALE: NOT TO SCALE

DRAWING
SEQUENCE
NUMBER
1 OF 2
2 OF 2

DRAWING
NUMBER
G-001
M-101

DRAWING TITLE
COVER SHEET
MECHANICAL GROUND FLOOR PLAN

CURRENT
REVISION
NUMBER

CURRENT
REVISION
DATE

- 3/27/2012
- 3/27/2012

CONSULTANTS:

ARCHITECT/ENGINEERS:



400 South Woods Mill Rd.
Suite 100
Chesterfield, MO 63017
Tel: (314) 439-9900
Fax: (314) 439-9906
www.vestalcorporation.com

engineers architects construction consultants

Drawing Title

COVER SHEET

Project Title

UPGRADE WATER SOFTENER

Project Number

Building Number

10

Drawing Number

G-001

Dwg. 1 of 2

Approved Project Director

VAMC FAYETTEVILLE, ARKANSAS

Date 03/27/2012

Checked RFPV

Drawn JPB

Office of
Construction
and Facilities
Management

