


KEYED NOTES

- ① 2" HOT WATER SUPPLY AND RETURN PIPES UP IN CHASE. INSTALL GOLD AND HOT WATER SUPPLY AND RETURN VALVES IN RISER.
- ② 4" CHILLED WATER SUPPLY AND RETURN PIPES UP IN CHASE. INSTALL GOLD AND HOT WATER SUPPLY AND RETURN VALVES IN RISER.
- ③ CHILLED WATER SUPPLY AND RETURN, HOT WATER SUPPLY AND RETURN PIPES UP IN CHASE. ROUTE ABOVE CEILING. PROVIDE 30X30 SERVICE ACCESS DOOR AT CHASE.
- ④ 4" CHILLED WATER SUPPLY AND RETURN PIPES UNDER GROUND TO CHILLER PLANT. INSULATE PIPES AS PER SPECIFICATIONS.
- ⑤ 2" HOT WATER SUPPLY AND RETURN PIPES UNDER GROUND TO BOILER PLANT. INSULATE PIPES AS PER SPECIFICATIONS.
- ⑥ 4" CHILLED WATER SUPPLY AND RETURN PIPES DOWN THRU CONCRETE SLAB. MECHANICAL CONTRACTOR TO PROVIDE PIPE INSULATION FOR ALL THE PIPES INSIDE THE CHILLER PLANT.
- ⑦ 2" HOT WATER SUPPLY AND RETURN PIPES DOWN THRU CONCRETE SLAB. MECHANICAL CONTRACTOR TO PROVIDE PIPE INSULATION FOR ALL THE PIPES INSIDE THE BOILER PLANT.
- ⑧ 30"x30" ACCESS DOOR FOR CHILLED WATER, HOT WATER SUPPLY AND RETURN SHUT OFF VALVES.



three inches = one foot
 one and one half inches = one foot
 one inch = one foot
 three quarters inch = one foot
 one half inch = one foot
 three eighths inch = one foot
 one quarter inch = one foot
 one eighth inch = one foot

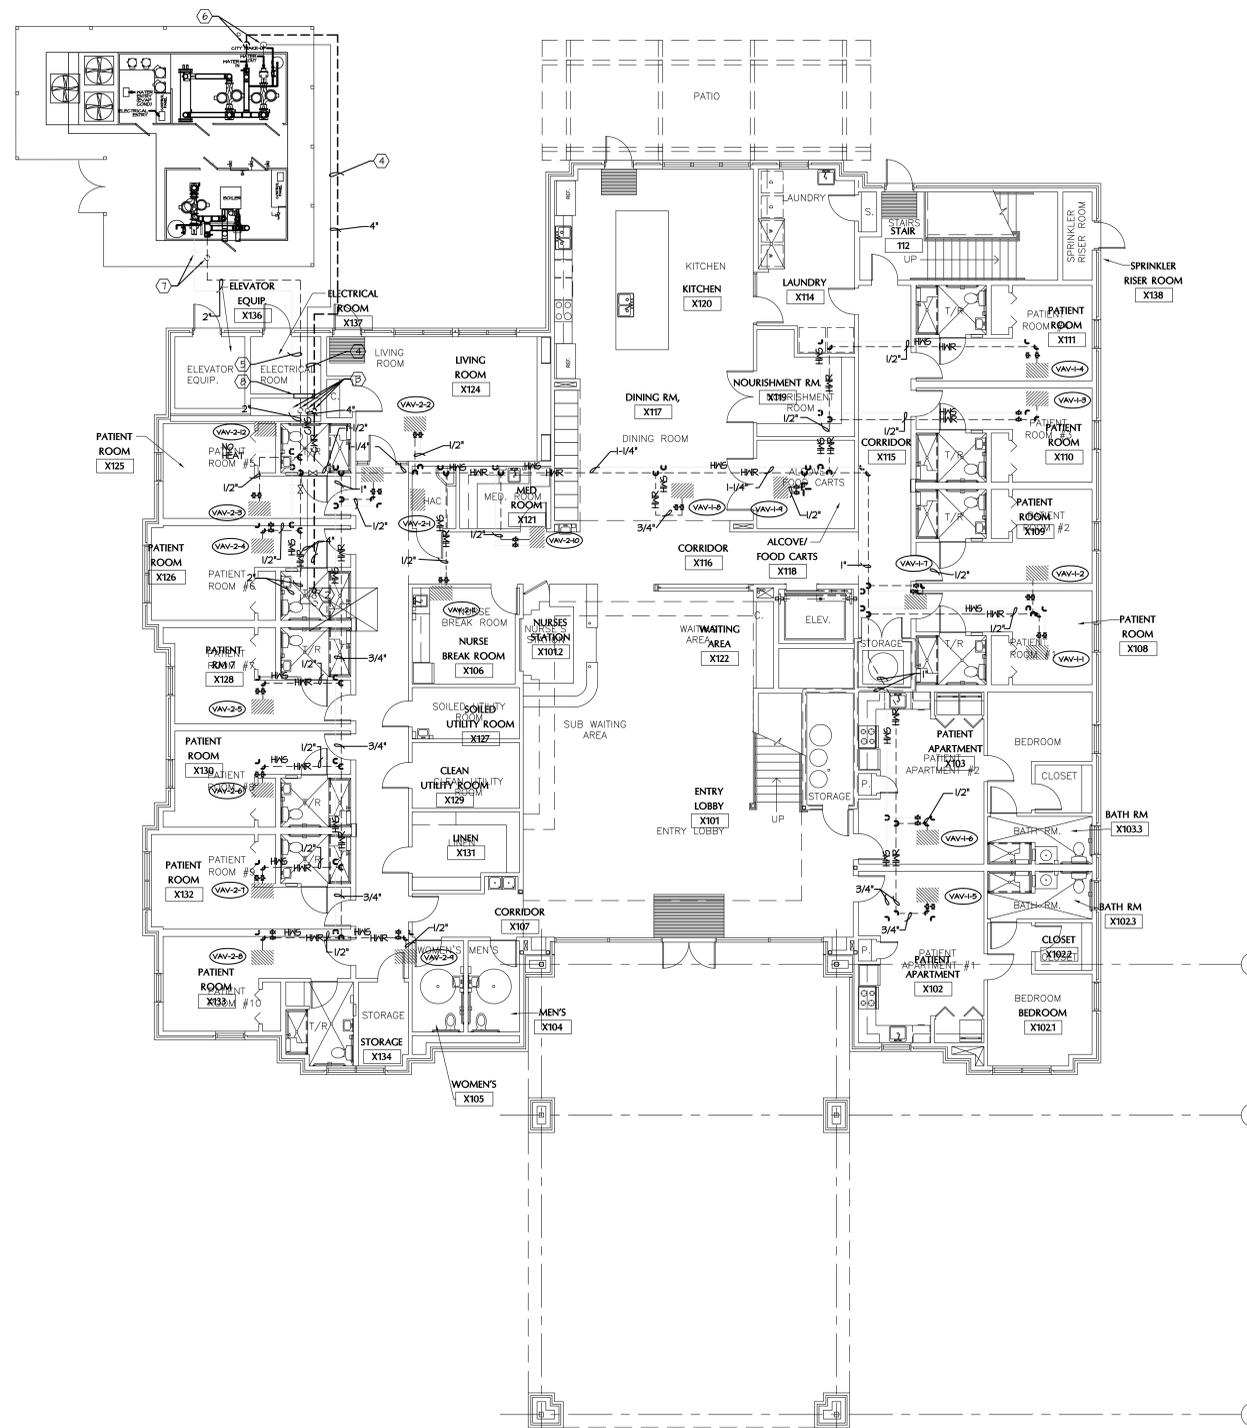

1 FIRST FLOOR MECHANICAL PLAN - CHILLED WATER & HOT WATER PIPING
 SCALE: 1/8" = 1'-0"

RECORD DRAWINGS
 DATE: NOVEMBER 16, 2012
 THESE AS-BUILT DOCUMENTS HAVE BEEN PREPARED BASED ON INFORMATION PROVIDED BY THE CONTRACTOR LOCKER GENERAL CONTRACTORS, LTD. THE ARCHITECT/ENGINEER HAS NOT VERIFIED THE ACCURACY AND/OR COMPLETENESS OF THIS INFORMATION AND SHALL NOT BE RESPONSIBLE FOR ANY ERRORS OR OMISSIONS THAT MAY BE INCORPORATED AS RESULT OF INCORRECT INFORMATION PROVIDED BY THE CONTRACTOR.

CONSULTANTS: TEXAS REGISTERED ENGINEERING FIRM P-10487 700 N. ST. MARY'S SUITE 1225 SAN ANTONIO, TX 78205 WWW.RDMENGINEERING.NET PHONE: 210.299.4522 FAX: 210.299.4525	Approved: Assistant Director Approved: Service Chief Approved: Chief, Biomed Approved: Chief, IT Approved: Chief, Safety	Approved: Chief of Staff Approved: Service Chief Approved: Chief, EMS Approved: Chief, M & O Approved: Chief	Approved: Chief, Engineering Approved: Service Chief Approved: Chief, Infection Control Approved: Chief, Police Approved: Chief	ARCHITECT: WEST EAST DESIGN GROUP 1617 E. COMMERCE ST., SUITE 7102, SAN ANTONIO, TEXAS 78205 USA 210.530.0755 FAX 210.530.9427 These documents can not be copied or reproduced without written consent from WestEast Design Group	Drawing Title FIRST FLOOR MECHANICAL PLAN PIPING SCHEMATIC Approved: Project Director	Project Title POLYTRAUMA TRANSITIONAL HOUSING Location Audie L. Murphy Memorial Veterans Hospital San Antonio, Texas Date 28 JULY 2010	Project Number 671-237 Building Number 1 Drawing Number MH2.1 Dwg. 4 of 10	Office of Facilities Management Department of Veterans Affairs
	Revisions: _____ Date: _____						Checked _____ Drawn _____	