

VA MEDICAL CENTER INSTALL EMERGENCY WATER SUPPLY SYSTEM


Fargo, North Dakota

Project Number: 437-12-104




GENERAL
X1 COVER SHEET

MECHANICAL
F1 EMERGENCY WATER SUPPLY PLUMBING PLAN

ELECTRICAL
E1 FIRST FLOOR PLAN - ELECTRICAL REMODELING

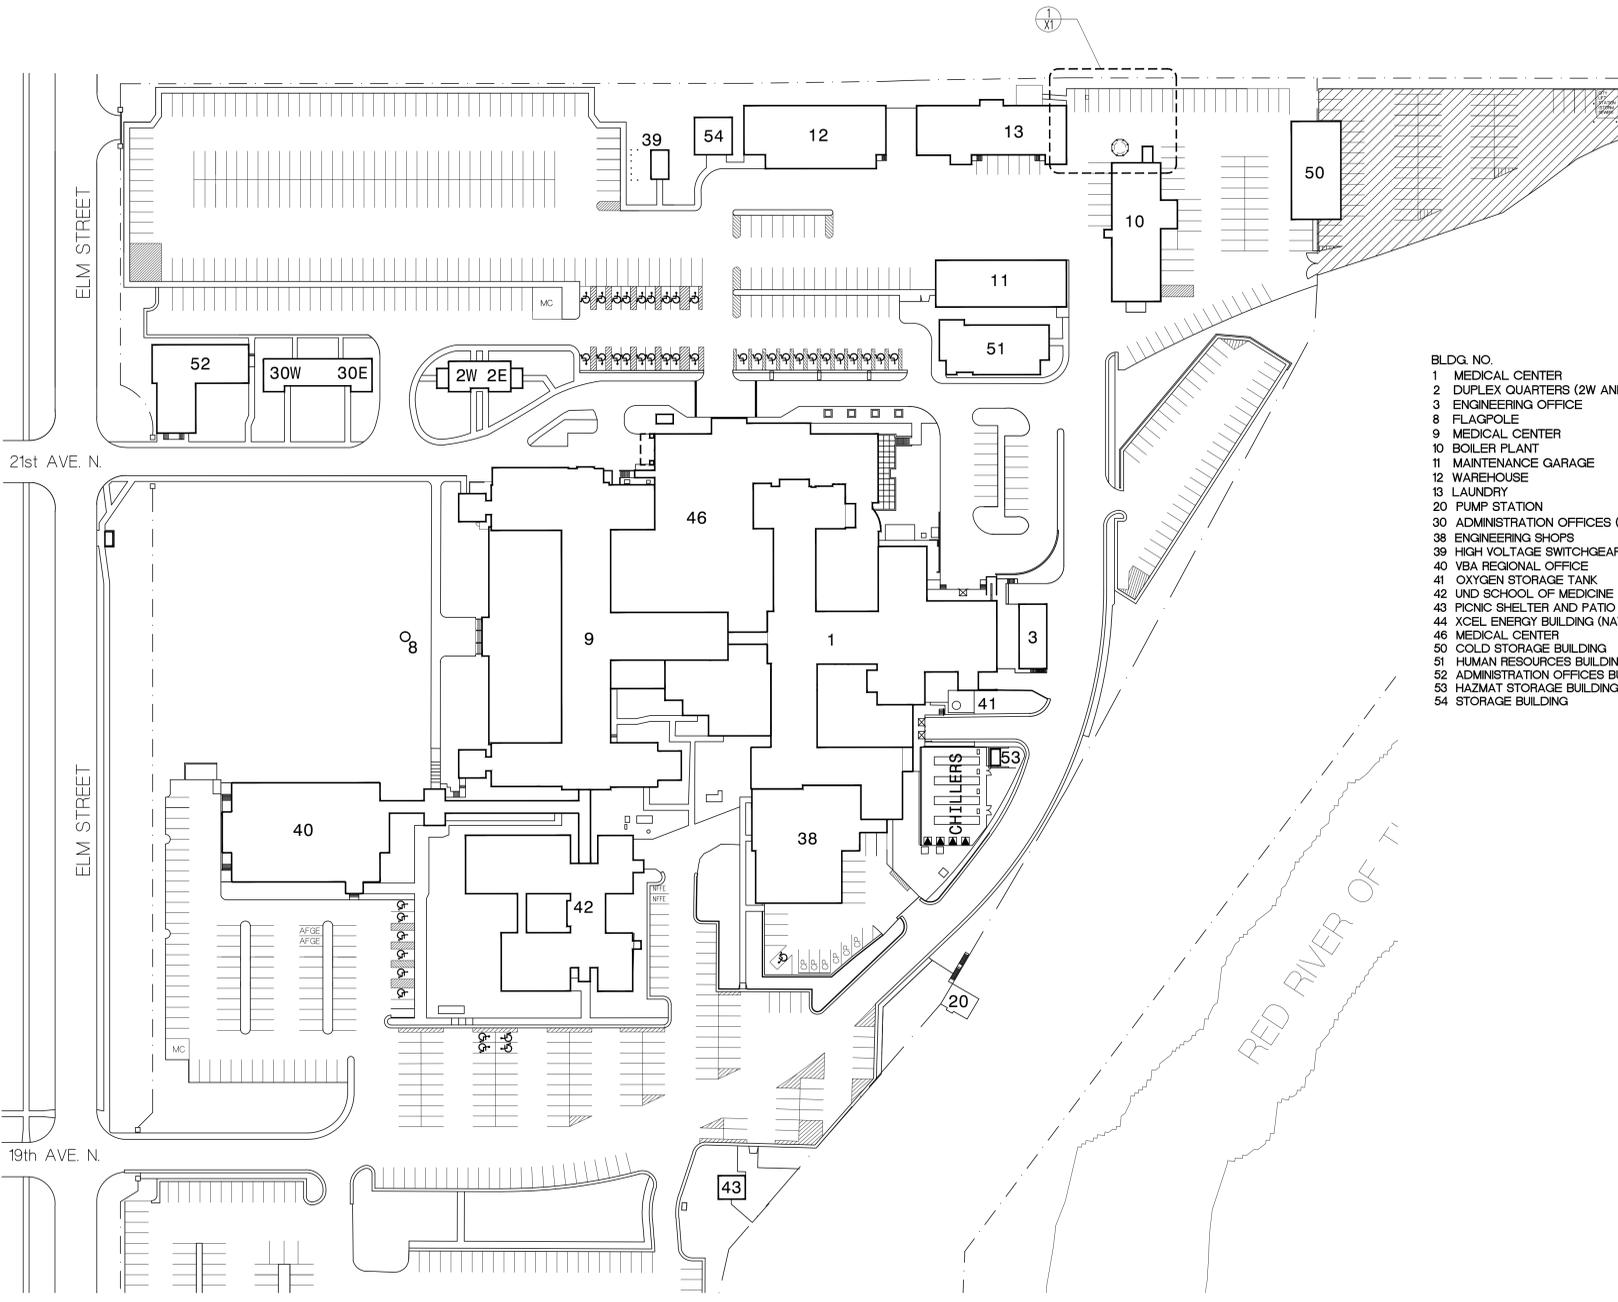

- BLDG. NO.**
- 1 MEDICAL CENTER
 - 2 DUPLEX QUARTERS (2W AND 2E)
 - 3 ENGINEERING OFFICE
 - 8 FLAGPOLE
 - 9 MEDICAL CENTER
 - 10 BOILER PLANT
 - 11 MAINTENANCE GARAGE
 - 12 WAREHOUSE
 - 13 LAUNDRY
 - 20 PUMP STATION
 - 30 ADMINISTRATION OFFICES (30W AND 30E)
 - 38 ENGINEERING SHOPS
 - 39 HIGH VOLTAGE SWITCHGEAR BUILDING
 - 40 VBA REGIONAL OFFICE
 - 41 OXYGEN STORAGE TANK
 - 42 UNID SCHOOL OF MEDICINE
 - 43 PICNIC SHELTER AND PATIO
 - 44 XCEL ENERGY BUILDING (NATURAL GAS)
 - 46 MEDICAL CENTER
 - 50 COLD STORAGE BUILDING
 - 51 HUMAN RESOURCES BUILDING
 - 52 ADMINISTRATION OFFICES BUILDING
 - 53 HAZMAT STORAGE BUILDING
 - 54 STORAGE BUILDING

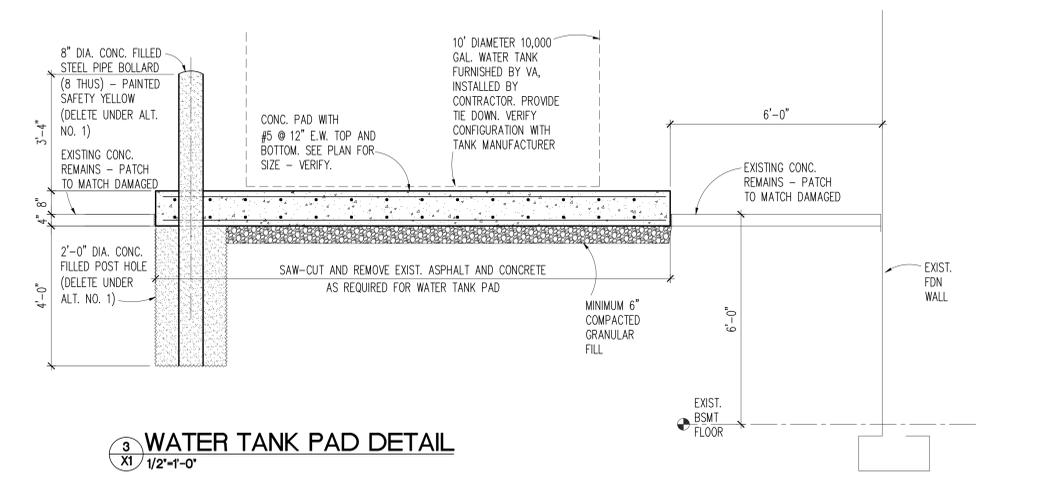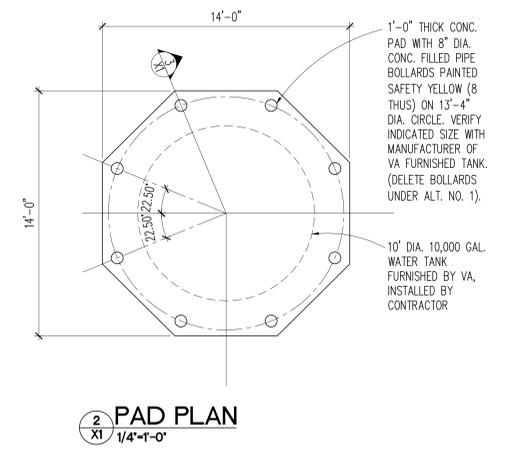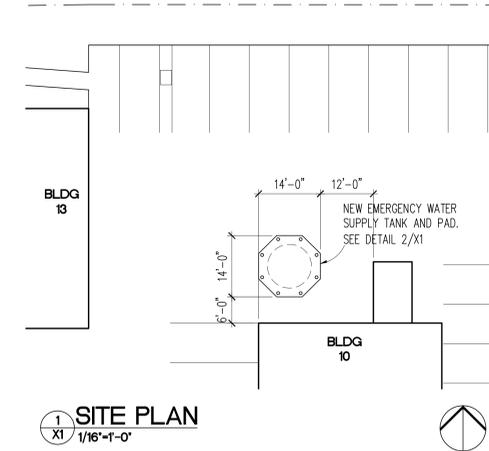

KEY TO SITE PLAN
 CONTRACTOR STAGING AREA. SHARED WITH VA AND OTHER CONTRACTORS.

SITE PLAN
T=80'-0"

Dept. of Veterans Affairs
Medical Center
 2101 Elm Street North
 Fargo, ND 58102

IMAGE GROUP
 IMAGE GROUP INC. Architecture & Interiors
 OBERMILLER NELSON ENGINEERING, Mechanical Engineers
 MEN ENGINEERING, Electrical Engineers

I hereby certify that this plan specification, or report was prepared by me or under my direct supervision, and that I am duly Registered Architect under the laws of the State of North Dakota.
 Date: 4/20/2012 Reg. No. 378

Drawing Title COVER SHEET		Project Title VA MEDICAL CENTER INSTALL EMERGENCY WATER SUPPLY SYSTEM		Date APRIL 20, 2012
VA Project No. 437-12-104	Contract No. VA263-P-1217 VA263-C-	Designed By RM	Checked By RM	Drawn By KS
Building No. 10	AutoCAD File Name COVERDWG	Location VA MEDICAL CENTER FARGO, ND	Scale AS SHOWN	Drawing No. X1
			Dwg. 1 of 3	

U:\Speer Project Data\013_Emp_MMC_00011_Instal_Emergency_Water_Supply_System\CAD\DWG\Cover.dwg, Apr 20, 2012 - 9:24am

