
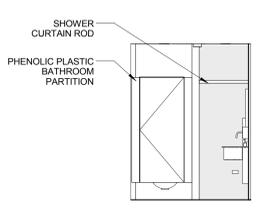



ENLARGED FLOOR PLAN NOTES

- REFER TO A101 FOR DETAILS TO USE IN 2B122 AND 2B123. SEAL ALL PENETRATIONS OF WALL, FLOOR, OR CEILING FINISH INCLUDING BUT NOT LIMITED TO LIGHTS, DIFFUSERS, ELECTRICAL DEVICES AND MOUNTING BOXES, PIPE OR CONDUIT PENETRATIONS.


three inches = one foot
 one and one half inches = one foot
 one inch = one foot
 three quarters inch = one foot
 one half inch = one foot
 one quarter inch = one foot
 three eighths inch = one foot
 one eighth inch = one foot

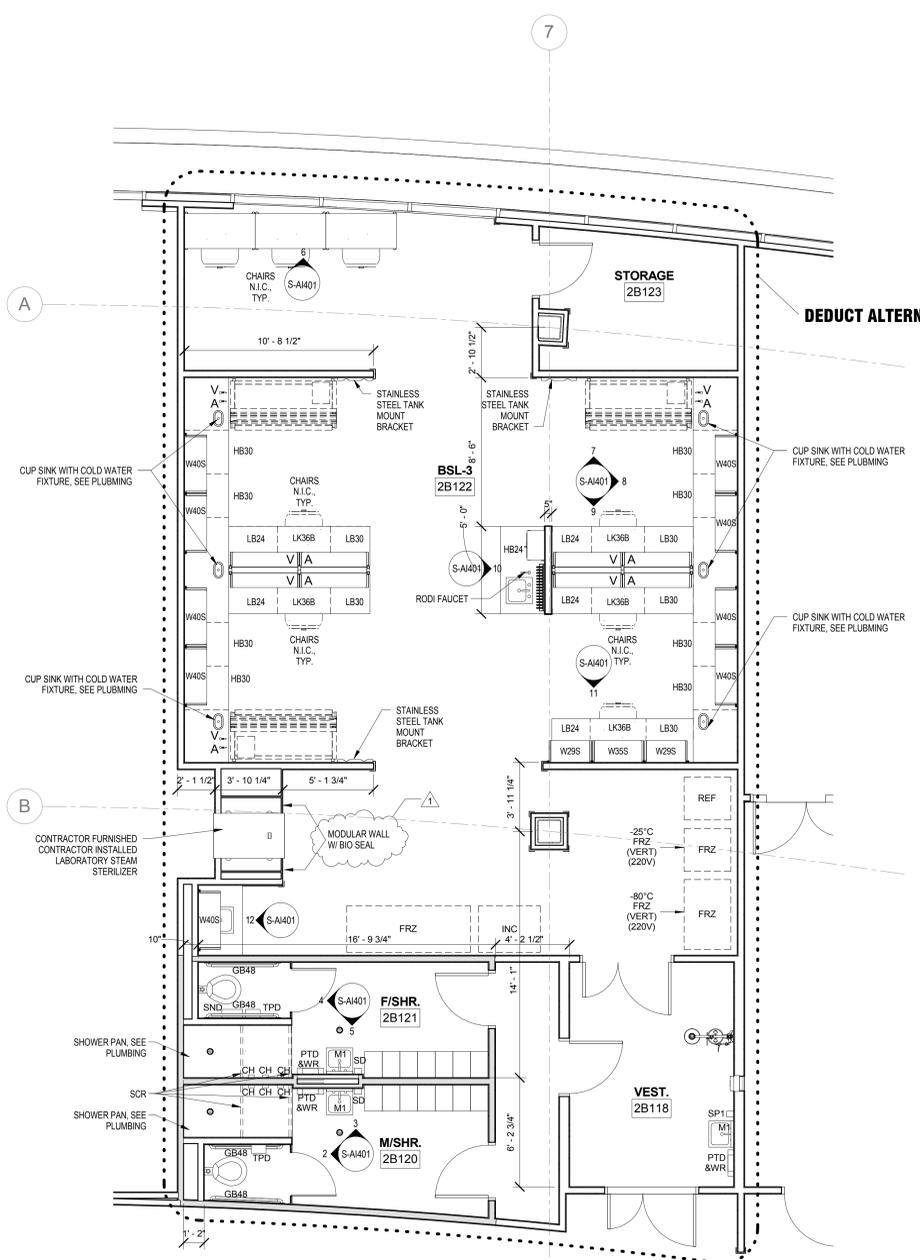


2 M/SHR. SOUTH
1/4" = 1'-0"

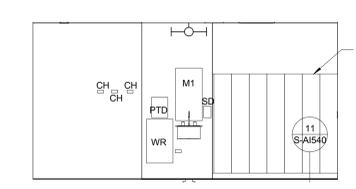


3 M/SHR. WEST
1/4" = 1'-0"

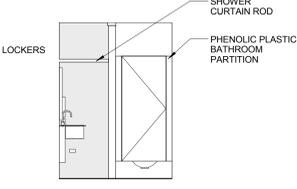


4 F/SHR. SOUTH
1/4" = 1'-0"

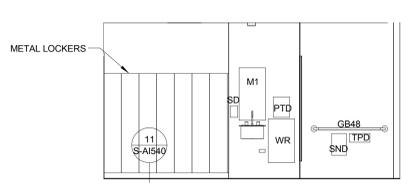


5 F/SHR. EAST
1/4" = 1'-0"

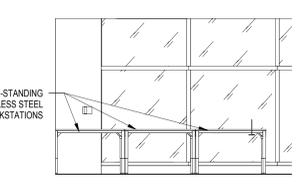


6 BSL-3 WORKSTATIONS
1/4" = 1'-0"

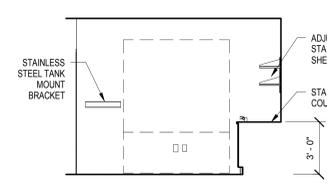


7 BSL-3 WEST
1/4" = 1'-0"

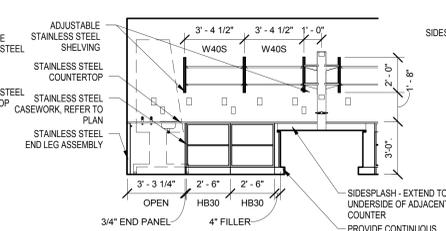


8 BSL-3 NORTH
1/4" = 1'-0"

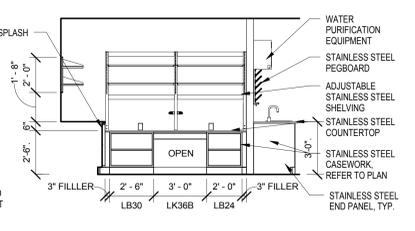


9 BSL-3 EAST
1/4" = 1'-0"

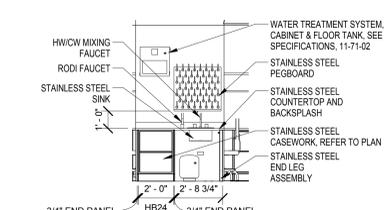


10 BSL-3 NORTH 2
1/4" = 1'-0"

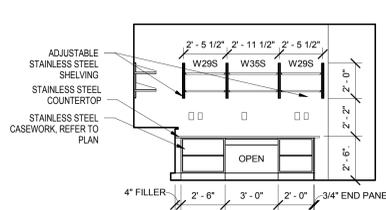


11 BSL-3 EAST 2
1/4" = 1'-0"

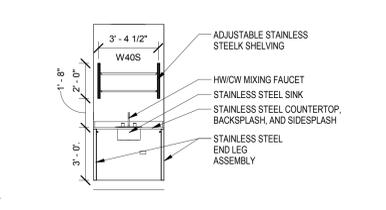


12 BSL-3 SOUTH 2
1/4" = 1'-0"

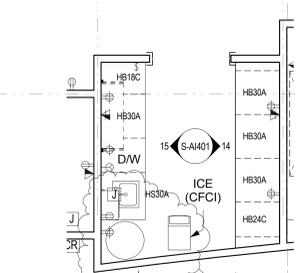


13 GLASS WASH
1/4" = 1'-0"

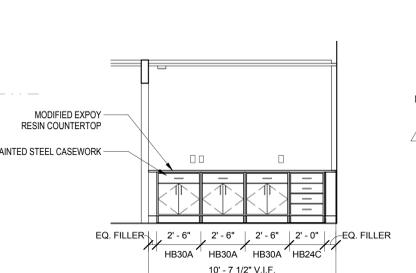

14 GLASS WASH NORTH
1/4" = 1'-0"

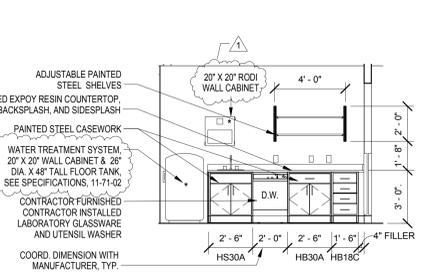

15 GLASS WASH SOUTH
1/4" = 1'-0"

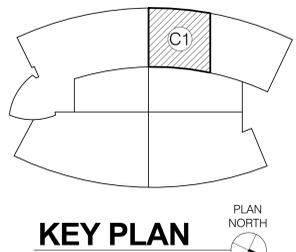

KEY PLAN
PLAN NORTH

FINAL DESIGN
 APPROVED FOR CONSTRUCTION

<p>ADDENDUM 1 April 7, 2017</p>	<p>CONSULTANTS:</p>	<p>ARCHITECT-OF-RECORD THOMAS H. GYLSTROM FL REG. NO. 9598</p>	<p>ARCHITECT/ENGINEERS: AKEA INC. 3603 NW 98th Street, Suite B Gainesville, FL 32606 Phone: (352) 474-6124 Fax: (352) 474-6324 AKEA Project No. 039-12</p>	<p>Drawing Title ENLARGED PLANS AND ELEVATIONS - BSL3</p>	<p>Project Title VAMC AT LAKE NONA BUILD NEW RESEARCH SPACE</p>	<p>Project Number 675-900</p>	<p>Office of Construction and Facilities Management</p>
<p>Revisions:</p>	<p>Date</p>	<p>APPROVED FOR CONSTRUCTION</p>	<p>Approved: Project Director</p>	<p>Location Orlando, Florida</p>	<p>Building Number 13</p>	<p>Drawing Number S-AI401 24 OF 176</p>	