


Electronic sign at Freedom Way
(general location, NTS)

IT Closet

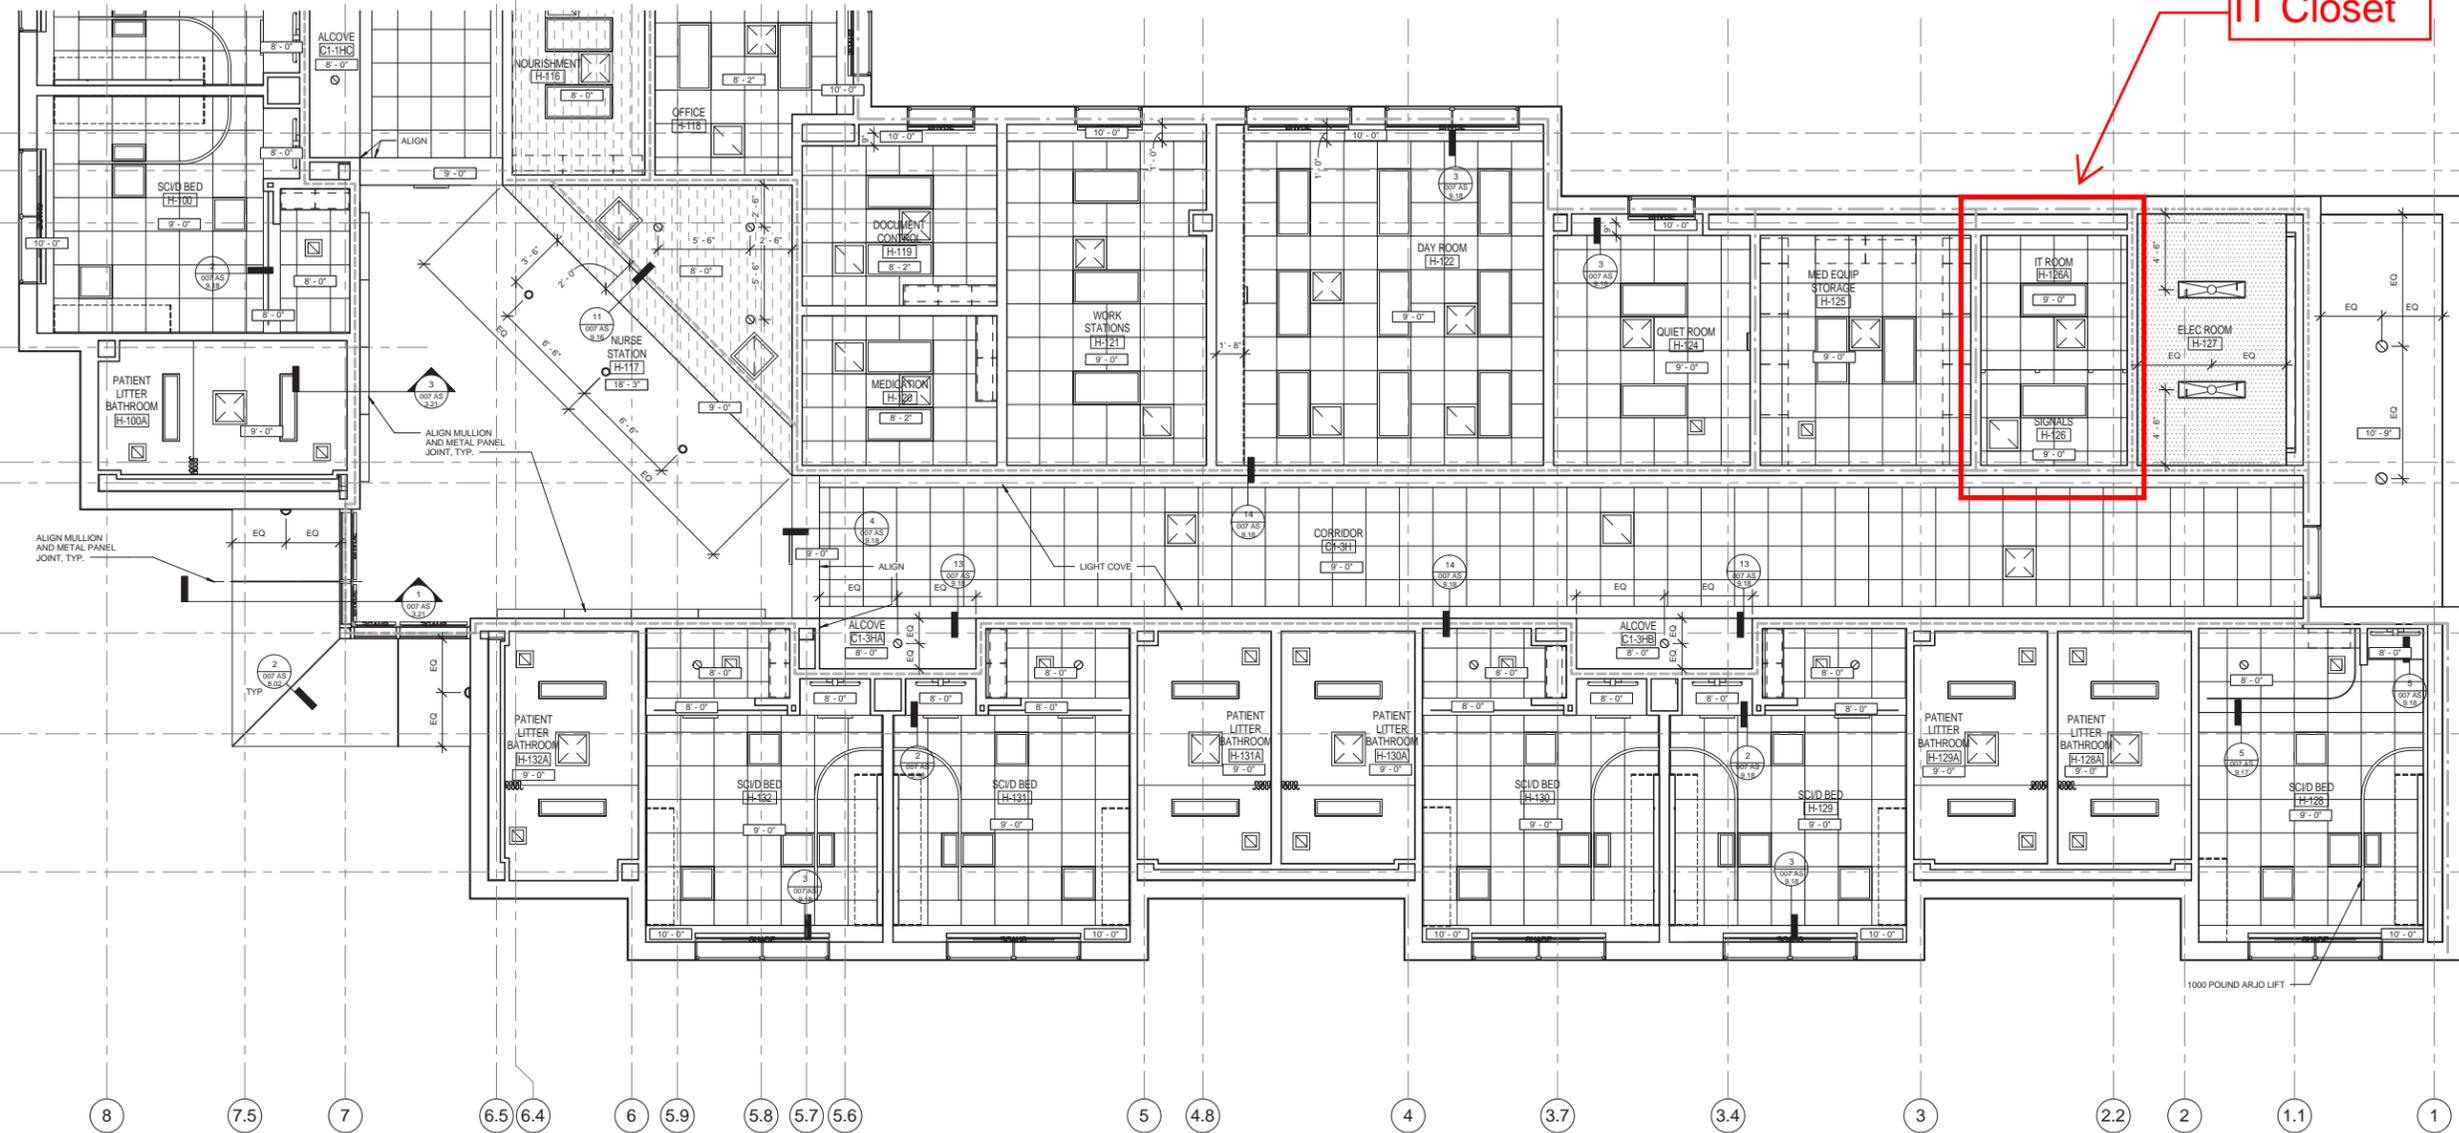

WALL PARTITIONS

	UNRATED WALL
	SMOKE PARTITION
	1-HR OCCUPANCY SEPERATION
	1-HR FIRE BARRIER
	2-HR FIRE BARRIER
	2-HR FIRE WALL
	DEMOLITION BUILDING WALL
	CLERESTORY WINDOW ABOVE

- NOTES:**
- NOT USED.
 - LAYOUT CEILING TILE FROM CENTER OF ROOMS, AND/OR AREAS IN BOTH DIRECTIONS, U.O.N. AN AREA IS DEFINED AS A GROUP OF ROOMS WITH PARTITIONS EXTENDING ONLY TO THE UNDERSIDE OF CEILING AND BORDERED BY PARTITIONS EXTENDING TO THE UNDERSIDE OF STRUCTURAL SLAB ABOVE.
 - COORDINATE LAYOUT OF CEILING FRAMING TO ACHIEVE LOCATIONS, AS SHOWN FOR MECHANICAL, ELECTRICAL, PLUMBING AND SECURITY ITEMS EXPOSED TO VIEW, INCLUDING BUT NOT LIMITED TO LIGHT FIXTURES, AIR SUPPLY AND RETURN DIFFUSERS, SPRINKLER HEADS, SPEAKERS, SMOKE DETECTORS, ETC.
 - LOCATE ALL SPRINKLER HEADS, SMOKE DETECTORS, SPEAKERS AND OTHER CEILING MOUNTED MECHANICAL, ELECTRICAL, PLUMBING AND SECURITY ITEMS IN THE CENTER OF ACOUSTICAL CEILING PANELS, U.O.N.
 - WHERE SPRINKLER HEADS ARE NOT SHOWN, ADJUST SPRINKLER HEAD LOCATIONS TO CLEAR OTHER CEILING FIXTURES AND ELEMENTS AS REQUIRED.
 - WHERE LIGHTING FIXTURE, AIR DIFFUSERS, SMOKE DETECTORS, SPRINKLER HEADS, EXIT SIGNS AND OTHER OVERHEAD AND WALL MOUNTED FIXTURES/ACCESSORIES ARE NOT SHOWN, REFER TO MECHANICAL AND ELECTRICAL DRAWINGS.
 - REFLECTED CEILING PLANS MAY INCLUDE DESIGNATIONS OF TYPICAL PATIENT ROOM. ALL DIMENSIONS, SYMBOLS AND NOTES SHOWN IN SUCH ROOMS ARE TYPICAL FOR SIMILARLY DESIGNATED ROOMS, U.O.N.
 - CURTAIN TRACK RADIUS = 1'-0" TYPICAL, U.O.N.

LEGEND:

	SMOKE PARTITION CEILING		2 X 4 RECESSED FLUORESCENT LIGHT FIXTURE (SEE ELECTRICAL DRAWINGS)		AIR DIFFUSER (SEE MECHANICAL DWGS)
	SUSPENDED CEILING 2x2, 2x4 OR 4x4 AS INDICATED.		2 X 2 RECESSED FLUORESCENT LIGHT FIXTURE (SEE ELECTRICAL DRAWINGS)		AIR DIFFUSER (SEE MECHANICAL DWGS)
	PAINTED GYPSUM BOARD		1 X 4 SUSPENDED FLUORESCENT LIGHT FIXTURE (SEE ELECTRICAL DRAWINGS)		RECESSED LIGHT FIXTURE (SEE ELECTRICAL DRAWINGS)
	OPEN TO STRUCTURE ABOVE (NO CEILING) FOR LIGHTING AND DIFFUSER REFER TO ELECTRICAL AND MECHANICAL DRAWINGS		LINEAR LIGHT FIXTURE (SEE ELECTRICAL DRAWINGS)		

Revisions:

3	As Built	7/10/15
Date		Date

CONSULTANTS:

ARCHITECT/ENGINEERS:
 Lee, Burkhardt, Liu, Inc.
 Architecture, Planning, Interiors
 149 New Montgomery Street, 5th Floor
 San Francisco, California 94105
 Phone (415) 671-4342 Fax (415) 671-4610

Drawing Title: REFLECTED CEILING PLAN - NORTH WING
Scale: 1/4" = 1'-0"
Approved Project Director:
Date:

Project Title: VA Palo Alto Healthcare System Spinal Cord Injury Replacement Unit
Location: 3801 Miranda Avenue, Palo Alto
Date: 07-10-2015
Checked: MB
Drawn: LBL TEAM
Project Number: 640-380
Building Number: 007
Drawing Number: 007 AS 6.01
Dwg. of:

Office of Facilities Management
 Department of Veterans Affairs

CONSTRUCTION DOCUMENTS
FULLY SPRINKLERED

