

### GENERAL CEILING NOTES - NEW WORK


1. NEW HVAC DIFFUSERS/GRILL LOCATIONS ARE NOT SHOWN. REFER TO MECHANICAL DRAWINGS FOR EXACT LOCATIONS.
2. NEW LIGHT FIXTURE LOCATIONS ARE SHOWN FOR GENERAL REFERENCE ONLY. SEE ELECTRICAL DRAWINGS FOR NEW LOCATIONS.
3. NEW SPRINKLER HEAD LOCATIONS ARE NOT SHOWN. NEW SPRINKLER SYSTEM WORK IS TO BE DESIGN-BUILD BY CONTRACTOR. SUBMIT SHOP DRAWINGS FOR APPROVAL AS REQUIRED PER SPECIFICATIONS.
4. NEW CEILING HEIGHTS ARE TO MATCH EXISTING UNLESS NOTED OTHERWISE.
5. REFER TO INFECTION CONTROL PLANS FOR DUST PARTITION LOCATIONS AND PHASING OF WORK.
6. NEW SECURITY SYSTEM TO BE PROVIDED BY OTHERS. COORDINATE THIS WORK WITH THE VA PROJECT MANAGER.

### KEY NOTES

1. RELOCATED EXISTING LIGHTING TRACK SYSTEM. PROVIDE ALL-THREAD ROD SUPPORTS SECURED TO CONCRETE DECK ABOVE. BRACE AS REQUIRED.
2. NEW CEILING IN THIS AREA IS TO BE BLACK ACOUSTICAL CEILING TILE AND GRID. HOLD CEILING AS HIGH AS POSSIBLE.
3. NEW PRIVACY CURTAIN TRACK. FIELD VERIFY LENGTH. CURTAINS TO BE PROVIDED AND INSTALLED BY VA (OPD).
4. EXTEND EXISTING CEILING GRID AND TILE WHERE DOOR FRAME WAS REMOVED.
5. NEW GYP. BOARD SOFFIT ABOVE OVERHEAD CABINETS. SEE MILLWORK ELEVATIONS AND DETAILS.
6. NEW GYP. BOARD HEADER OVER OPERABLE PARTITION. SEE DETAIL.
7. NEW EXIT SIGN. SEE ELECTRICAL.
8. BATHROOM EXHAUST FAN. SEE MECHANICAL.
9. PAINTED MOISTURE RESISTANT GYP. BOARD CEILING AND WET LOCATION SHOWER LIGHT - SEE ELECTRICAL.
10. PROVIDE CUTOUPS IN CEILING AS REQUIRED FOR NEW SLEEP LAB EQUIPMENT TO BE PROVIDED AND INSTALLED BY OTHERS.
11. NEW EXIT SIGN - SEE ELECTRICAL.
12. PROVIDE ELECTRICAL OUTLET IN CEILING TILE FOR FUTURE CEILING MOUNTED PROJECTOR. PROVIDE EMPTY 1" CONDUIT FROM WALL OUTLET TO ABOVE CEILING AT PROJECTOR LOCATION. COORDINATE WITH VA PROJECT MANAGER.
13. DUPLEX OUTLET INSTALLED IN CEILING TILE. SEE ELECTRICAL.

### SYMBOL LEGEND

<p>ONE HOUR FIRE BARRIER</p> <p>TWO HOUR FIRE BARRIER</p> <p>SMOKE COMPARTMENT WALL - ONE OR TWO HOUR FIRE RATING</p> <p>FULL HEIGHT SMOKE RESISTANT</p> <p>EXISTING WALL/PARTITION TO REMAIN</p> <p>NEW FULL HEIGHT PARTITION</p> <p>EXISTING 2 X 2 ACOUSTICAL SUSPENDED CEILING SYSTEM TO REMAIN.</p> <p>NEW 2 X 2 ACOUSTICAL SUSPENDED CEILING. REFER TO SPECIFICATIONS.</p> <p>EXISTING GYPSUM BOARD SOFFIT</p> <p>NEW PAINTED GYPSUM BOARD SOFFIT</p> <p>EXISTING 2 X 4 RECESSED FLUORESCENT LIGHT FIXTURE TO REMAIN. REFER TO ELECTRICAL.</p> <p>NEW OR RELOCATED 2 X 4 RECESSED FLUORESCENT LIGHT FIXTURE. REFER TO ELECTRICAL.</p> <p>EXISTING HVAC GRILL/DIFFUSER TO REMAIN. REFER TO MECHANICAL. SEE MECHANICAL DRAWINGS FOR NEW HVAC WORK AND DIFFUSER LOCATIONS.</p> <p>EXISTING CEILING MOUNTED EXIT SIGN.</p> <p>NEW CEILING MOUNTED EXIT SIGN. SEE ELECTRICAL DRAWINGS FOR QUANTITY AND LOCATIONS. SHADED PORTION INDICATES DIRECTION.</p>	<p>EXISTING NURSE CALL LIGHT TO REMAIN.</p> <p>CCTV SECURITY CAMERA TO REMAIN. NEW SECURITY SYSTEM TO BE PROVIDED AND INSTALLED BY OWNER. CONTRACTOR IS TO COORDINATE THIS WORK WITH THE VA PROJECT MANAGER.</p> <p>CEILING MOUNTED COMMUNICATIONS EQUIPMENT. REMOVE FROM CEILINGS TO BE REMOVED AND RETURN TO OWNER.</p> <p>NEW CEILING FAN WITH LIGHT KIT. FAN TO BE SUPPLIED AND INSTALLED BY CONTRACTOR. LIGHT KIT TO BE SUPPLIED BY CONTRACTOR AND INSTALLED BY OWNER.</p> <p>EXISTING PRIVACY CURTAIN TRACK TO REMAIN OR RELOCATED. COORDINATE THIS WORK WITH THE VA PROJECT MANAGER.</p> <p>NEW PRIVACY CURTAIN TRACK. CURTAINS TO BE PROVIDED AND INSTALLED BY THE VA.</p> <p>NEW 4 FOOT STRIP FLUORESCENT FIXTURE WITH ACRYLIC COVER. SEE ELECTRICAL DRAWINGS.</p> <p>MECHANICAL DIFFUSERS/REGISTERS. SEE MECHANICAL PLANS FOR LOCATIONS.</p> <p>SURFACE MOUNTED LIGHT FIXTURE. SEE ELECTRICAL.</p>
---	--

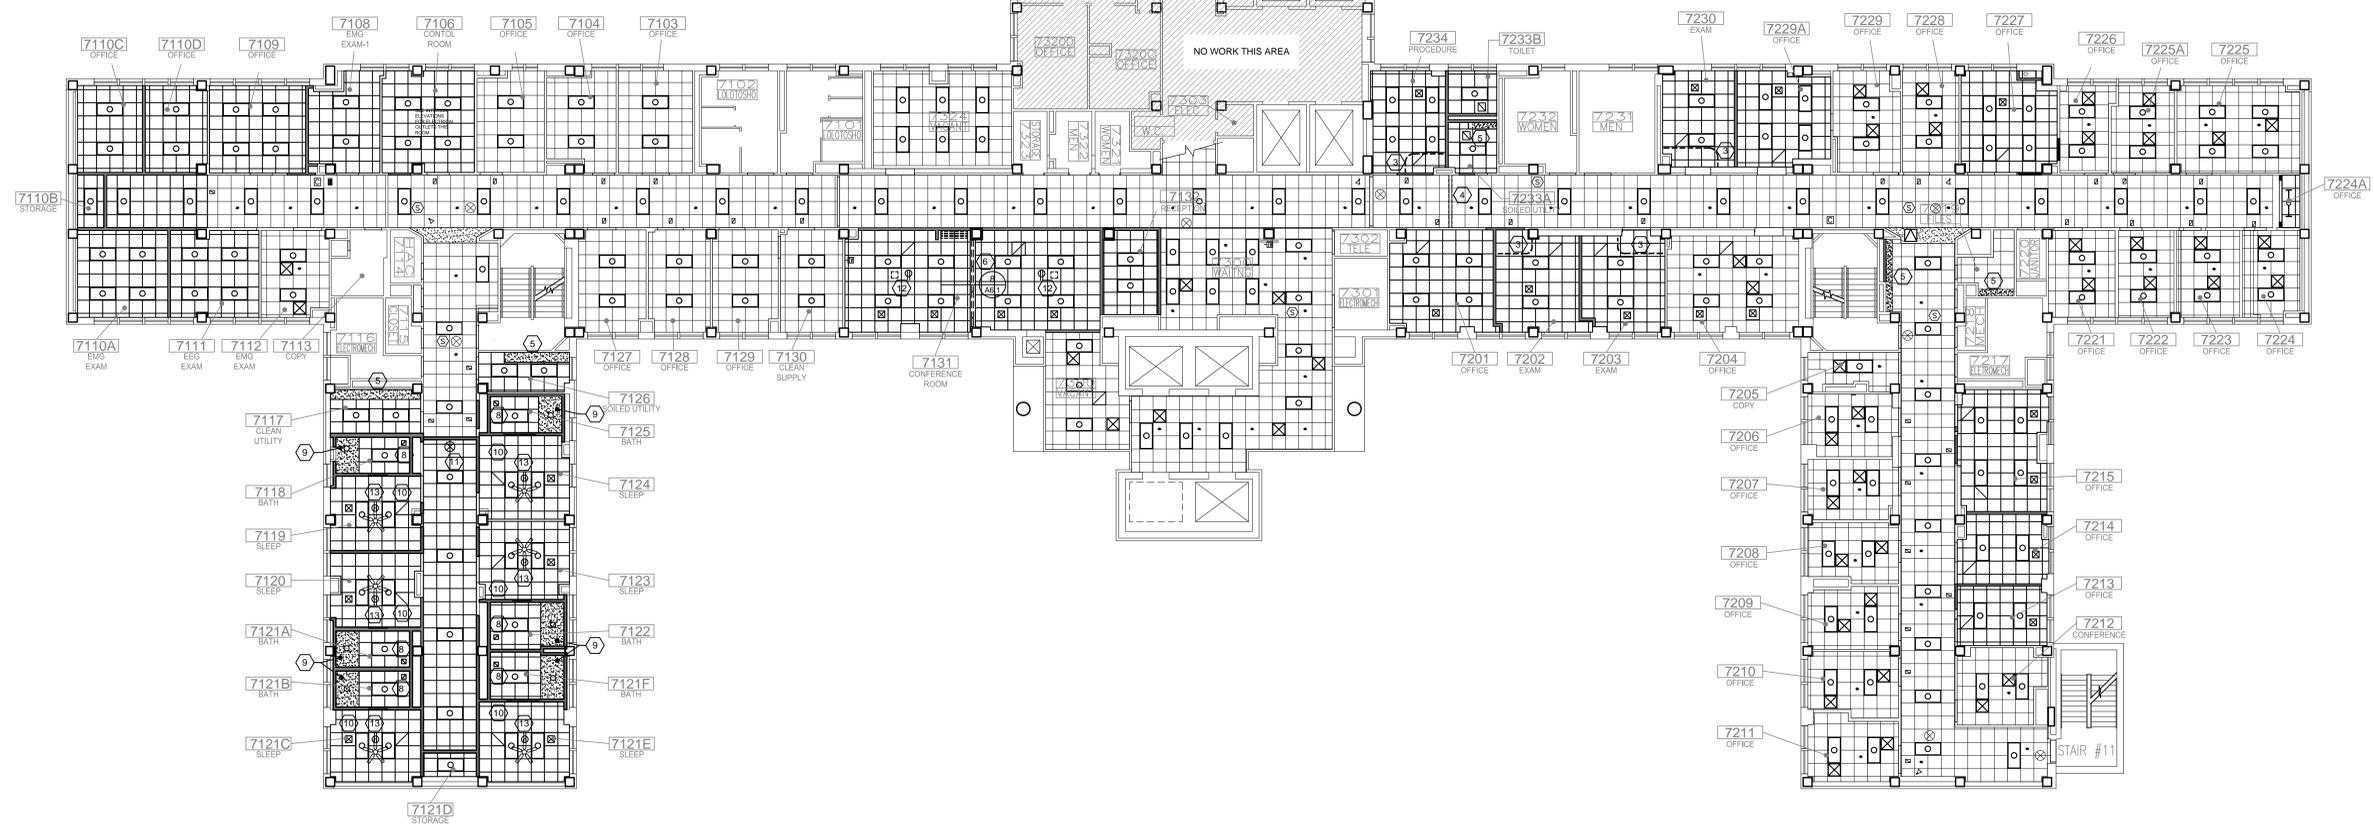

**7TH FLOOR REFLECTED CEILING PLAN - NEW WORK**  
 SCALE: 3/32" = 1'-0"

Revisions	Date

**BIRCHFIELD PENUEL & ASSOCIATES, ARCHITECTS**  
 2805 CRESCENT AVENUE • SUITE 200 • BIRMINGHAM, ALABAMA 35209



**Department of Veterans Affairs  
 MEDICAL CENTER  
 BIRMINGHAM, ALABAMA**

Drawing Title <b>7th FLOOR REFLECTED CEILING PLAN NEW WORK</b>	Project Title <b>RENOVATE SPACE FOR REHAB AND PHYSICAL MEDICINE</b>	Date: <b>08-02-11</b> VA Project No. 521-10-101 CAD File No. 10709A3.1.dwg
Building Numbers	Checked	Drawn
Location VA MEDICAL CENTER BIRMINGHAM, ALABAMA	Drawing No. <b>A3.3</b> Dwg. of	

**FINAL SUBMITTAL**

**Veterans Administration**