

ONE INCH = FORTY FEET (1" = 40')

THREE INCHES = ONE FOOT

ONE AND ONE HALF INCHES = ONE FOOT


THREE QUARTERS INCH = ONE FOOT

ONE HALF INCH = ONE FOOT

ONE QUARTER INCH = ONE FOOT

ONE EIGHT INCH = ONE FOOT

ONE SIXTEENTH INCH = ONE FOOT

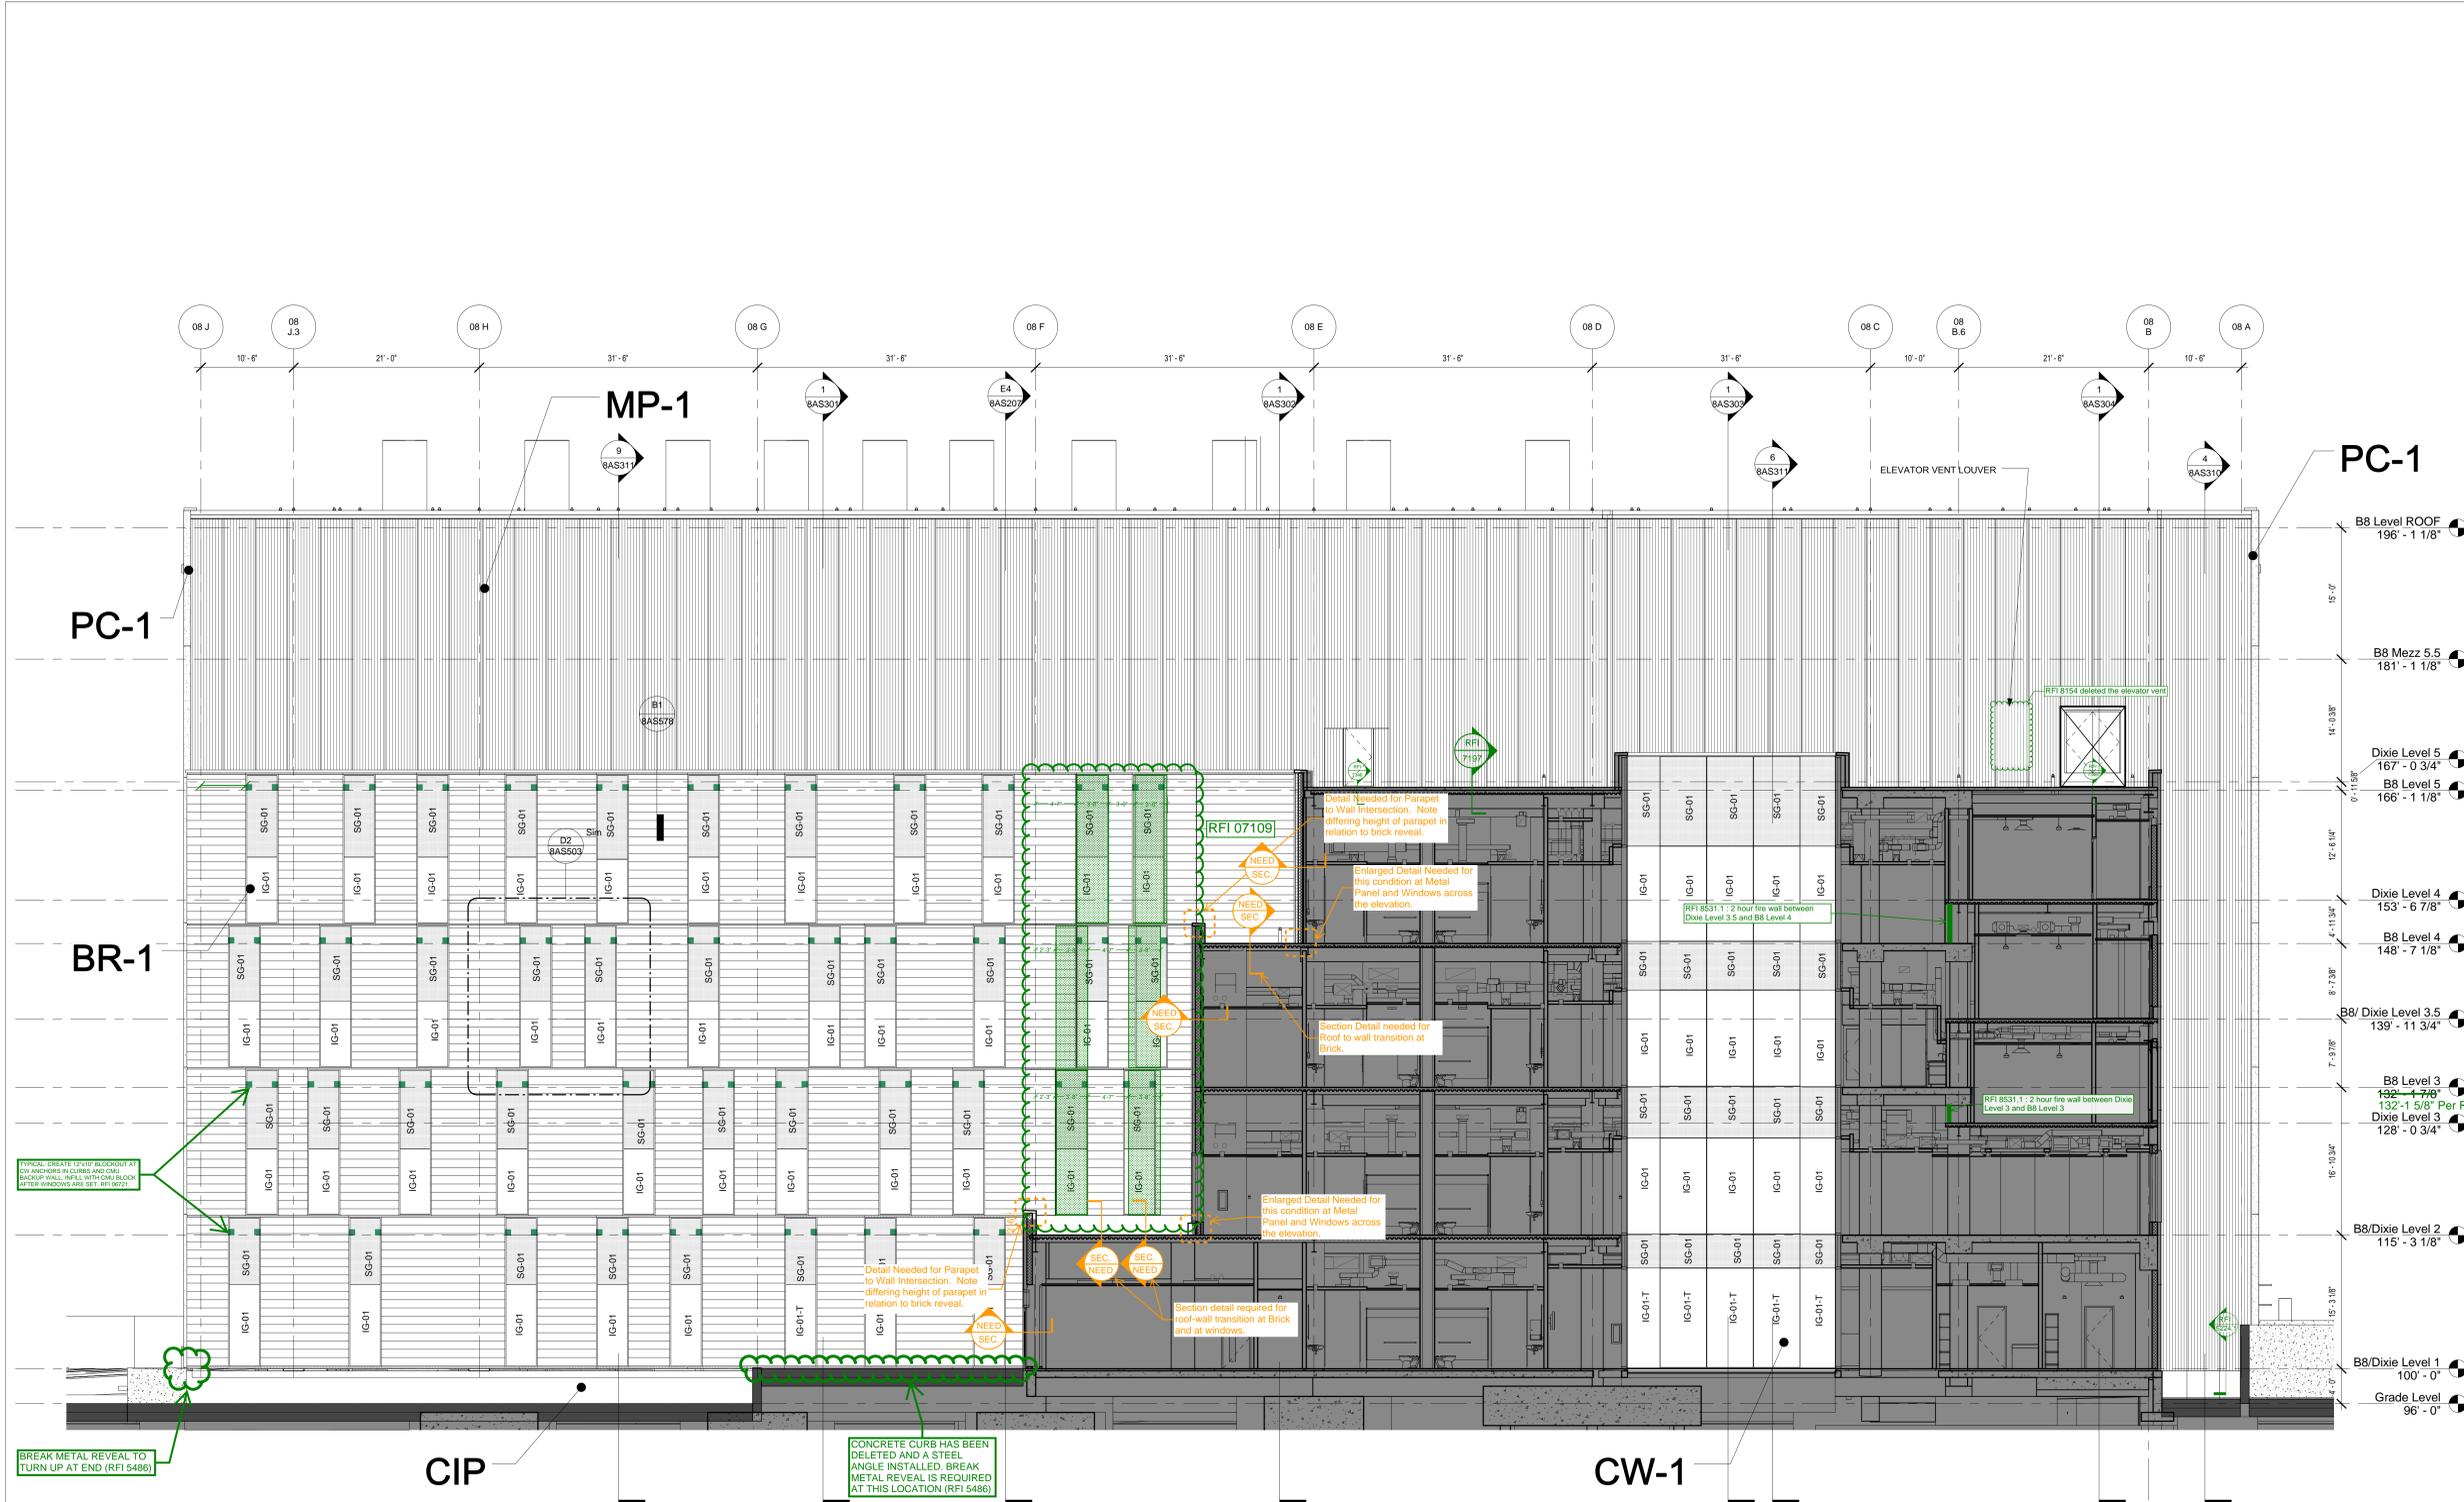

EXTERIOR MATERIALS LEGEND

MATERIAL TYPES	
INSULATED LAMINATED VISION	IG-01
INSULATED LAMINATED SPANDREL	IG-01x-T
METAL PANEL (MP-1B)	SG-01
METAL PANEL (MP-1, MP-1A)	SG-01x-T
PRECAST	SGS-1
STUCCO / E.I.F.S (SEE NOTE ON ELEV.)	
MECHANICAL LOUVER	
MASONRY CAVITY WALL (BR-1)	

GLAZING TYPES

IG-01	INSULATED LAMINATED VISION
IG-01x-T	INSUL. LAMINATED VISION TEMPERED
SG-01	INSUL. LAMINATED SPANDREL
SG-01x-T	INSUL. LAMINATED SPANDREL TEMPERED
SGS-1	LAMINATED GLASS SPANDREL

SYMBOLS LEGEND

(X)	PRECAST (WALL TYPE PC-1) PATTERN TYPE INDICATOR. SEE SHEET 8AS506 FOR PANEL TYPES
O.D	OVERFLOW DRAIN (SECONDARY)
O.S	OVERFLOW SCUPPER
⊕	M.E.P. PENETRATIONS THROUGH ENCLOSURE
□	LIGHTING OVER EXIT

WALL TYPES LEGEND

WALL TYPE MARK	REFER TO SHEET
MP-1	8AS501
MP-1A	8AS502
BR-1	8AS503
PC-1	8AS504
CW-1	8AS505

- ### DIMENSION NOTES
- ALL DIMENSION STRINGS FROM C.I. OF J.T. TO C.I. OF J.T. EXCEPT AT ENDS OF EXTERIOR WALL & U.N.O.
 - REFER TO PLANS FOR CW, VERT. FRAMING LOCATIONS. REFER TO ELEVATIONS FOR GLASS TYPE
 - REFER TO PLANS FOR WINDOW LOCATIONS IN METAL PANEL & PRECAST SYSTEMS. REFER TO ELEVATIONS FOR LOCATIONS OF JOINTS IN THESE SYSTEMS.
 - VERIFY IN FIELD LOCATION OF ALL EXISTING DIXIE BUILDING ELEMENTS

1 SOUTH ELEVATION AT CONNECTION
SCALE: 1/8" = 1'-0"

CONSULTANTS:

DESMAN ASSOCIATES / PARKING	DATE
CODE CONSULTANTS, INC. / CODE CONSULTANT	
THE SEXTANT GROUP / AV & ACOUSTICAL	
HAMMER DESIGN ASSOCIATES / FOOD SERVICE	
PYBURN & ODOM / ABATEMENT	
TATA & HOWARD / TANK CONSULTANT	
I.S.C. GROUP, INC. / IRRIGATION	
DAN EUSER WATER ARCHITECTURE, INC. / WATER FEATURE	



ARCHITECT/ENGINEERS:

studio **NOVA**

SCHRENK & PETERSON CONSULTING ENGINEERS / CIVIL
KORDA/NEMETH ENGINEERING / STRUCTURAL
BR+A CONSULTING ENGINEERS / MECH. ELECT, PLUMBING, LOW VOLTAGE
ARCHITECTURAL ENGINEERING / PLUMBING
SCALES ASSOCIATES / FIRE PROTECTION

DRAWING TITLE
BLDG 8 SOUTH - NEW CONNECION ELEVATION

APPROVED: PROJECT DIRECTOR
Judd Sanders

PROJECT TITLE
SLVHCS REPLACEMENT MEDICAL CENTER PROJECT

LOCATION
NEW ORLEANS, LOUISIANA

DATE
July 16, 2012

CHECKED
NF

DRAWN
KS

PROJECT NUMBER
100342.00

BUILDING NUMBER
08

DOCUMENT SET PACKAGE
WP_09B

DRAWING NUMBER
8AS203

OFFICE OF CONSTRUCTION AND FACILITIES MANAGEMENT

Department of Veterans Affairs



CONSTRUCTION DOCUMENTS 1
FULLY SPRINKLERED