




A6 PC-1 TYPICAL VERTICAL REVEAL
SCALE: 6" = 1'-0"

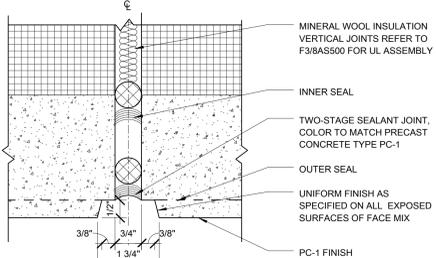


B6 PC-1 TYPICAL VERTICAL JOINT
SCALE: 6" = 1'-0"

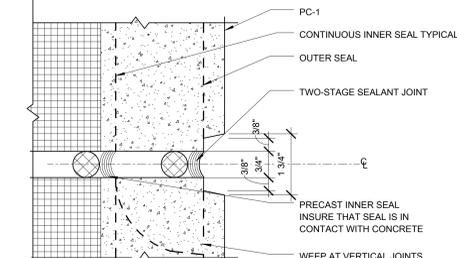


C6 PC-1 TYPICAL HORIZ JOINT
SCALE: 6" = 1'-0"

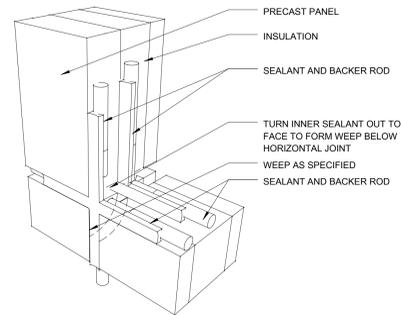


E6 TYP TWO-STAGE SEALANT JOINT AT PC-1
SCALE: 12" = 1'-0"

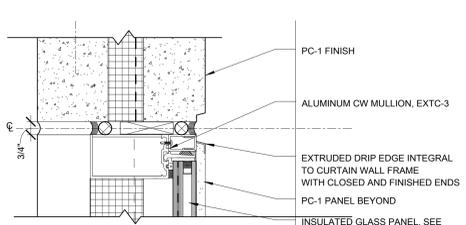


A5 PC-1 CURTAIN WALL HEAD
SCALE: 3" = 1'-0"

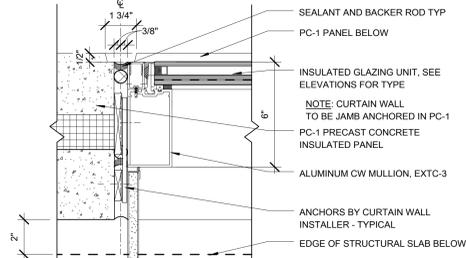

B5 PC-1 CURTAIN WALL JAMB
SCALE: 3" = 1'-0"

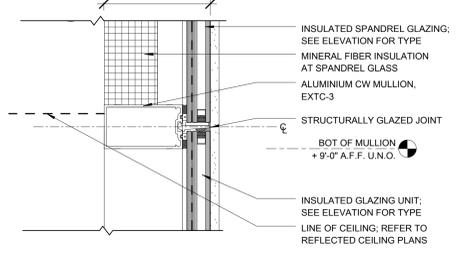


C5 CURTAIN WALL HORIZONTAL JOINT
SCALE: 3" = 1'-0"

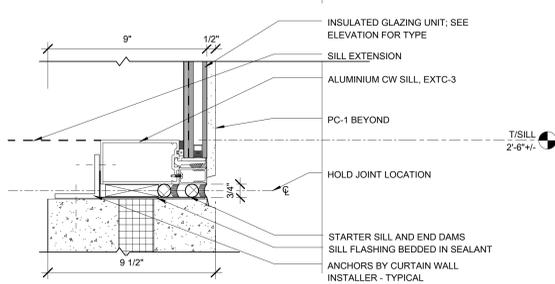


E5 PC-1 CURTAIN WALL SILL
SCALE: 3" = 1'-0"

NOTE:
1) PANEL TYPES ARE FOR PATTERN OF REVEALS ONLY. PRECAST SUBCONTRACTOR TO OPTIMIZE PANELS USING ANY REVEAL SHOWN AS JOINTS.
2) PANELS MAY BE SEQUENCED EITHER LEFT TO RIGHT OR RIGHT TO LEFT. SEE 118" BUILDING ELEVATIONS TO DETERMINE DIRECTION

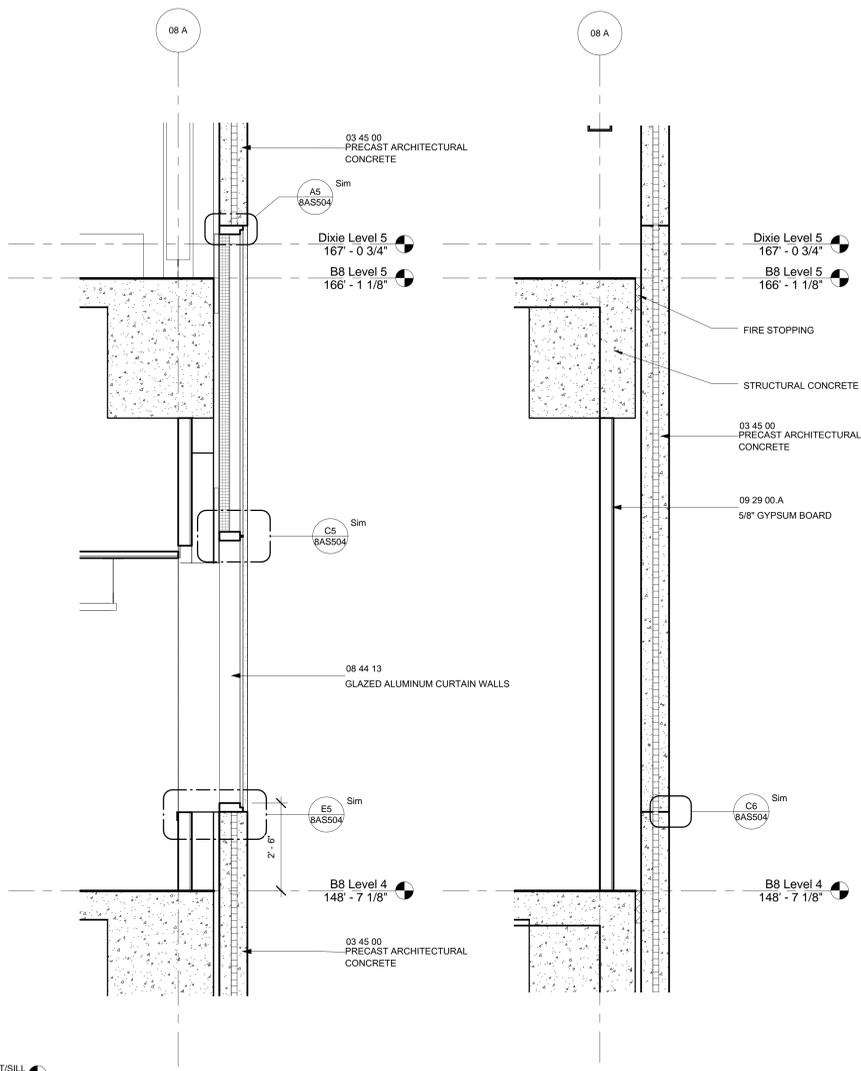


D4 PC-1 Partial Wall Section
SCALE: 1/2" = 1'-0"

D3 PC-1 Partial Wall Section @ Curtain Wall
SCALE: 1/2" = 1'-0"

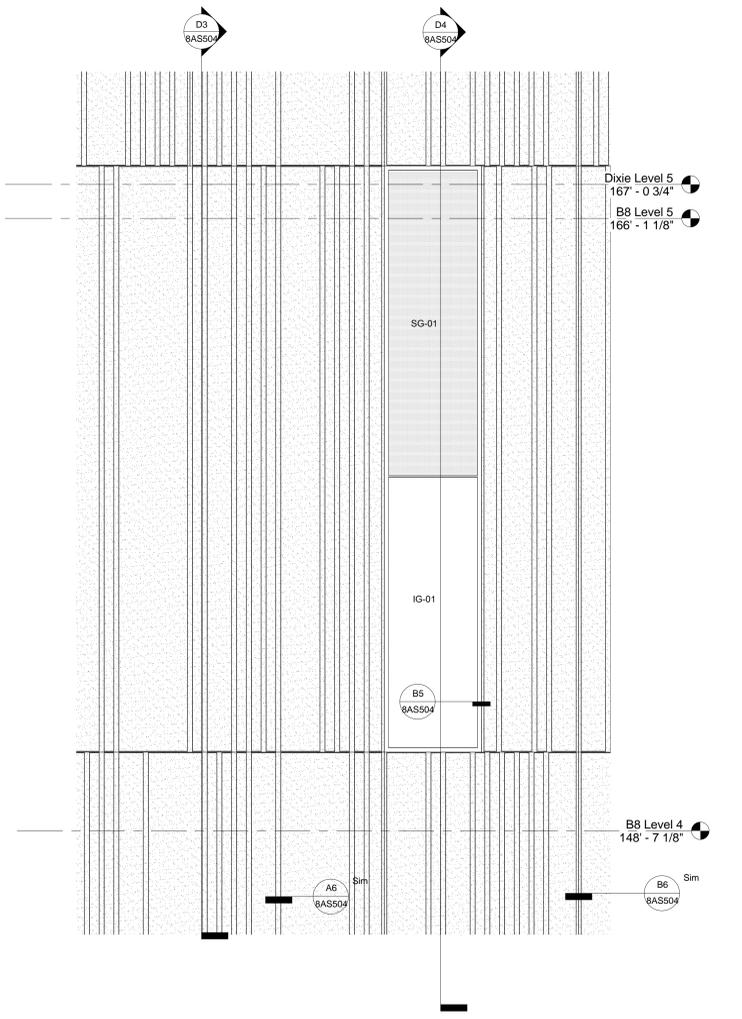

D2 PC-1 Enlarged Elevation
SCALE: 1/2" = 1'-0"

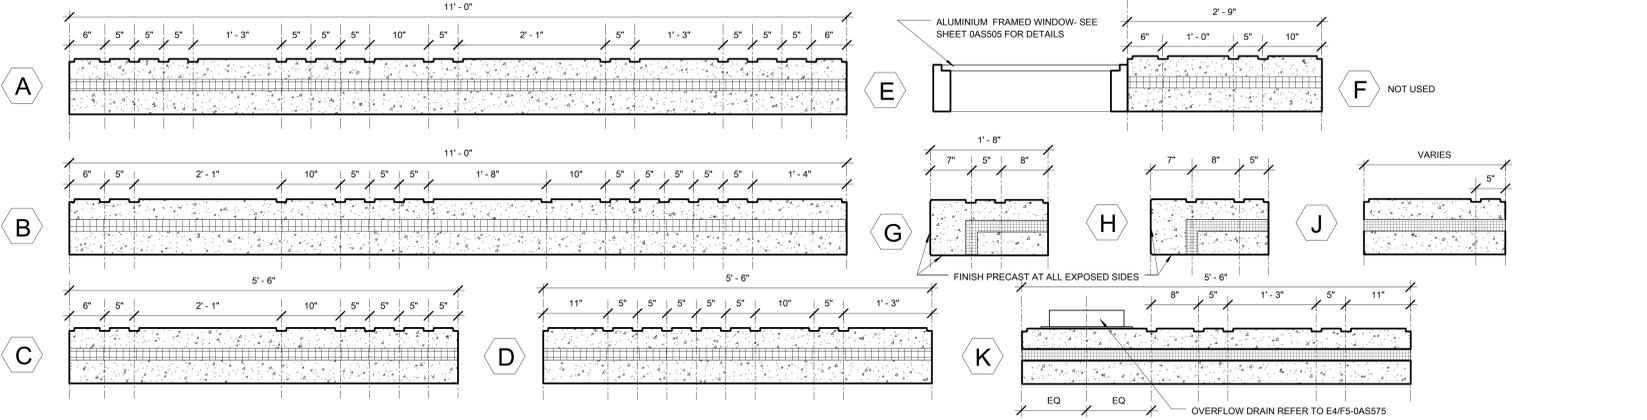

F4 PC-1 PANEL TYPES LEGEND
SCALE: 1" = 1'-0"

CONSULTANTS:
DESMAN ASSOCIATES / PARKING
CODE CONSULTANTS, INC. / CODE CONSULTANT
THE SEXTANT GROUP / AV & ACOUSTICAL
HAMMER DESIGN ASSOCIATES / FOOD SERVICE
PYBURN & ODOM / ABATEMENT
TATA & HOWARD / TANK CONSULTANT
I.S.C. GROUP, INC. / IRRIGATION
DAN EUSER WATER ARCHITECTURE, INC. / WATER FEATURE

ARCHITECT/ENGINEERS:
studio **NOVA**
SCHRENK & PETERSON CONSULTING ENGINEERS / CIVIL
KORDA/NEMETH ENGINEERING / STRUCTURAL
BR+A CONSULTING ENGINEERS / MECH. ELECT, PLUMBING, LOW VOLTAGE
ARCHITECTURAL ENGINEERING / PLUMBING
SCALES ASSOCIATES / FIRE PROTECTION

DRAWING TITLE
BLDG 8 WALL TYPE PC-1
APPROVED: PROJECT DIRECTOR
Judd Sanders

PROJECT TITLE
SLVHCS REPLACEMENT MEDICAL CENTER PROJECT
LOCATION
NEW ORLEANS, LOUISIANA
DATE
July 16, 2012

PROJECT NUMBER
100342.00
BUILDING NUMBER
8
DOCUMENT SET PACKAGE
WP_09B
DRAWING NUMBER
8AS504

CONSTRUCTION DOCUMENTS 1
FULLY SPRINKLERED
OFFICE OF CONSTRUCTION AND FACILITIES MANAGEMENT
Department of Veterans Affairs