

GENERAL NOTES


- ALL WORK SHOWN ON THIS SHEET SHALL BE PERFORMED IN ACCORDANCE WITH NFPA 70-2002, NATIONAL ELECTRICAL CODE.
- LAYOUTS SHOWN ON THIS SHEET ARE DIAGRAMMATIC AND DO NOT NECESSARILY DEPICT EXACT CONFIGURATIONS. EQUIPMENT AND DEVICE LOCATIONS SHALL BE AS NEAR AS PRACTICABLE TO LOCATIONS SHOWN EXCEPT WHERE SPECIFIED, NOTED, OR INDICATED OTHERWISE.
- RECEPTACLES AND OUTLETS ARE SHOWN IN APPROXIMATE LOCATIONS. COORDINATE FINAL LOCATIONS WITH OWNER. LOCATE RECEPTACLES AND OUTLETS WITHIN TEN FEET OF LOCATIONS SHOWN AT NO ADDITIONAL COST TO OWNER.
- TERMINATE ALL CONDUITS USING INSULATING BUSHING.
- ALL TELECOMMUNICATIONS WORK SHALL CONFORM TO THE VAMC-OKC WIRING CLOSET AND CABLE RUN SPECIFICATIONS JANUARY 23, 2008 EDITION.

SYMBOL LEGEND


- ◁ EMPTY 4-11/16"x4-11/16"x2-1/8" BOX WITH 2-GANG PLASTER RING, BLANK COVER, AND 1-1/4" UP TO CEILING SPACE. MOUNT BOX AT SAME HEIGHT AS ADJACENT RECEPTACLE.
- ◀ LOADED 4-11/16"x4-11/16"x2-1/8" BOX WITH 2-GANG PLASTER RING, BLANK COVER, AND 1-1/4" UP TO CEILING SPACE. MOUNT BOX AT SAME HEIGHT AS ADJACENT RECEPTACLE. LOAD BOX WITH FOUR (4) RJ-45 JACKS AND FOUR (4) CAT 6 CABLES TO TELEPHONE ROOM.

KEYED NOTES THIS SHEET

- 501 EXISTING TELEPHONE/DATA BACKBOARD.
- 502 ROUTE FOUR(4) CAT6 CABLES TO TELEPHONE ROOM. SUPPORT CABLES PER VA STANDARDS. TERMINATE AS DIRECTED BY VA REPRESENTATIVE.
- 503 OUTLET BOX 84" AFF FOR FLATSCREEN DISPLAY.

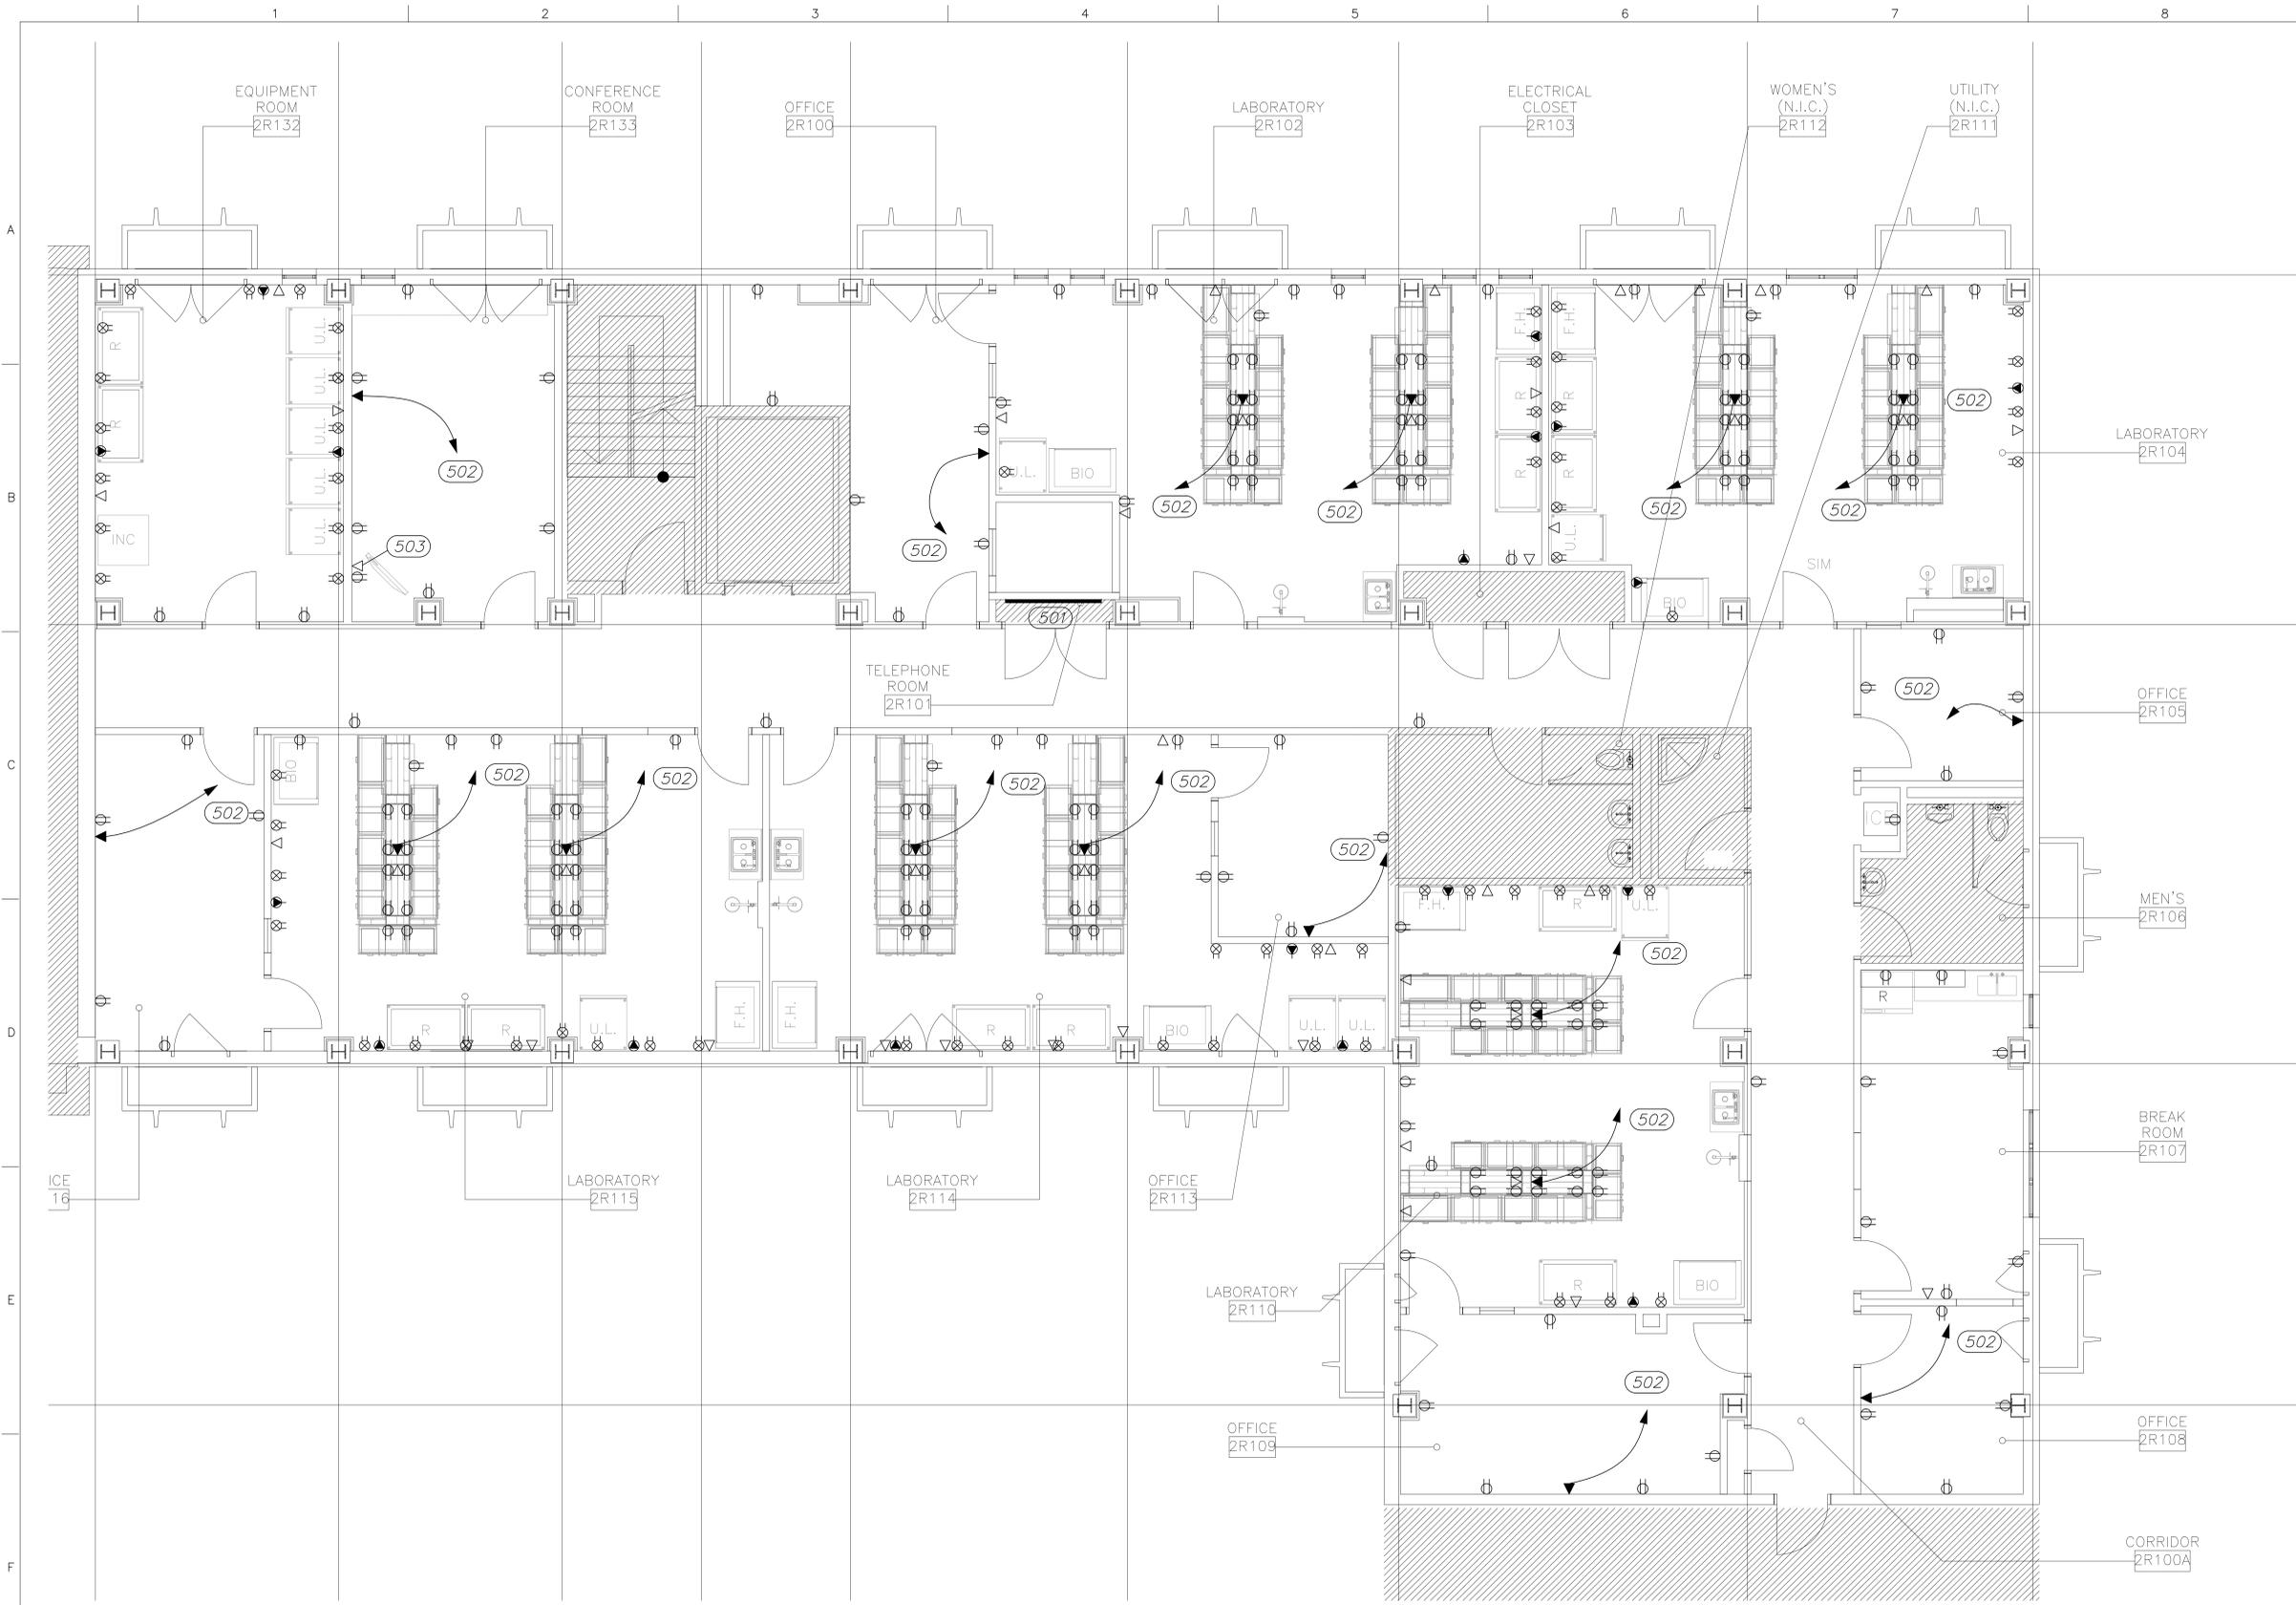

1 COMMUNICATIONS PLAN - SECOND FLOOR
 E-502
 SCALE: 1/4"=1'-0"
 SCALE IN FEET

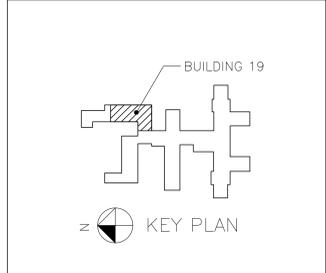

P:\Documents and Settings\vaadhoopok\My Documents\11596m
 5/11/2012 11:59am
 PROJECT: RENOVATION BUILDING 19 VA
 EXPIRATION DATE: 30 JUNE 2013

CONTRACTOR:		ARCHITECT/ENGINEERS:		
CONSTRUCTION CONTRACTOR:		ARCHITECT:	MECHANICAL ENGINEER:	ELECTRICAL ENGINEER:
HGL CONSTRUCTION 2000 S. DOUGLAS BOULEVARD MIDWEST CITY, OKLAHOMA 73130 405-737-7588 CONTACT: EDDIE COX		PDG Architects 333 12th Ave SE Norman, Oklahoma 73071 OFFICE PHONE: 405-360-1102 OFFICE FAX: 405-360-0055 CONTACT: DONALD FRICK	ZRHD, P.C. Engineers 1318 N. Robinson Oklahoma City, Oklahoma 73103 405-942-8475 CONTACT: John Parks	ZRHD, P.C. Engineers 1318 N. Robinson Oklahoma City, Oklahoma 73103 405-942-8475 CONTACT: Wayne Wright

Drawing Title COMMUNICATIONS PLAN SECOND FLOOR		Project Title RENOVATION BUILDING 19 VA MEDICAL CENTER		Project Number 635-11-303	
Approved: Project Director		Location VAMC, OKLAHOMA CITY, OK		Building Number 19	
Date 5/11/2012	Checked WHW	Drawn SWW	Drawing Number E-502		
Dwg. 69 of 71			Office of Construction and Facilities Management Department of Veterans Affairs		