



REFLECTED CEILING LEGEND	
	2' X 4' ACOUSTICAL TILE CEILING
	2' X 2' ACOUSTICAL TILE CEILING
	2' X 4' RECESSED LIGHT FIXTURE
	2' X 2' RECESSED LIGHT FIXTURE
	RECESSED DOWN LIGHT FIXTURE

GENERAL CONSTRUCTION NOTES


1. SEE APPROVED SUBMITTALS FOR NEW CEILING TYPE AND DUFFUSER/ RETURNS TYPES.
2. CONTRACTOR TO REPLACE EXISTING DIFFUSERS/RETURNS WITH NEW DIFFUSER/RETURNS.
3. CONTRACTOR TO REPAIR ANY SURFACES DAMAGED DURING REMOVAL AND INSTALLATION OF CEILING SYSTEM. FINISHES OF EXISTING SURFACES TO MATCH EXISTING FINISHES.
4. IT IS THE CONTRACTORS RESPONSIBILITY TO DISCONNECT AND RECONNECT ANY MECHANICAL OR ELECTRICAL DEVICES MOUNTED IN THE CEILING SYSTEM. CONTRACTOR TO NOTIFY COR IN ADVANCE BEFORE DISCONNECTING OR RECONNECTING ANY DEVICES.
5. ALL PATIENT ROOMS HAVE PATIENT LIFT SYSTEMS MOUNTED IN THE CEILINGS. CONTRACTOR TO USE CAUTION WHEN REMOVING EXISTING CEILING AND INSTALLING NEW CEILING.
6. THE ONLY CEILING MOUNTED DEVICES SHOWN ARE THE LIGHTS. IT IS THE CONTRACTORS RESPONSIBILITY TO FIELD VERIFY EXISTING CONDITION BEFORE SUBMITTING A PROPOSAL.

CODED NOTES

- 1 INSTALL NEW CEILING SYSTEM
- 2 INSTALL REMOVED CUBICAL TRACK IN EXISTING LOCATION. NOT SHOWN ON DRAWING.
- 3 THE GENERAL INTENT OF INSTALLATION OF NE CEILING IN EXISTING ROOMS ARE GETTING A FINISH UP GRADE IS TAHT THE NEW GRID IS CHANGING FROM A 2' X 4' GRID TO A 2' X 2' GRID PATTERN. THE NEW GRID PATTERN IS TO ALLOW FOR LIGHTS, DIFFUSERS, RETURNS, SPRINKLERS AND OTHER CEILING MOUNTED ITEMS TO REMAIN IN THE SAME LOCATION. ANY CHANGE THAT RESULTS I THE MOVING OF ANY CEILING MOUNTED ITEMS WILL BE AT THE COST OF THE CONTRACTOR.
- 4 CONTRACTOR TO REMOVE ITEMS, IE: SPRINKLER ESCUTHEONS, DIFFUSERS, RETURNS, ETC, AS REQUIRED TO INSTALL NEW CEILING GRID AND CEILING TILES AND REPLACE AFTER NEW CEILING IS INSTALLED. CONTRACTOR TO TAKE PICTURES PRIOR TO DEMOLITION TO DOCUMENT WHERE ITEMS ARE TO BE REINSTALLED.

DEMOLITION NOTES

- 1 REMOVE EXISTING CEILING SYSTEM.
- 2 REMOVED EXISTING CUBICAL TRACK IAND SAVE FOR REINSTALLATION

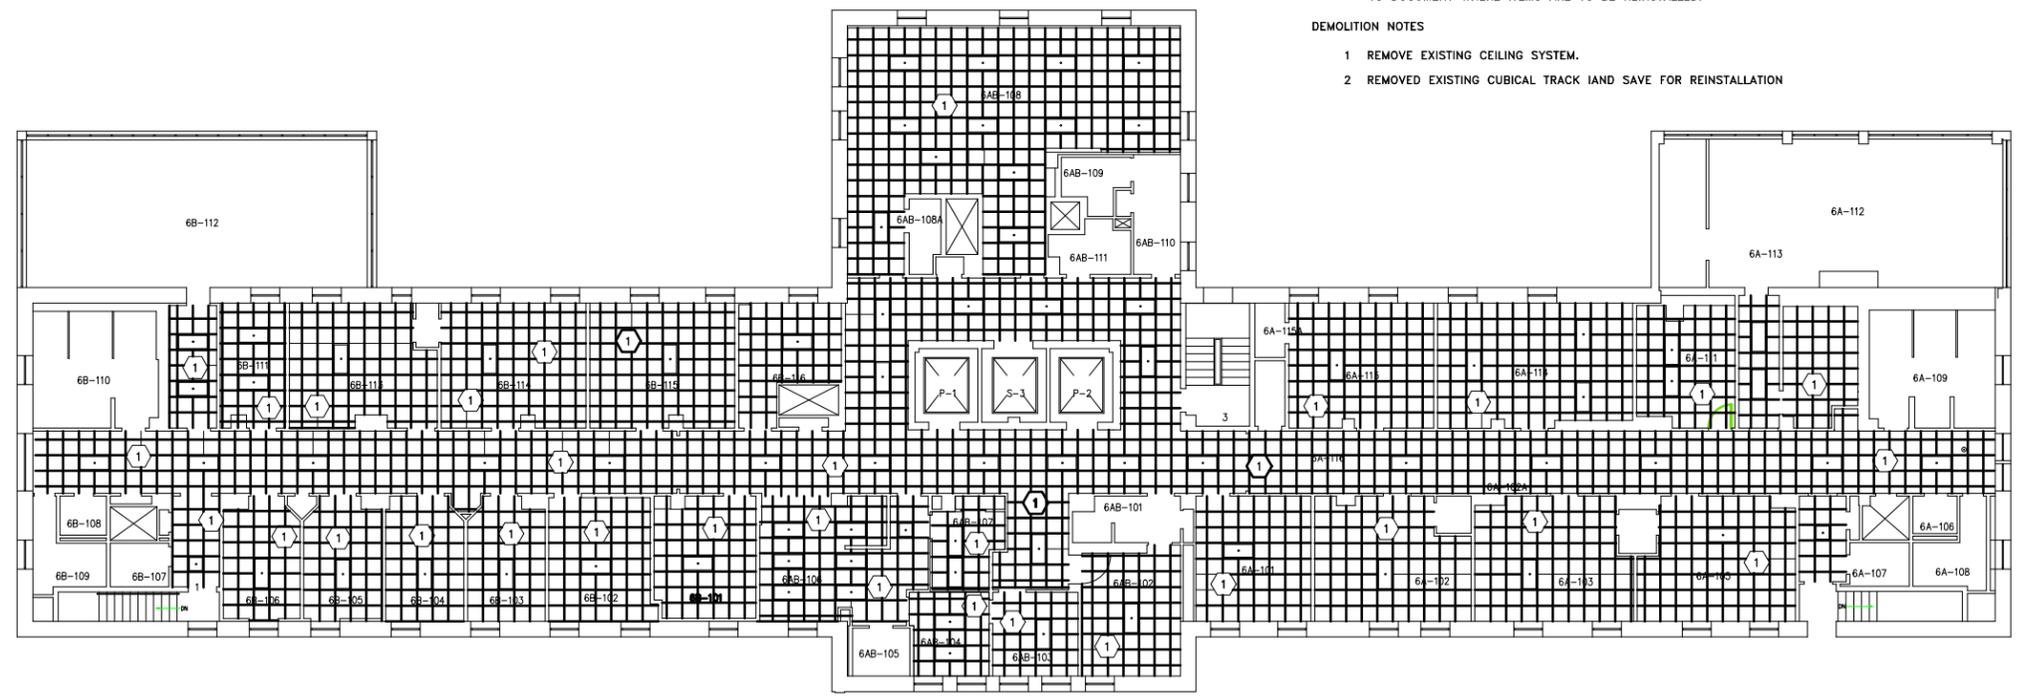

SIXTH FLOOR REFLECTED CEILING PLAN

NOT TO SCALE

	APPROVED:	APPROVED: INTERIM SAFETY MANAGER JUSTIN GREENE	APPROVED: CHIEF, FACILITIES MANAGEMENT SERVICE LINE CLAYTON HELMS	APPROVED: MEDICAL CENTER DIRECTOR KARIN MCGRAW, MSN, FACHE	DRAWING TITLE: Sixth Floor Ceiling Tile Replacement	DRAWING No. AS-102
	APPROVED:	APPROVED: INFECTION CONTROL SHAWN MILLS	APPROVED: ASSOCIATE DIRECTOR for PATIENT CARE SERVICES/EXECUTIVE NURSE DEBRA L LEGG	APPROVED: ASSOCIATE DIRECTOR BRIAN NIMMO, MS	PROJECT TITLE: Fourth & Sixth Floor, Ceiling Tile Replacement	PROJECT No. 517
	APPROVED:		APPROVED: SERVICE LINE CHIEF	APPROVED: CHIEF OF STAFF JOHN D. BERRYMAN, M. D.	DATE 3/6/2012	REV. SCALE MTS

Medical Center
200 Veterans Av
Beckley, WV.
25801

