



- NOTES:**
- 1 ELECTRICAL PANEL BOX LOCATED ON EXTERIOR OF BUILDING 5
  - 2 EXTERIOR LIGHTING TO MATCH EXISTING
  - 3 EXTERIOR LIGHTING WALL WASHERS/ DIRECTIONAL LIGHTING
  - 4 72" CONCRETE WALKWAYS TO TIE INTO EXISTING ON THE NORTH, SOUTH, AND WEST OF GAZEBO
  - 5 EXTERIOR NORTH AND SOUTH LANDINGS
  - 6 EXTERIOR CEILING FAN TO PROVIDE AIR CIRCULATION
  - 7 LANDSCAPING TO MATCH BUILDING 7
  - 8 HOSE BIB TO TIE TO STATION'S WATER SUPPLY
  - 9 EXTERIOR SECURITY CAMERAS AND EMERGENCY CALL BOX TO MATCH EXISTING
  - 10 CUPOLA WITH VENTS TO MATCH BUILDING 7
  - 11 SLATE COMPOSITE ROOF TILES TO MATCH HISTORICAL BUILDINGS
  - 12 COMPOSITE WOOD TRIM DETAIL TO MATCH HISTORIC BUILDINGS
  - 13 COMPOSITE WOOD OR STONE COLUMNS TO MATCH HISTORIC BUILDING
  - 14 COMPOSITE STRUCTURAL COLUMNS
  - 15 ENGINEERED CONCRETE SLAB FOUNDATION

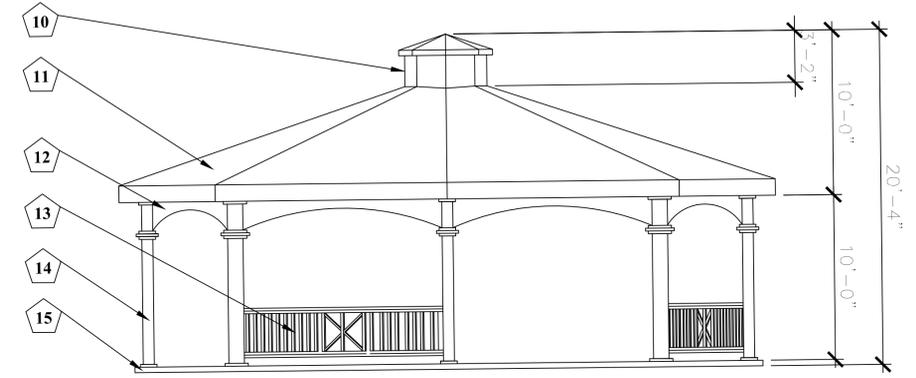

**SOUTHEAST ELEVATION**  
NTS

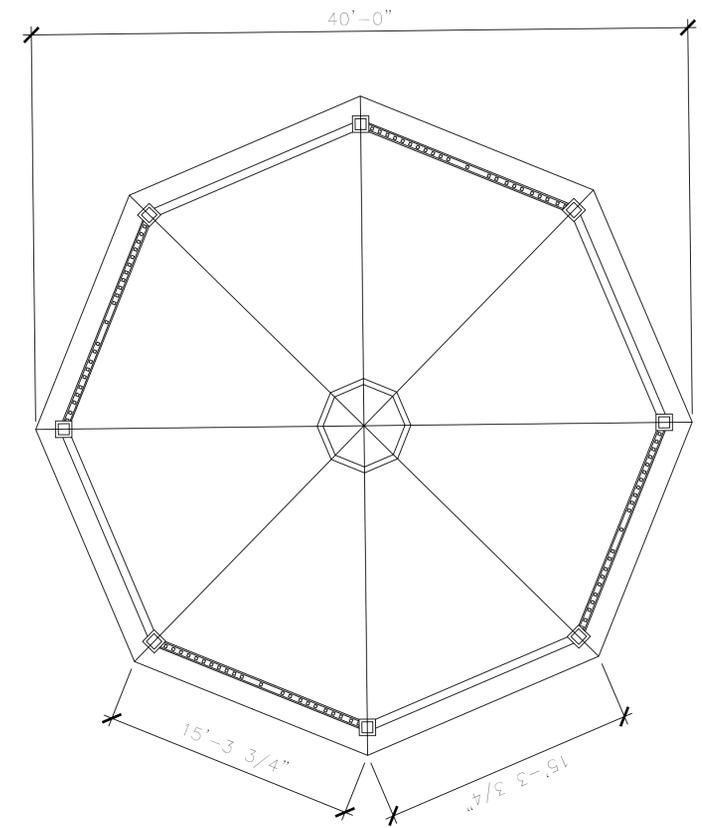

**FLOOR PLAN**  
NTS

**SITE PLAN**  
NTS

Approved: Work Group Leader		Project Title Gazebo and Walking Trail 1100 North College Avenue		Drawing Title GAZEBO PLAN		Project Number 564-17-102		 <b>Engineering Service</b>  <b>VETERANS HEALTH CARE SYSTEM OF THE OZARKS</b>
Approved: Engineering Service Chief		One inch or not to scale! 0 1		Location Fayetteville, Arkansas		Building Number 564		
Notes and/or Revisions: Date		Scale: NTS		Date 06/09/2017		Drawing Number C1100		
CUSTOM VA FORM 08-6231B, MAY 2012		Checked ENG		Drawn CGS		Sheet 1 of 2		