
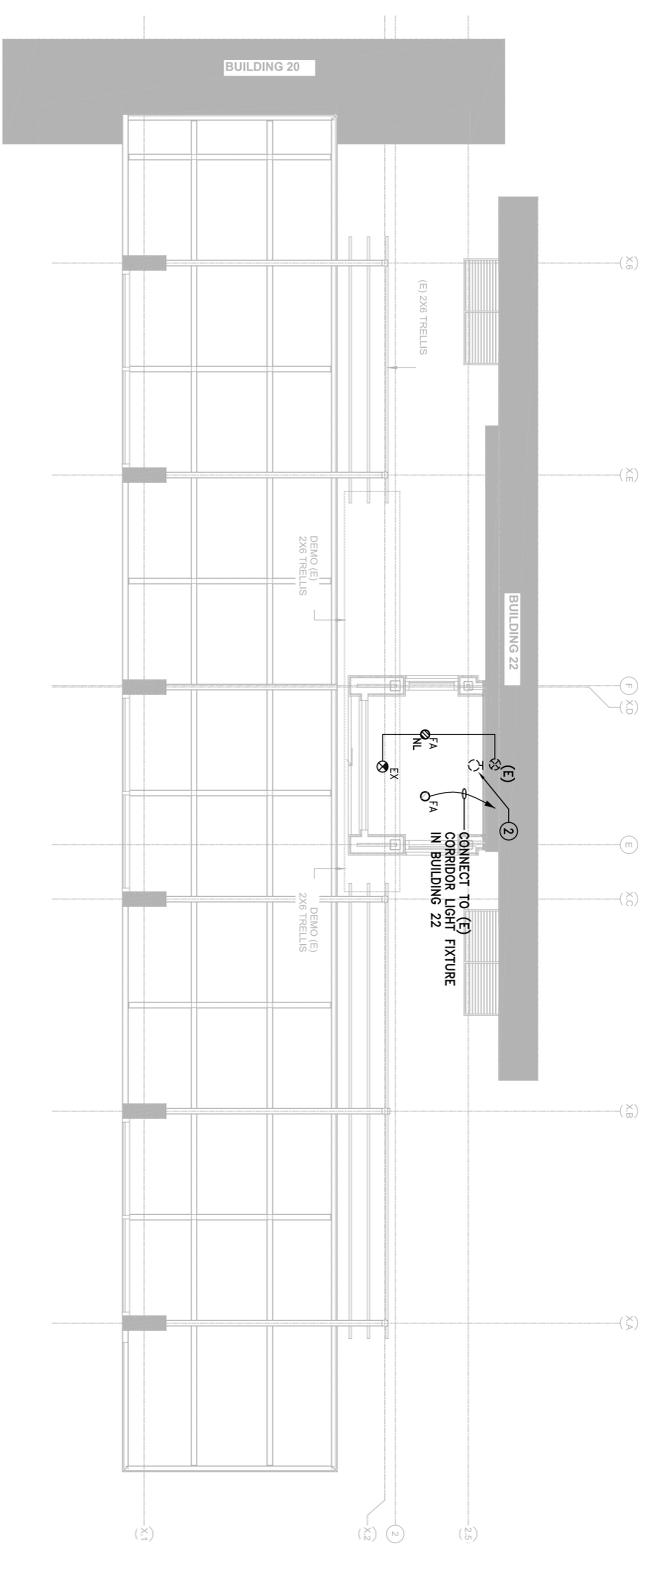


- SHEET NOTES**
- ① REFER TO BUILDING 22 ELECTRICAL PLAN DRAWING ES-1-4 FOR PANEL ERI LOCATION.
 - ② REMOVE EXISTING WALL MOUNTED LIGHT FIXTURE WITH ASSOCIATED CONDUIT & WIRING BACK TO PANEL OF ORIGIN, PATCH AND PAINT WALL TO MATCH EXISTING.

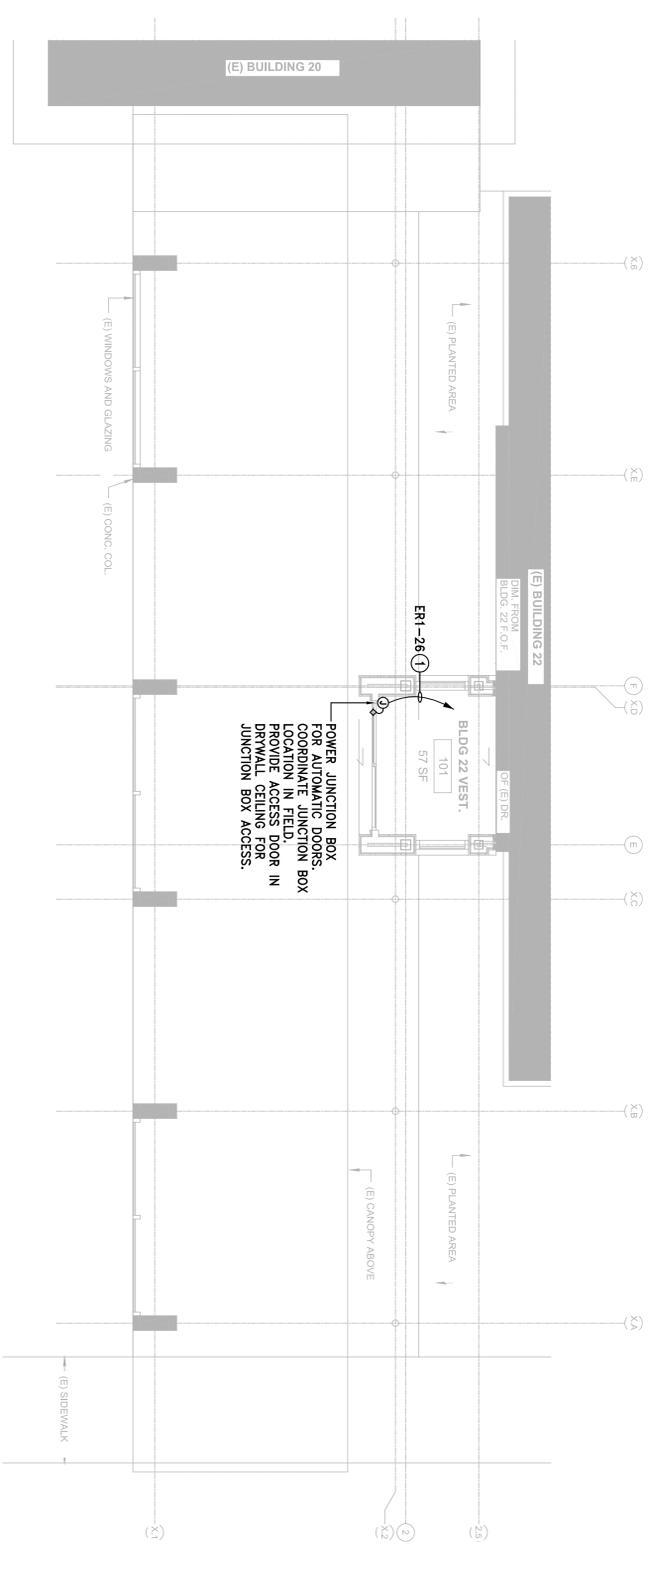


Revisions	Date
CONSTRUCTION DOCUMENTS BID SET	06.10.2011

CONSULTANTS:

STRUCTURAL
 E&A ENGINEERS
 20295 E. VALLEY BLVD SUITE 110
 WALNUT, CA 91778-2705
 FAX: (909) 598-8565

MECHANICAL & PLUMBING
 S&I ENGINEERS
 300 FRANK OGAWA PLAZA, SUITE 308
 OAKLAND, CA 94612
 FAX: (510) 832-1507

ELECTRICAL
 FVA INC
 330 FRANKLIN STREET
 OAKLAND, CA 94612
 FAX: (510) 763-703

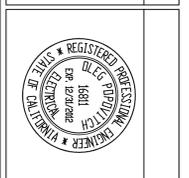

ARCHITECT/ENGINEERS:

WEI
 Architecture + Interiors

239 9TH STREET, Suite 201
 SAN FRANCISCO, CA 94103
 Tel: (415) 682-7236
 Fax: (415) 682-7236
 www.weiarchitects.com

Drawing Title FIRST FLOOR LIGHTING PLAN (BLDG 22 VEST) & ELECTRICAL PLAN (BLDG 22 VEST)	Project Title ENTRANCE VESTIBULES AND COVERED WALKWAY AT BLDGS. 20 AND 22	Project Number 612-10-066	Office of Facilities Management
Location VANCHCS - MARTINEZ	Building Number BLDG. 20 & 22	Building Number ES-1-1	
Approval: Project Director Date: JUNE 10, 2011	Checked: ECA/ME Drawn: FVA TEAM		