


May 26, 2017 - 8:46am
 Drawing File: E:\2015\000\000\20151144\000\01 CAD\06 Elec\E2-E4 - Building 11.dwg Layout: 1st Floor

three eighths inch = one foot
 one quarter inch = one foot
 one eighth inch = one foot
 one quarter inch = one foot
 three quarters inch = one foot
 one inch = one foot
 one and one half inches = one foot
 three inches = one foot

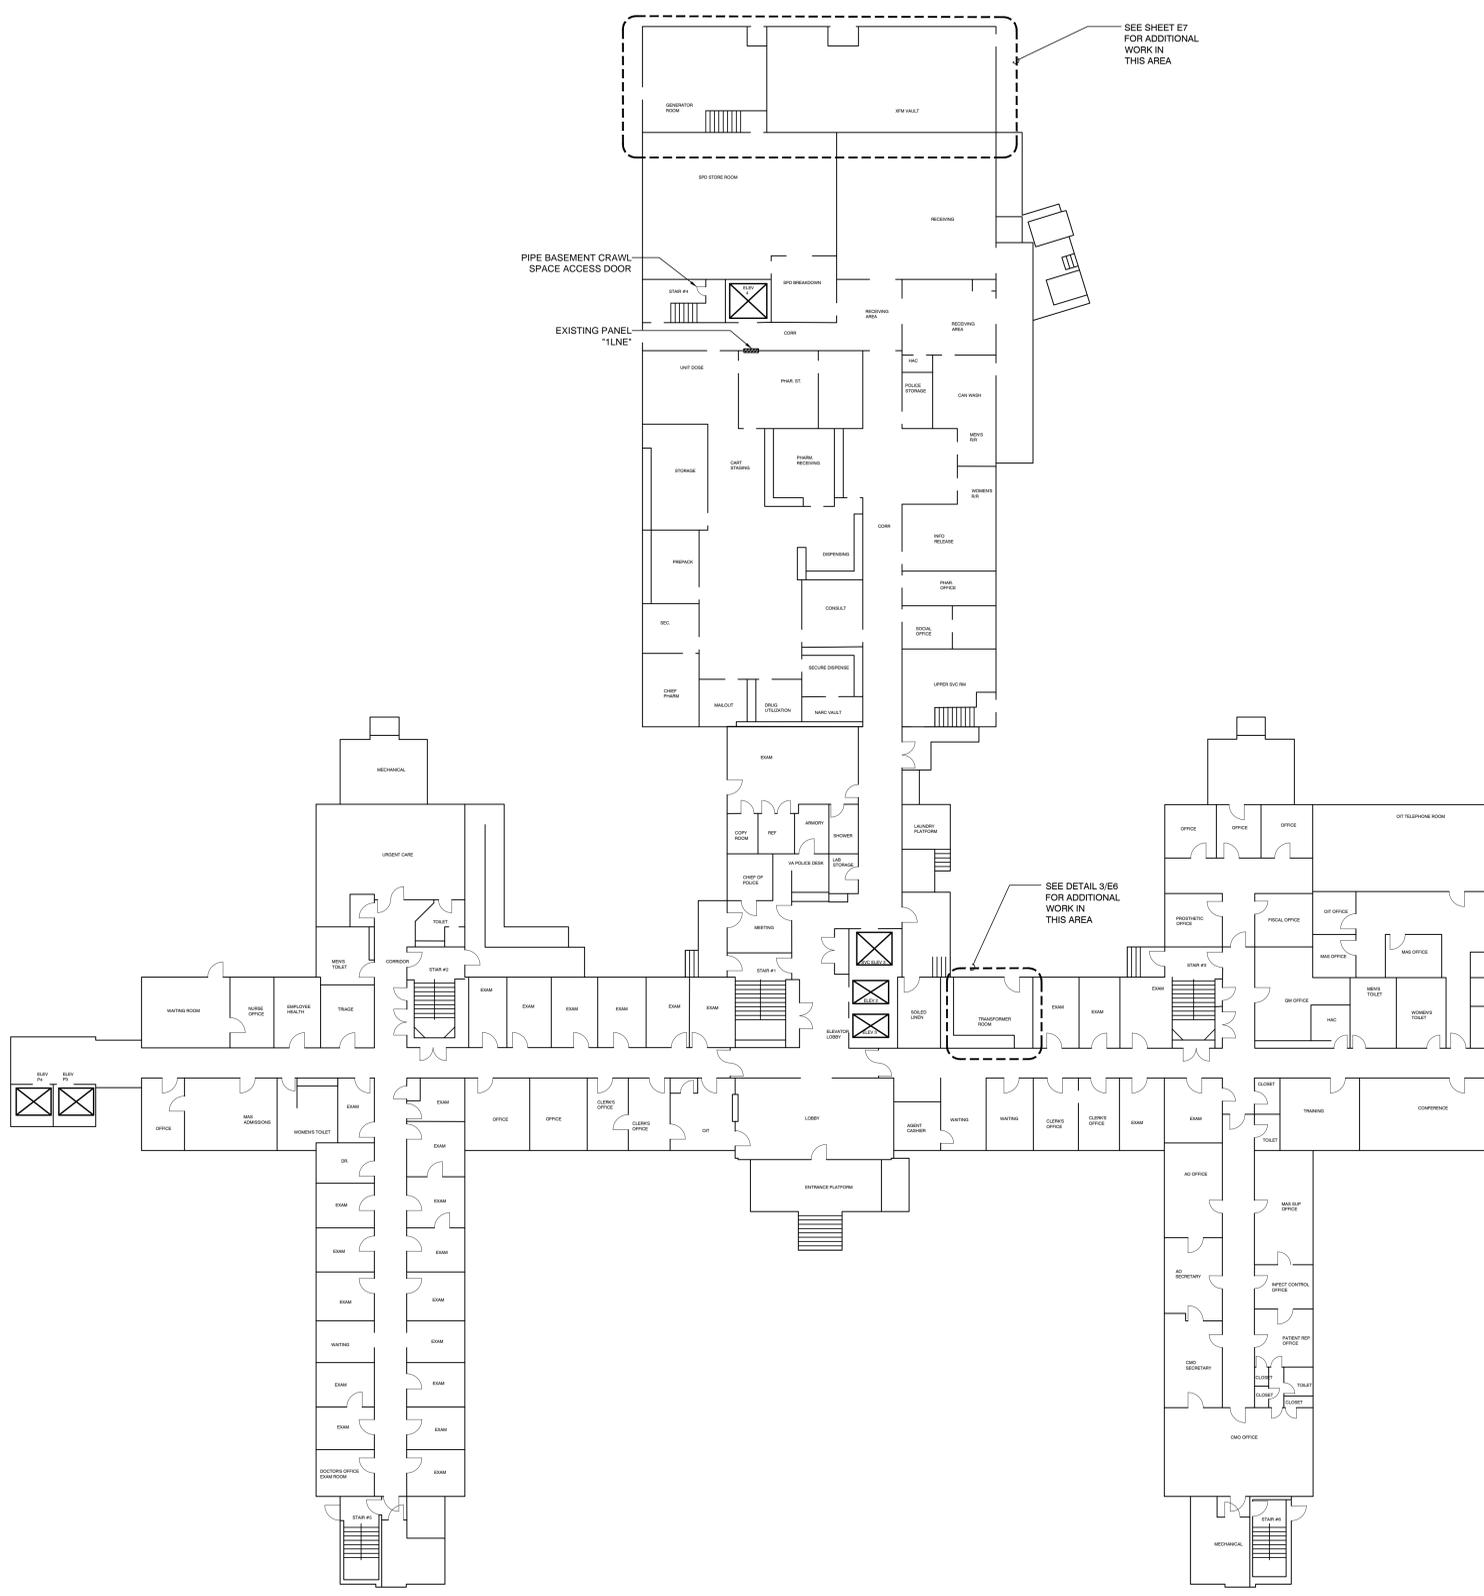

POWER PLAN - BUILDING 11 - FIRST FLOOR
 SCALE: 1/16" = 1'-0"



CONSTRUCTION SET

Revisions:	Date:

CONSULTANTS:



ARCHITECT/ ENGINEERS

BHB BAIRD, HAMPTON & BROWN, INC.
 ENGINEERING & SURVEYING

6300 Ridgela Place, Ste 700 Fort Worth, TX 76116 Tel: 817-338-1277 Fax: 817-338-9245
 TBPE Firm 000044 E-Mail: mail@bhbc.com Web Site: www.bhbc.com TBPLS FIRM 10011300

Drawing Title: POWER PLAN - BUILDING 11 - FIRST FLOOR
Approved Project Director: OFFICE OF CONSTRUCTION AND FACILITIES MANAGEMENT WESTERN REGION

Project Title: UPGRADE EMERGENCY POWER TASK ORDER NO. VA257-15-R-0634
Location: 3600 MEMORIAL BLVD., KERRVILLE, TX 78028
Date: MAY 26, 2017

Project Number 671A4-15-123
Building Numbers 11, 90, 96
Drawing Number E3
Dwg. _____ of _____

Office of
Construction
and Facilities
Management

Department of
Veterans Affairs